


1
1501
Demolition Ground Floor Plan
Scale - 1:100 @ A3

0
1 m
2 m
3 m
4 m
5 m
10 m

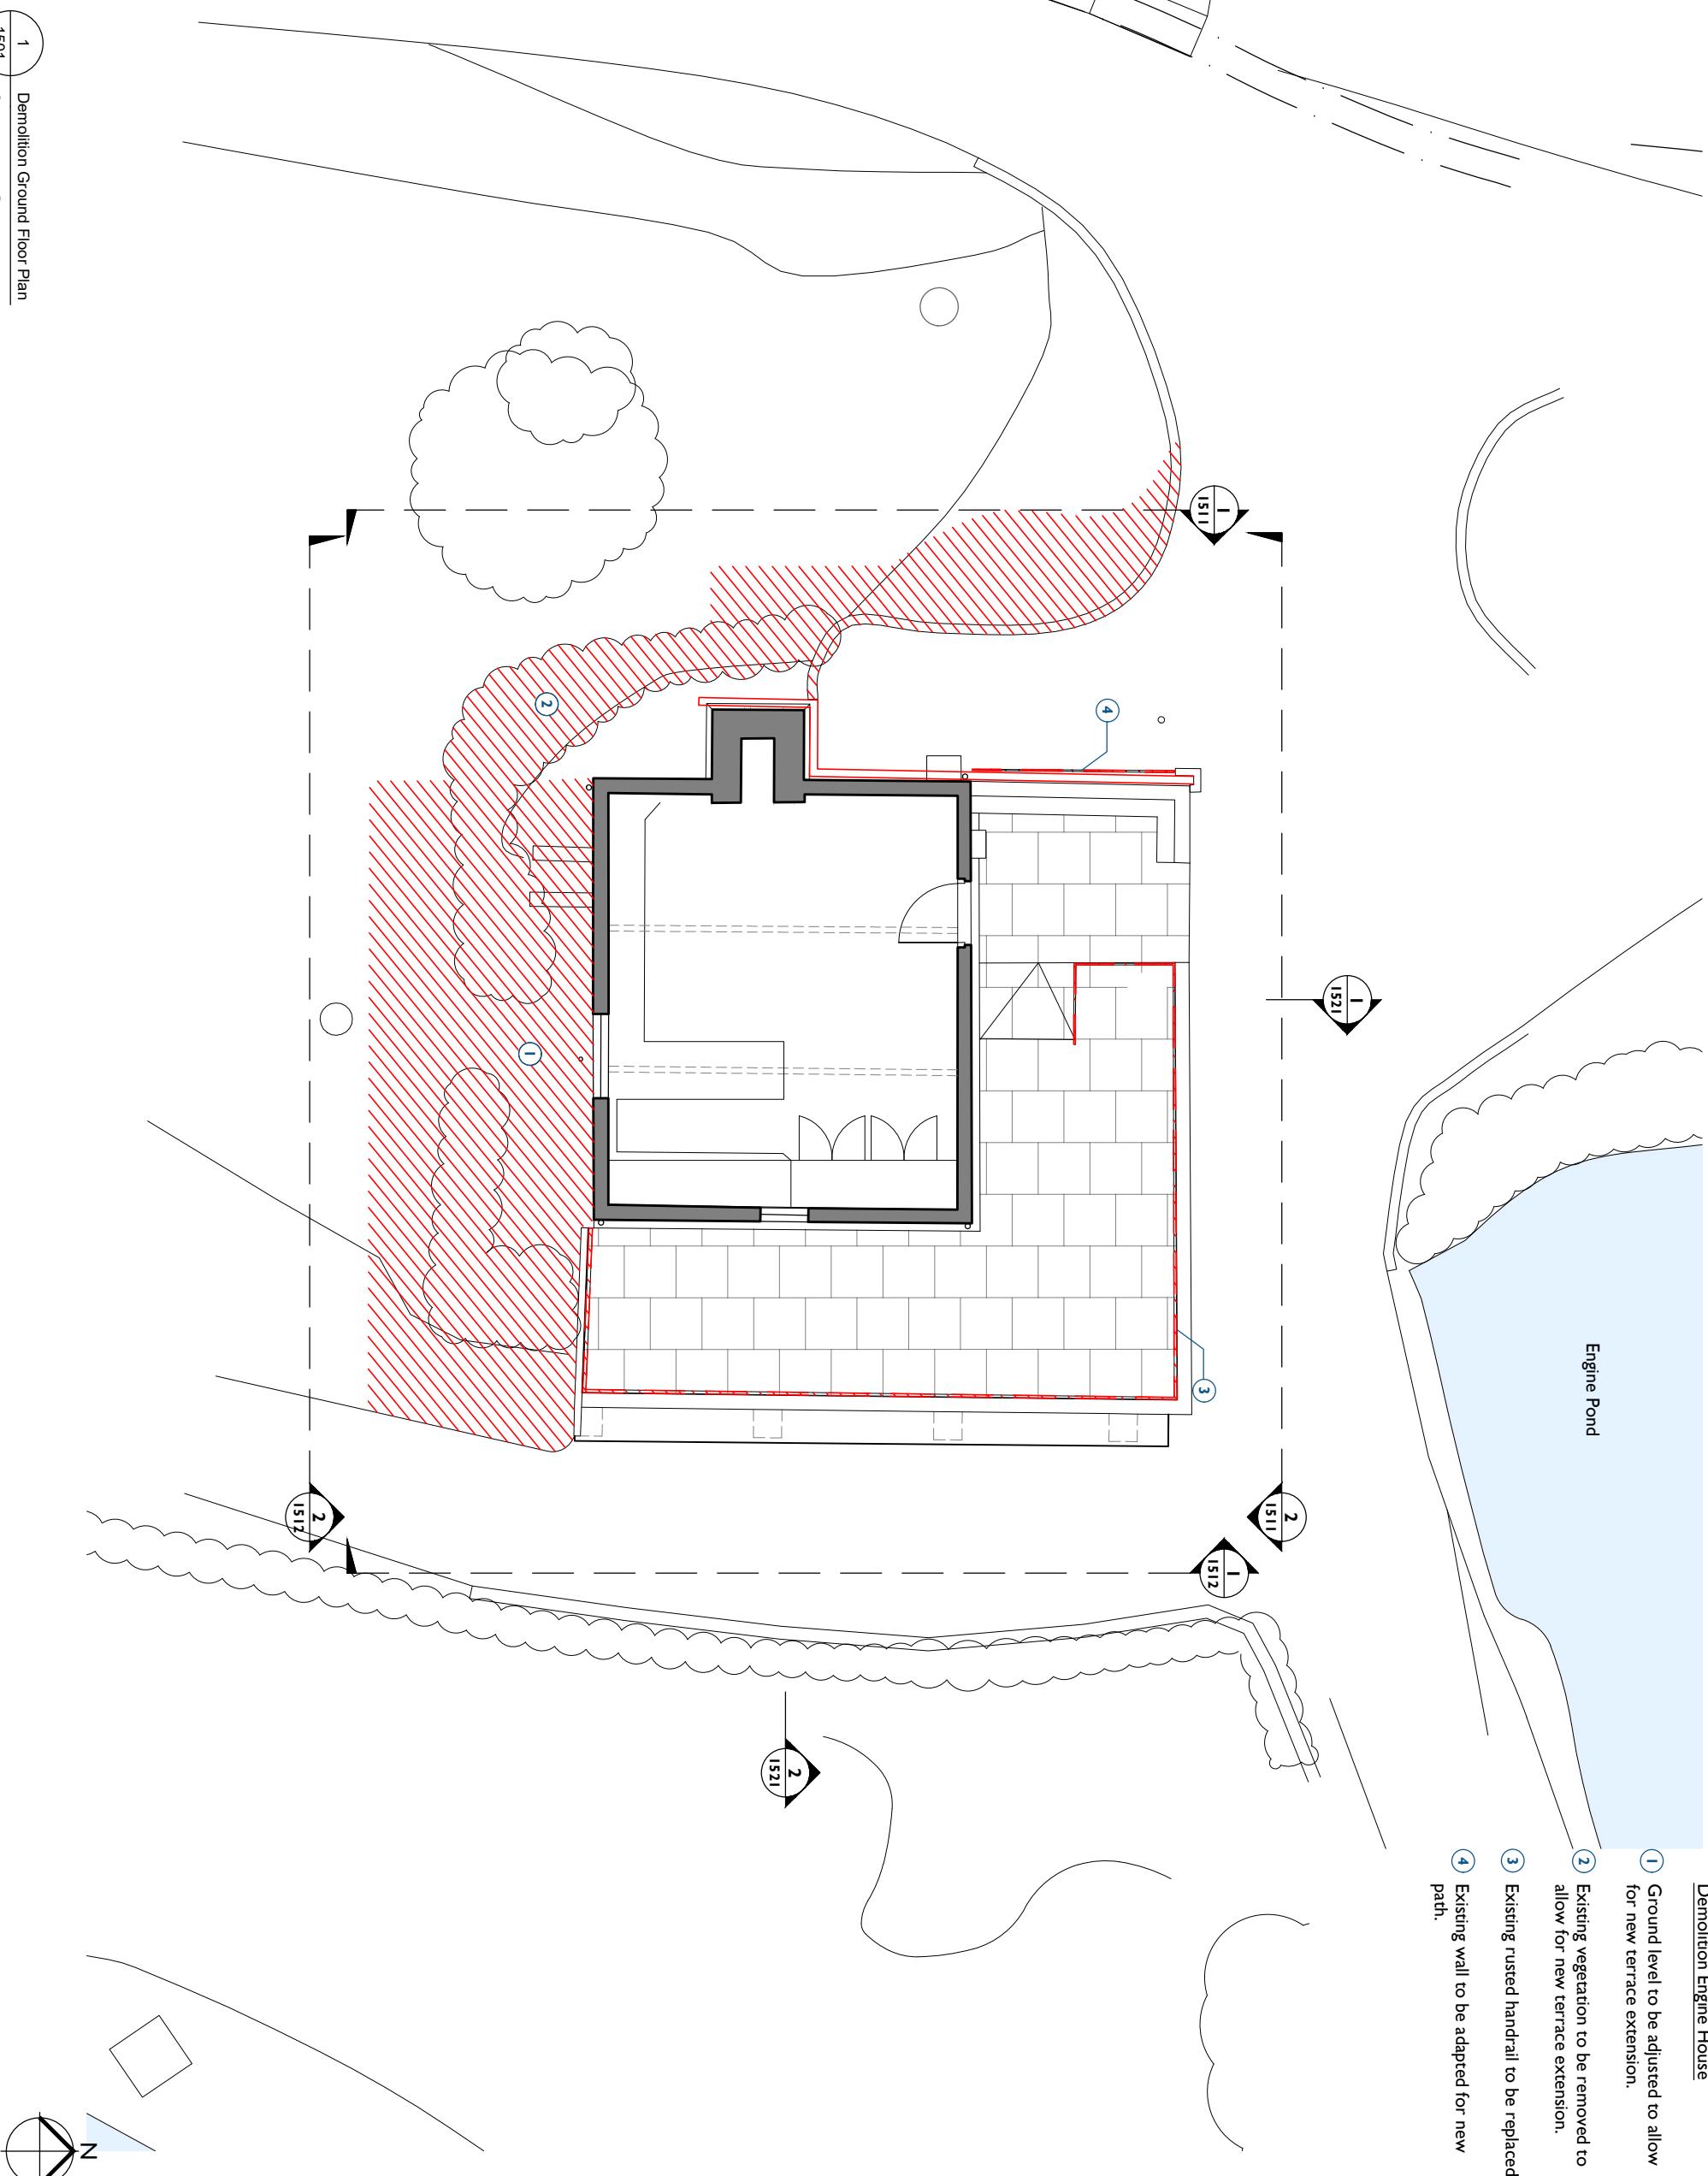

REF	07/07/25	JS	J.C	Planning Issue
PROJECT	Leonardslee Gardens			
CLIENT	Leonardslee Lakes and Gardens			
JOB NUMBER	242769			
PURCELL				
TITLE Demolition Ground Floor Plan Engine House				
SIZE	SCALE	A3L 1:100@A3		
REV	SUITABILITY/REASON FOR ISSUE			
P03 Planning Issue				
DRAWING NUMBER				

NOTES: The drawings are for the sole use of the client and Purcell. They are not to be reproduced, given away, or used for any other purpose without the written permission of Purcell. Any changes to the drawings must be made by Purcell. Purcell is not responsible for any errors or omissions in the drawings. The drawings do not include all information required for construction, such as structural, electrical, and mechanical details. It is the responsibility of the client to ensure that all necessary information is included and that the drawings are suitable for the intended purpose. Purcell shall not be liable for any damages or losses resulting from the use of these drawings.