


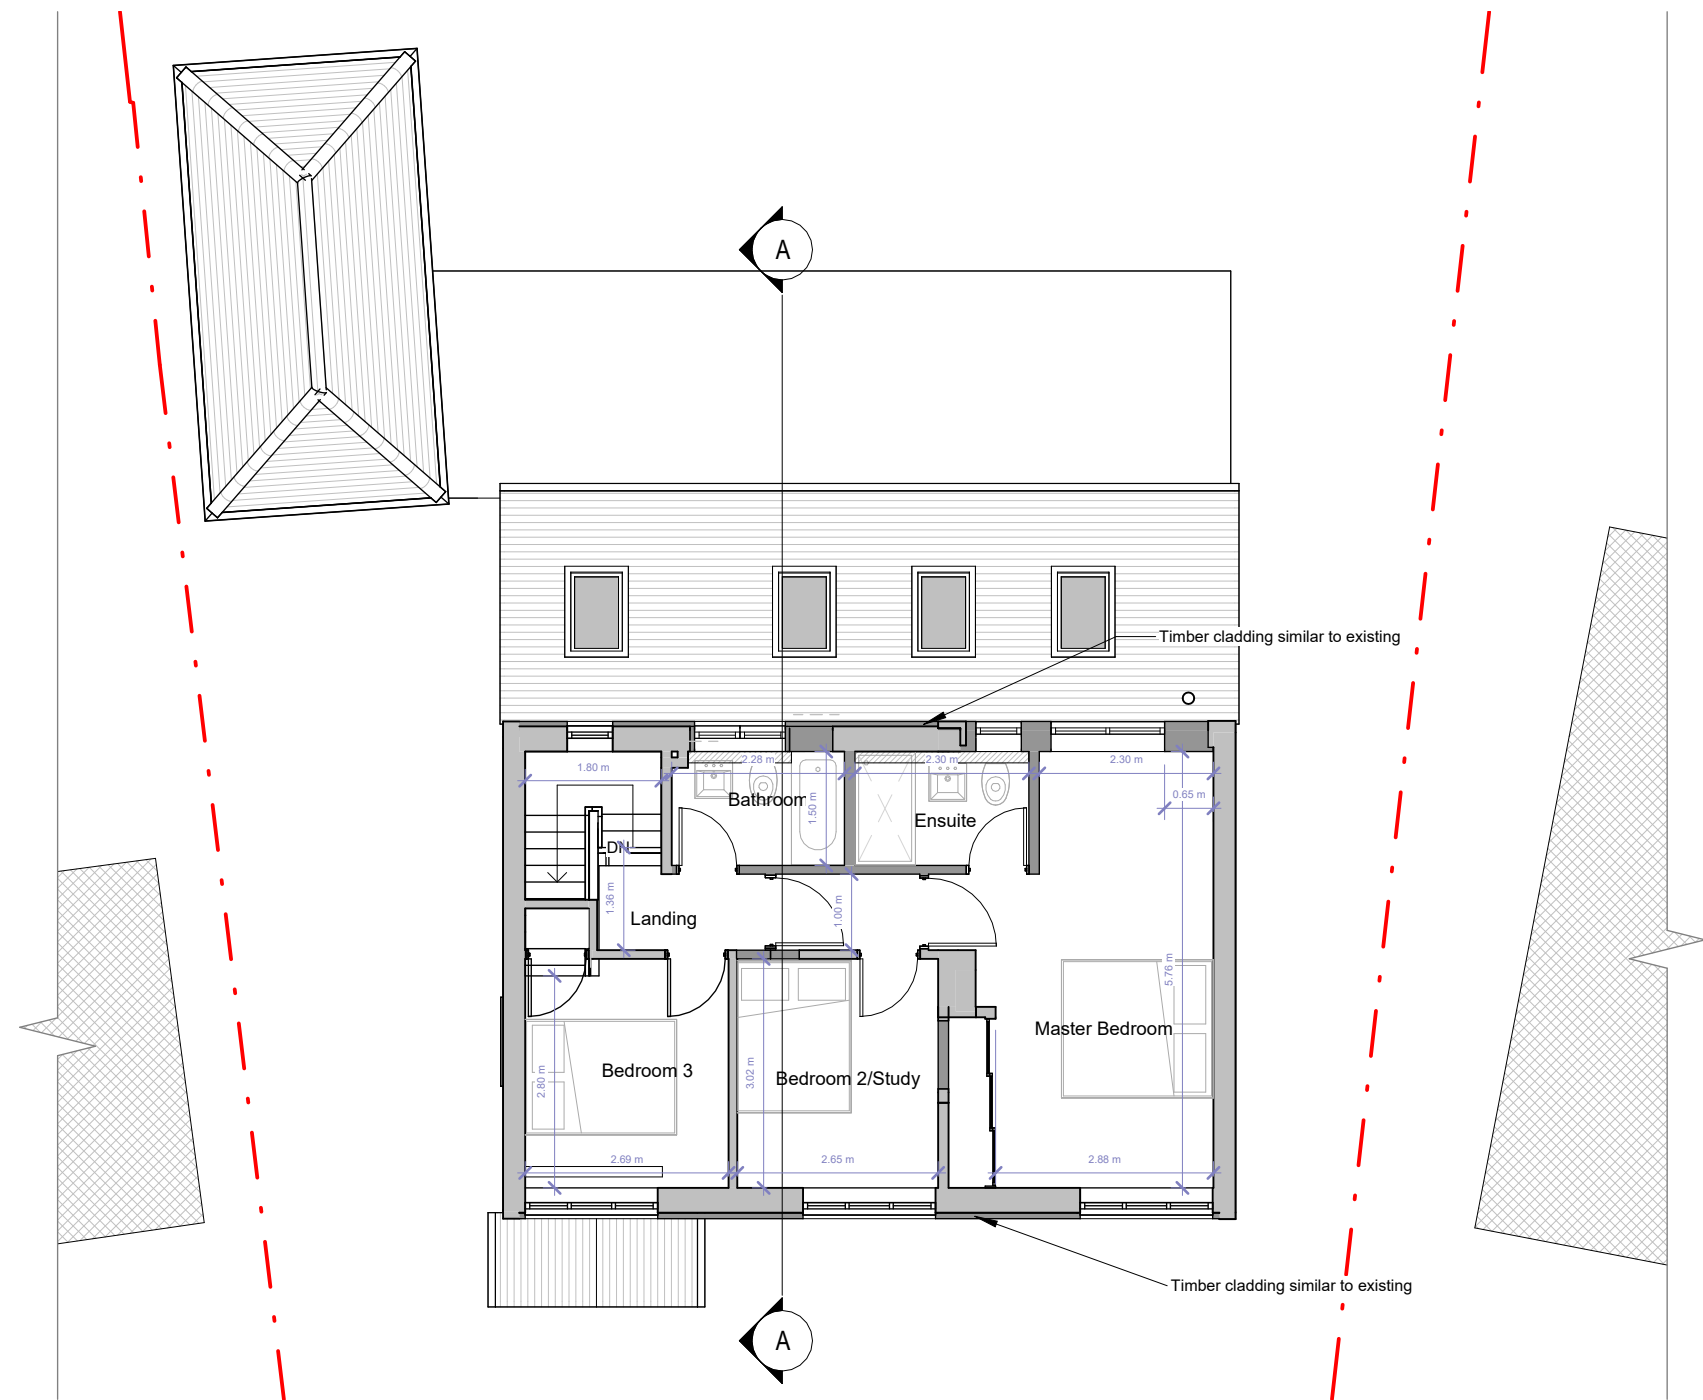

First Floor



FLUENT
ARCHITECTURAL DESIGN SERVICES
TEL: 0800 043 8838
E-MAIL: INFO@FLUENT-ADS.CO.UK
WEB: FLUENT-ADS.CO.UK

13 Fair View Horsham

Proposed Floor Plans

Scale @ A3
1 : 100

Date
17.03.2025

 
Drawn by
SZ

Drawing number
P.M.501

Project number
2369

Rev
L

Key:



No.	Description	Date
F	Revision 8	23.02.26
G	Revision 9	05.03.26
H	Revision 10	12.03.26
I	Revision 11	25.03.26
J	Revision 12	12.05.26
K	Revision 13	05.06.26
L	Revision 14	29.06.26