
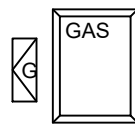
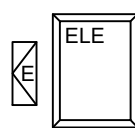
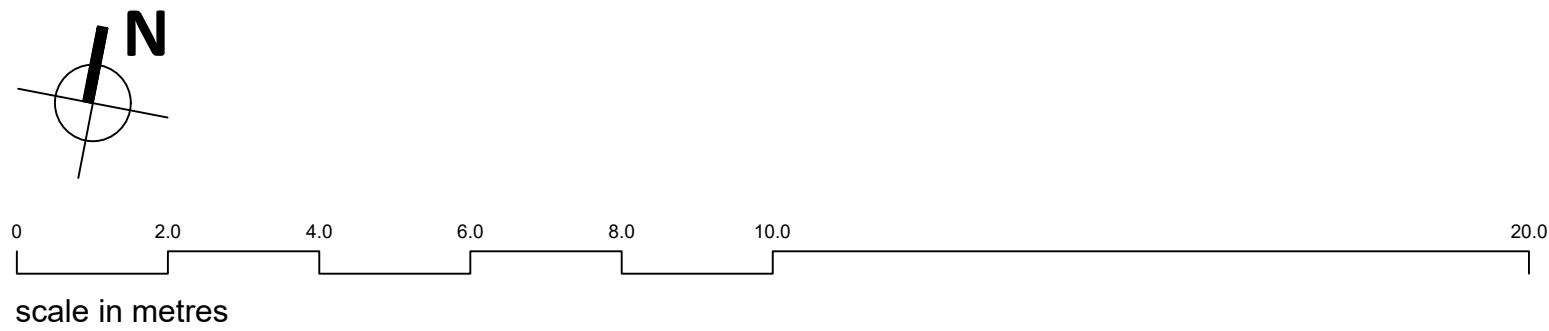


LEGEND

- GAS
- ELE
- BOILER
- CONSUMER UNIT
- MEGAFLOW UNIT
- RADIATOR
- HEATED TOWEL RAIL
- DIRECTION OF ROOF FALL
- INSPECTION CHAMBER
- SOIL VENTILATION STACK
- STUB STACK
- RAINWATER PIPE
- GULLEY
- WATER FEED/OR TAPS

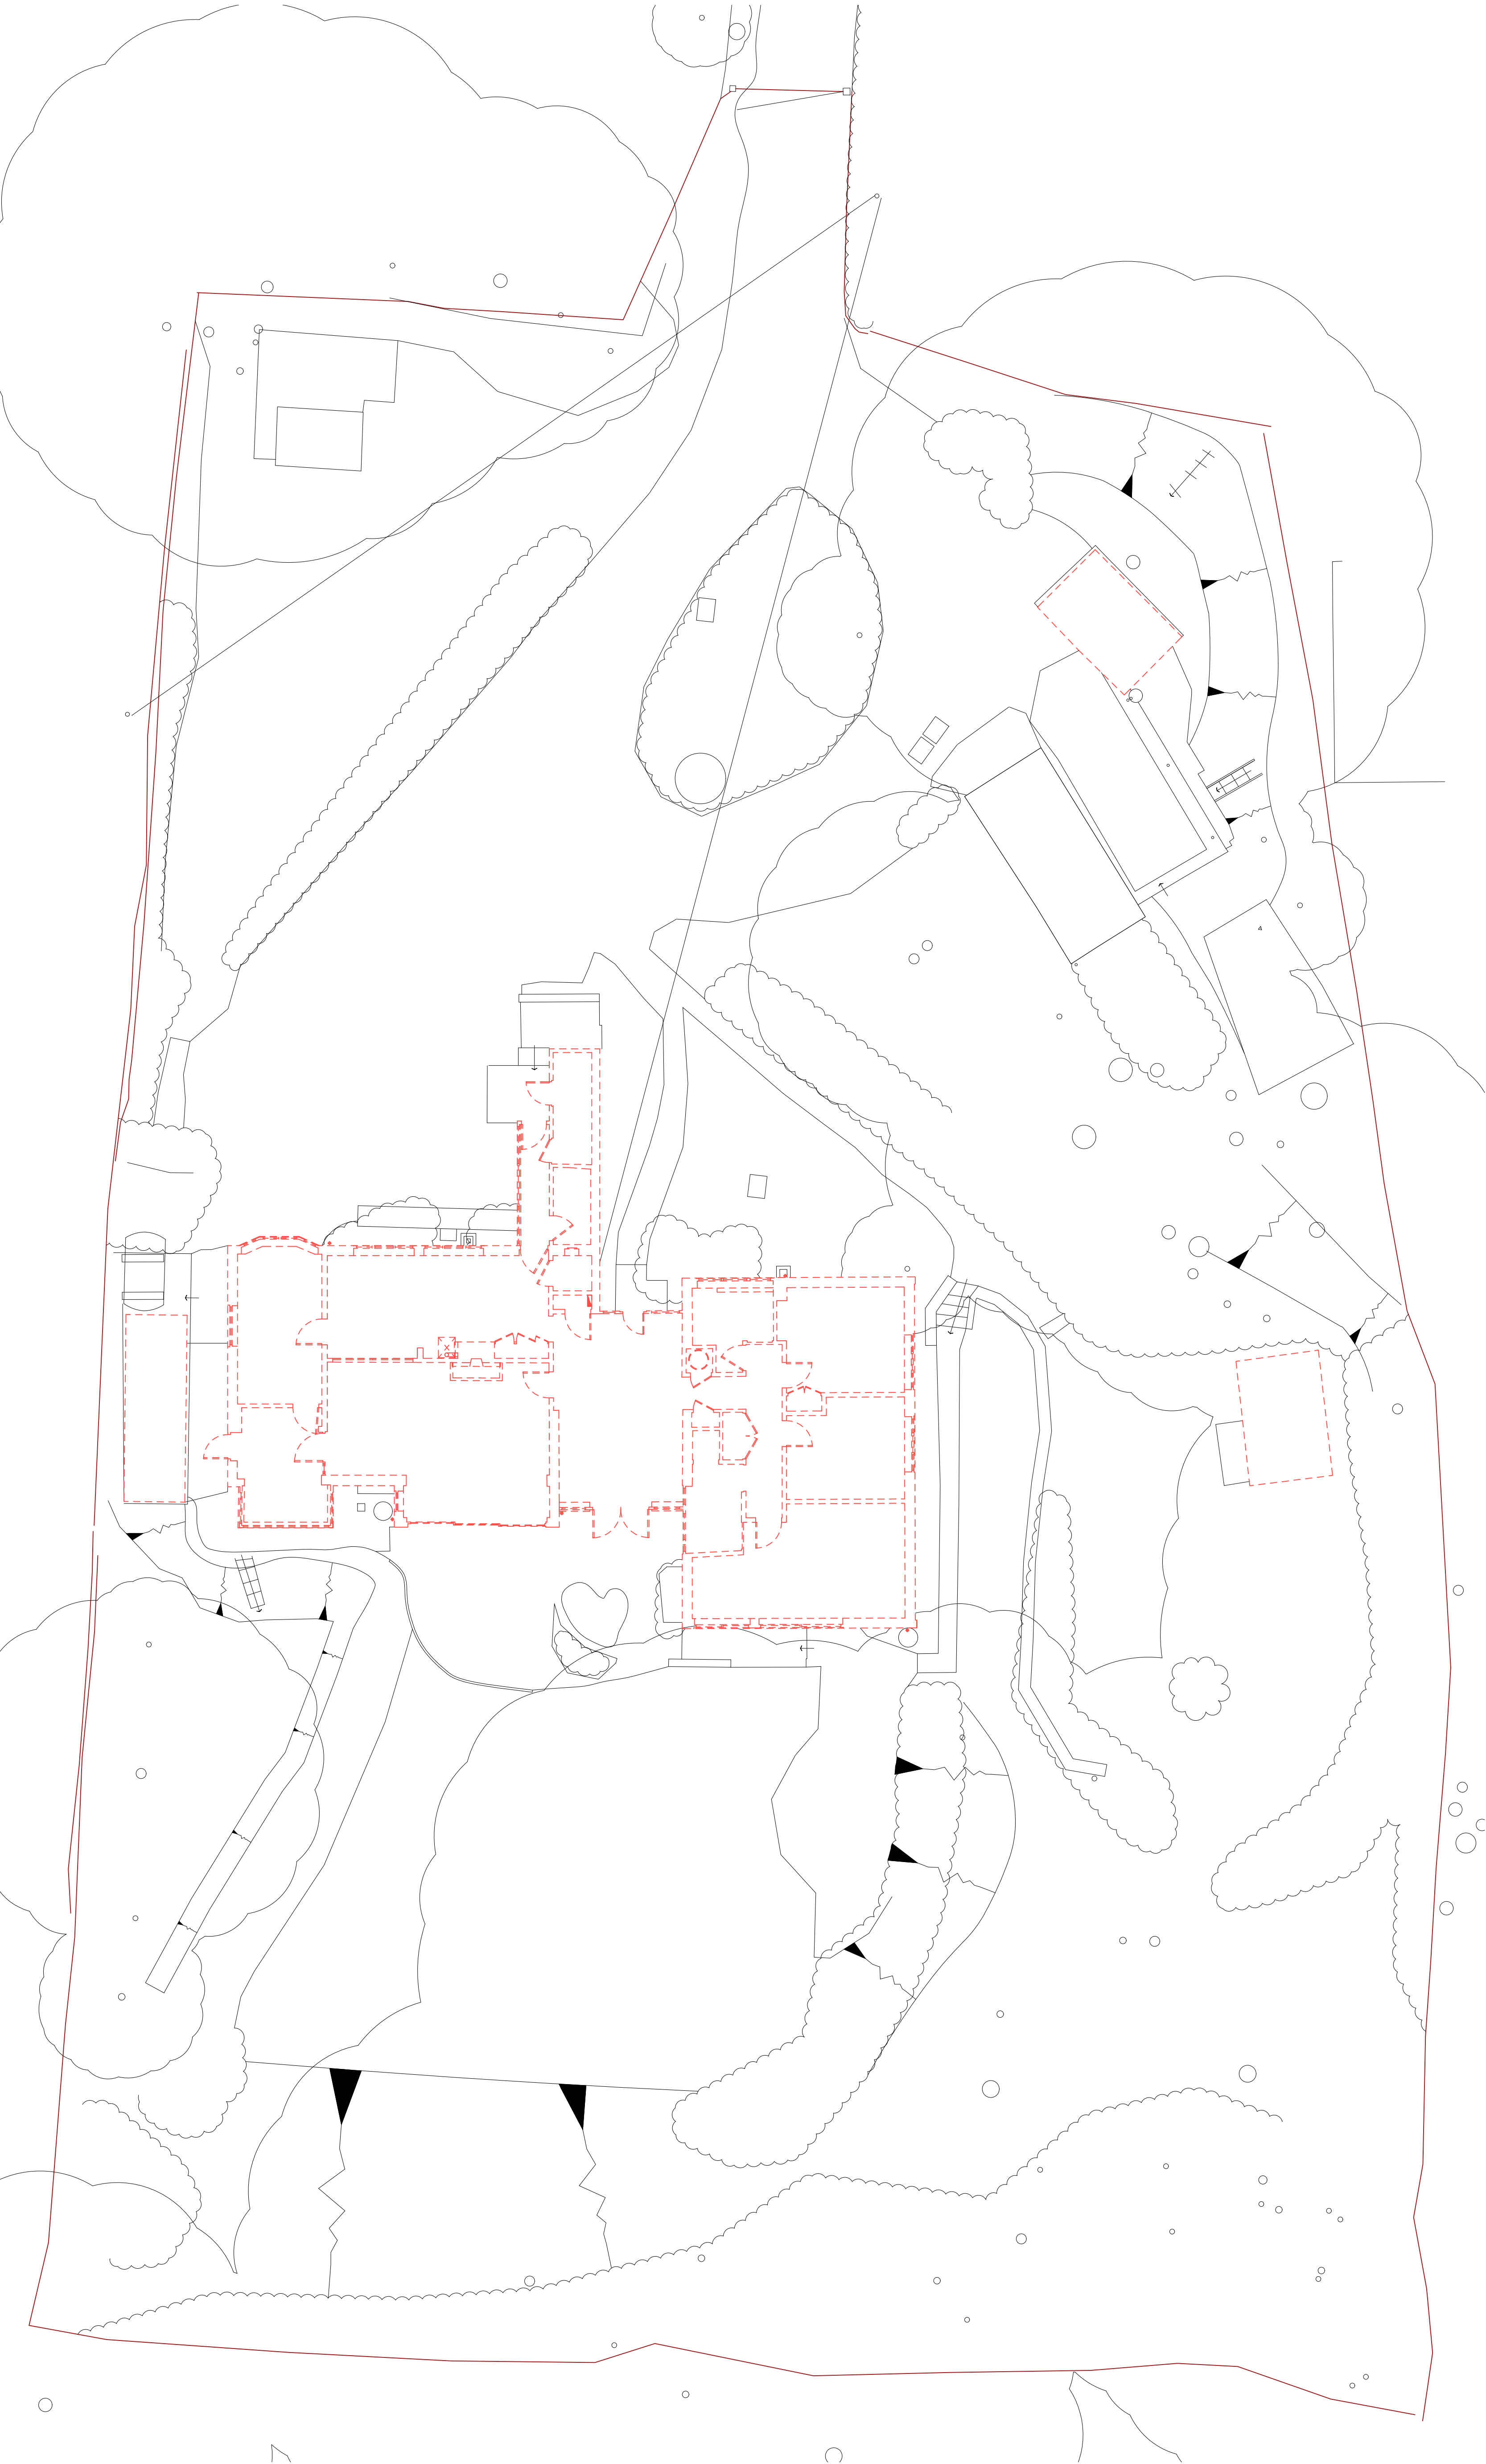

**LIFE
SIZE**

01273 860 744
studio@lifesizearchitecture.co.uk
www.lifesizearchitecture.co.uk

description: date: revision:

PROPOSED DEMOLITION SITE PLAN

project no: **24019GL** drawing no: **PR02**

drawing status:
PLANNING

client:
ANNALIZE VAN ZYL
project:
LITTLE FAIRSEAT, GEORGES LANE, STORRINGTON, RH20 3JH
DEMOLITION AND REBUILD
date: 29/01/26 scale: 1:100 @ A1 drawn: CD checked: RB