 
 
 


LEGEND

- 

 
GAS METERS
- 

 
ELECTRICAL METERS
- 

BOILER
- 

CONSUMER UNIT
- 

MEGAFLOW UNIT
- 

RADIATOR
- 

HEATED TOWEL RAIL
- 

DIRECTION OF ROOF FALL
- 

INSPECTION CHAMBER
- 


SOIL VENTILATION STACK
- 

STUB STACK
- 

RAINWATER PIPE
- 

GULLEY
- 

WATER FEED/DR TAPS

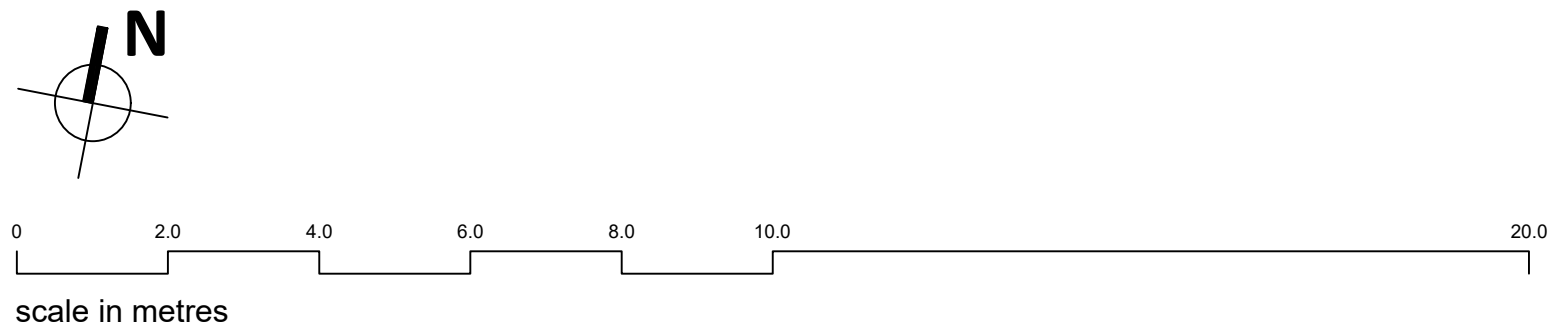

LIFE
SIZE

01273 886 744
studio@lifesizearchitecture.co.uk
www.lifesizearchitecture.co.uk

description: date: revision:

PROPOSED SITE PLAN

project no: 24019GL drawing no: PR04

drawing status: PLANNING

client: ANNALIZE VAN ZYL
project: LITTLE FAIRSEAT, GEORGES LANE, STORRINGTON, RH20 3JH
DEMOLITION AND REBUILD
date: 29/01/26 scale: 1:100 @ A1 drawn: CD checked: RB