


LEGEND

- GAS METERS
- ELECTRICAL METERS
- BOILER
- CONSUMER UNIT
- MEGAFLW UNIT
- RADIATOR
- HEATED TOWEL RAIL
- DIRECTION OF ROOF FALL
- INSPECTION CHAMBER
- SOIL VENTILATION STACK
- STUB STACK
- RAINWATER PIPE
- GULLEY
- WATER FEED/OR TAPS

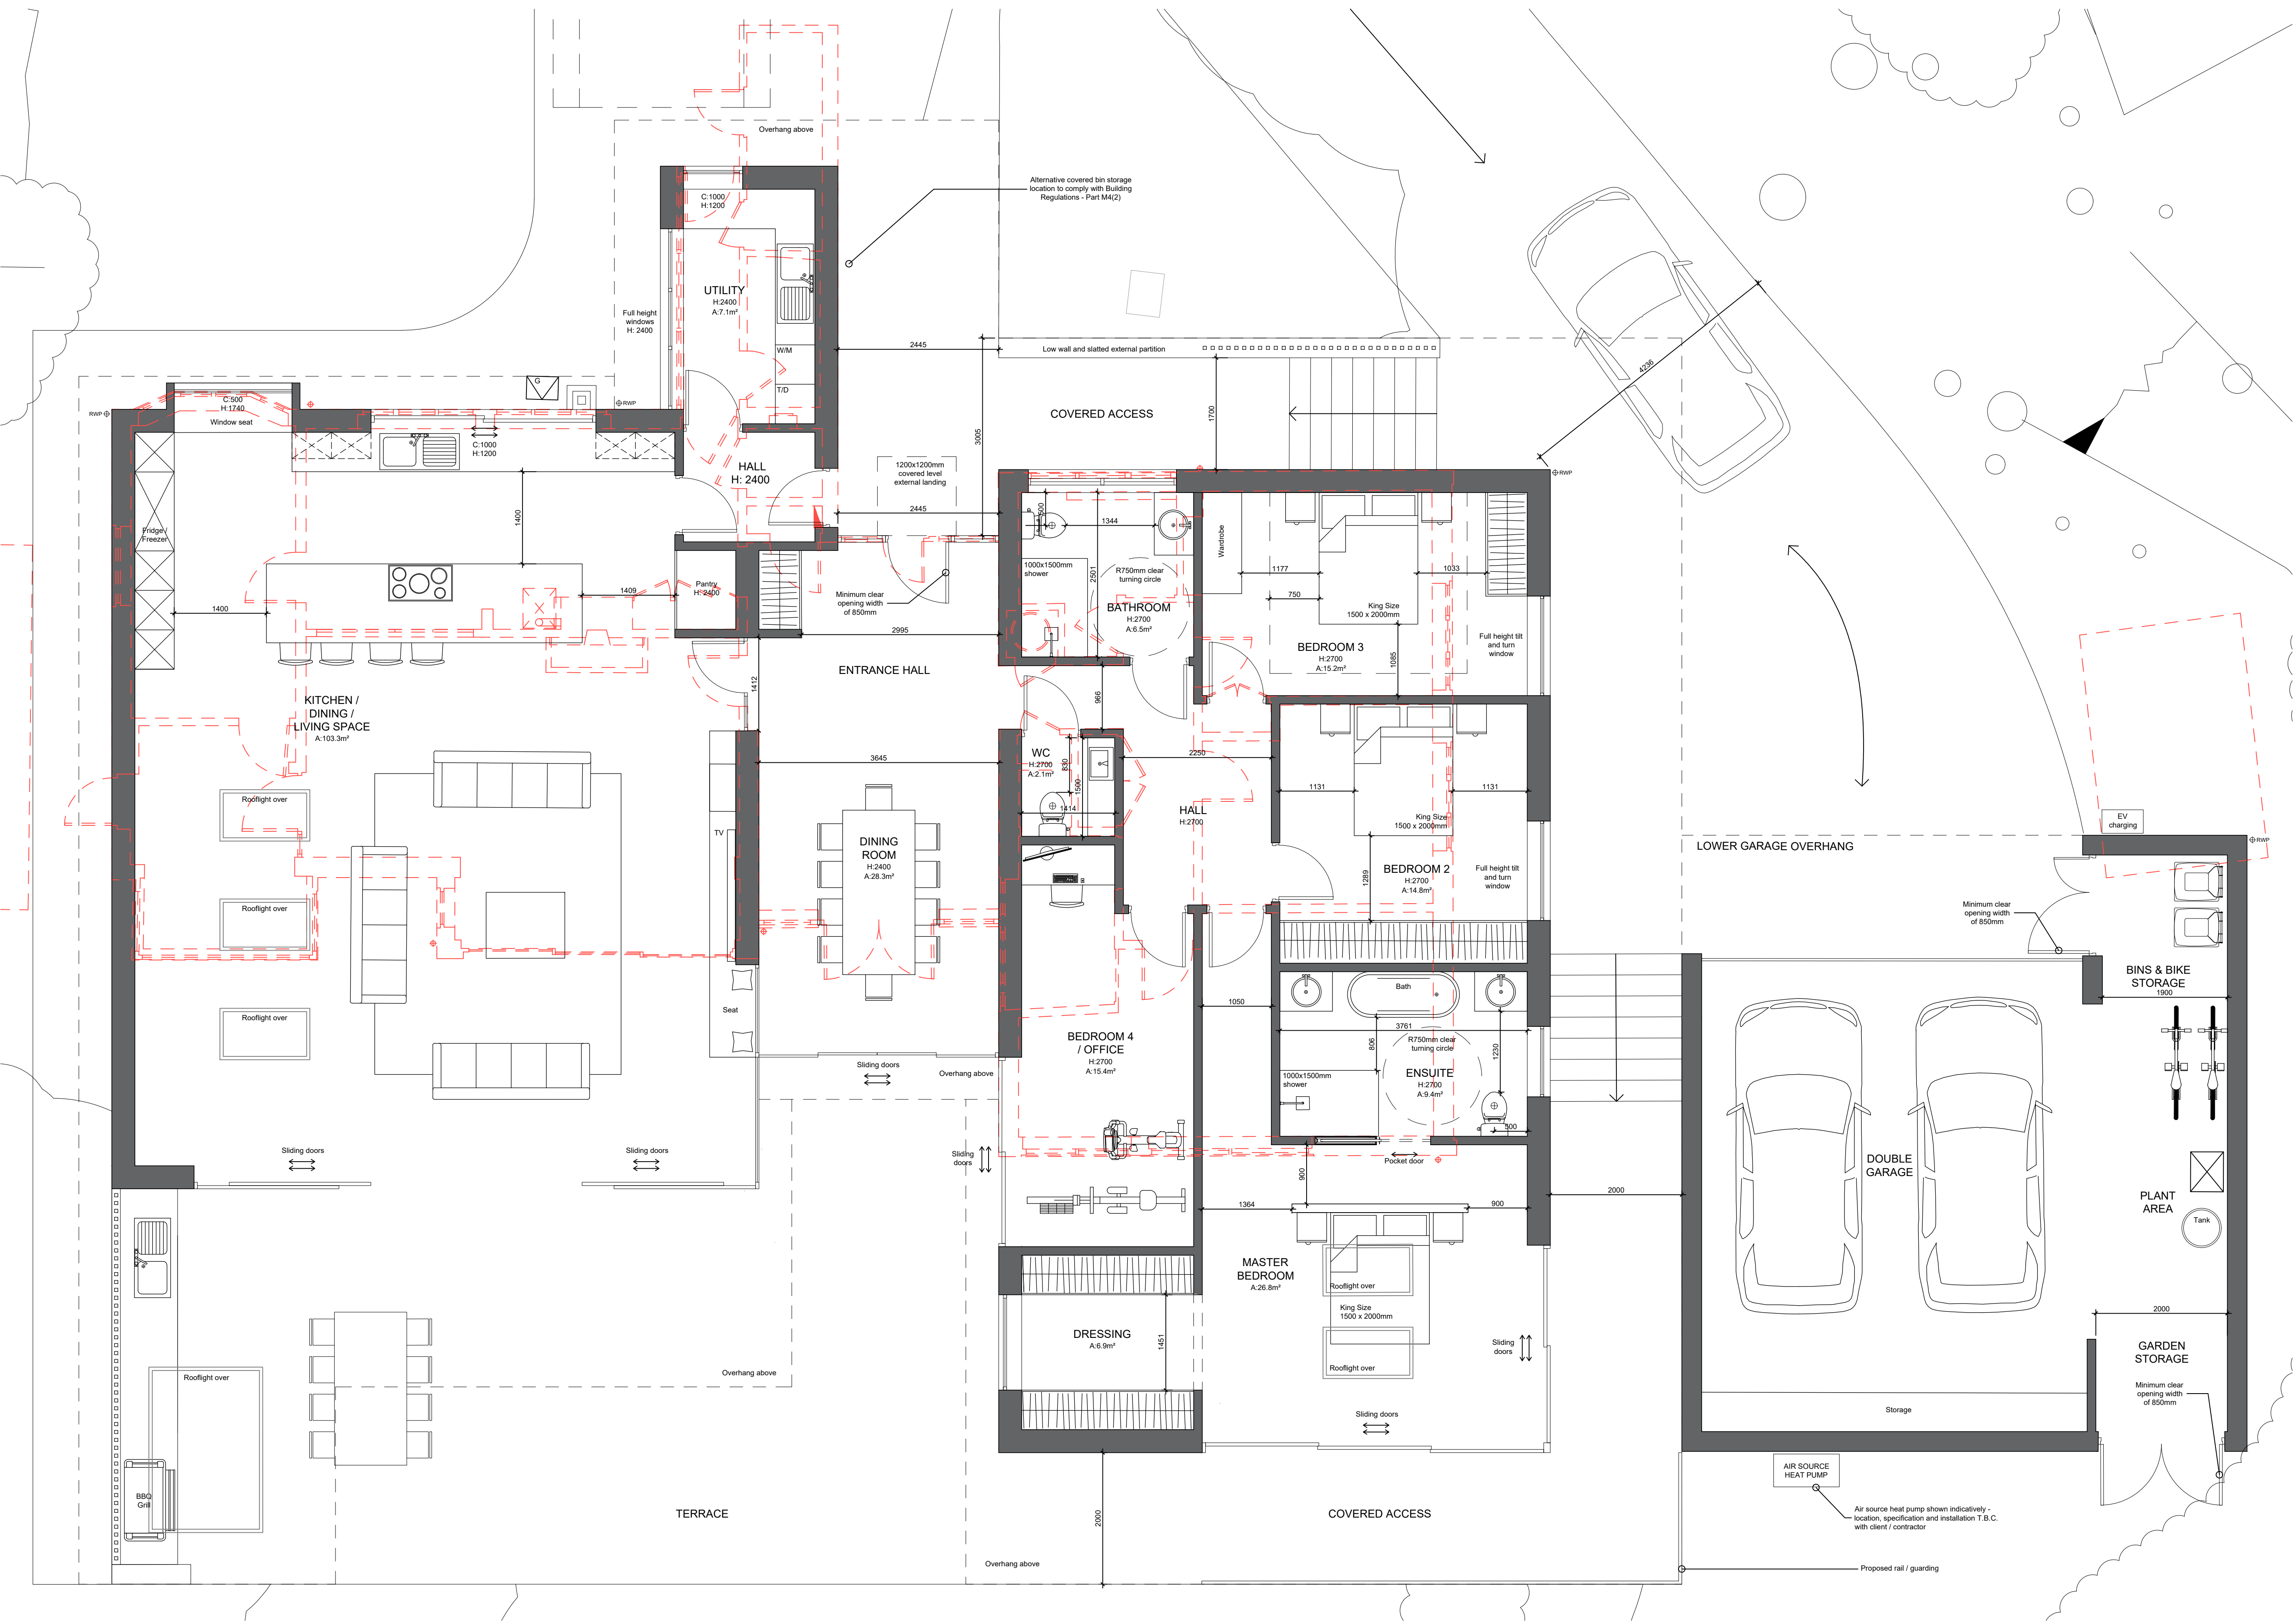

0 1.0 2.0 3.0 4.0 5.0 10.0
scale in metres

PROPOSED GROUND FLOOR PLAN - 1:50 @ A1

LIFE SIZE

01273 586 744
studio@lifesizearchitecture.co.uk
www.lifesizearchitecture.co.uk

title:
PROPOSED GROUND FLOOR PLAN

project no: **24019GL** drawing no: **PR05**

drawing status:
PLANNING

client:
ANNALIZE VAN ZYL
project:
LITTLE FAIRSEAT, GEORGES LANE, STORRINGTON, RH20 3JH
DEMOLITION AND REBUILD

date: 29/01/26 scale: 1:50 @ A1 draw: CD checked: RB