


This drawing shall not be scaled.
Work from the dimensions shown in the drawing or given in the notes and not the dimensions of the drawing itself.
This drawing is to be used as a guide only, please refer to scope of works for specific quantities and details

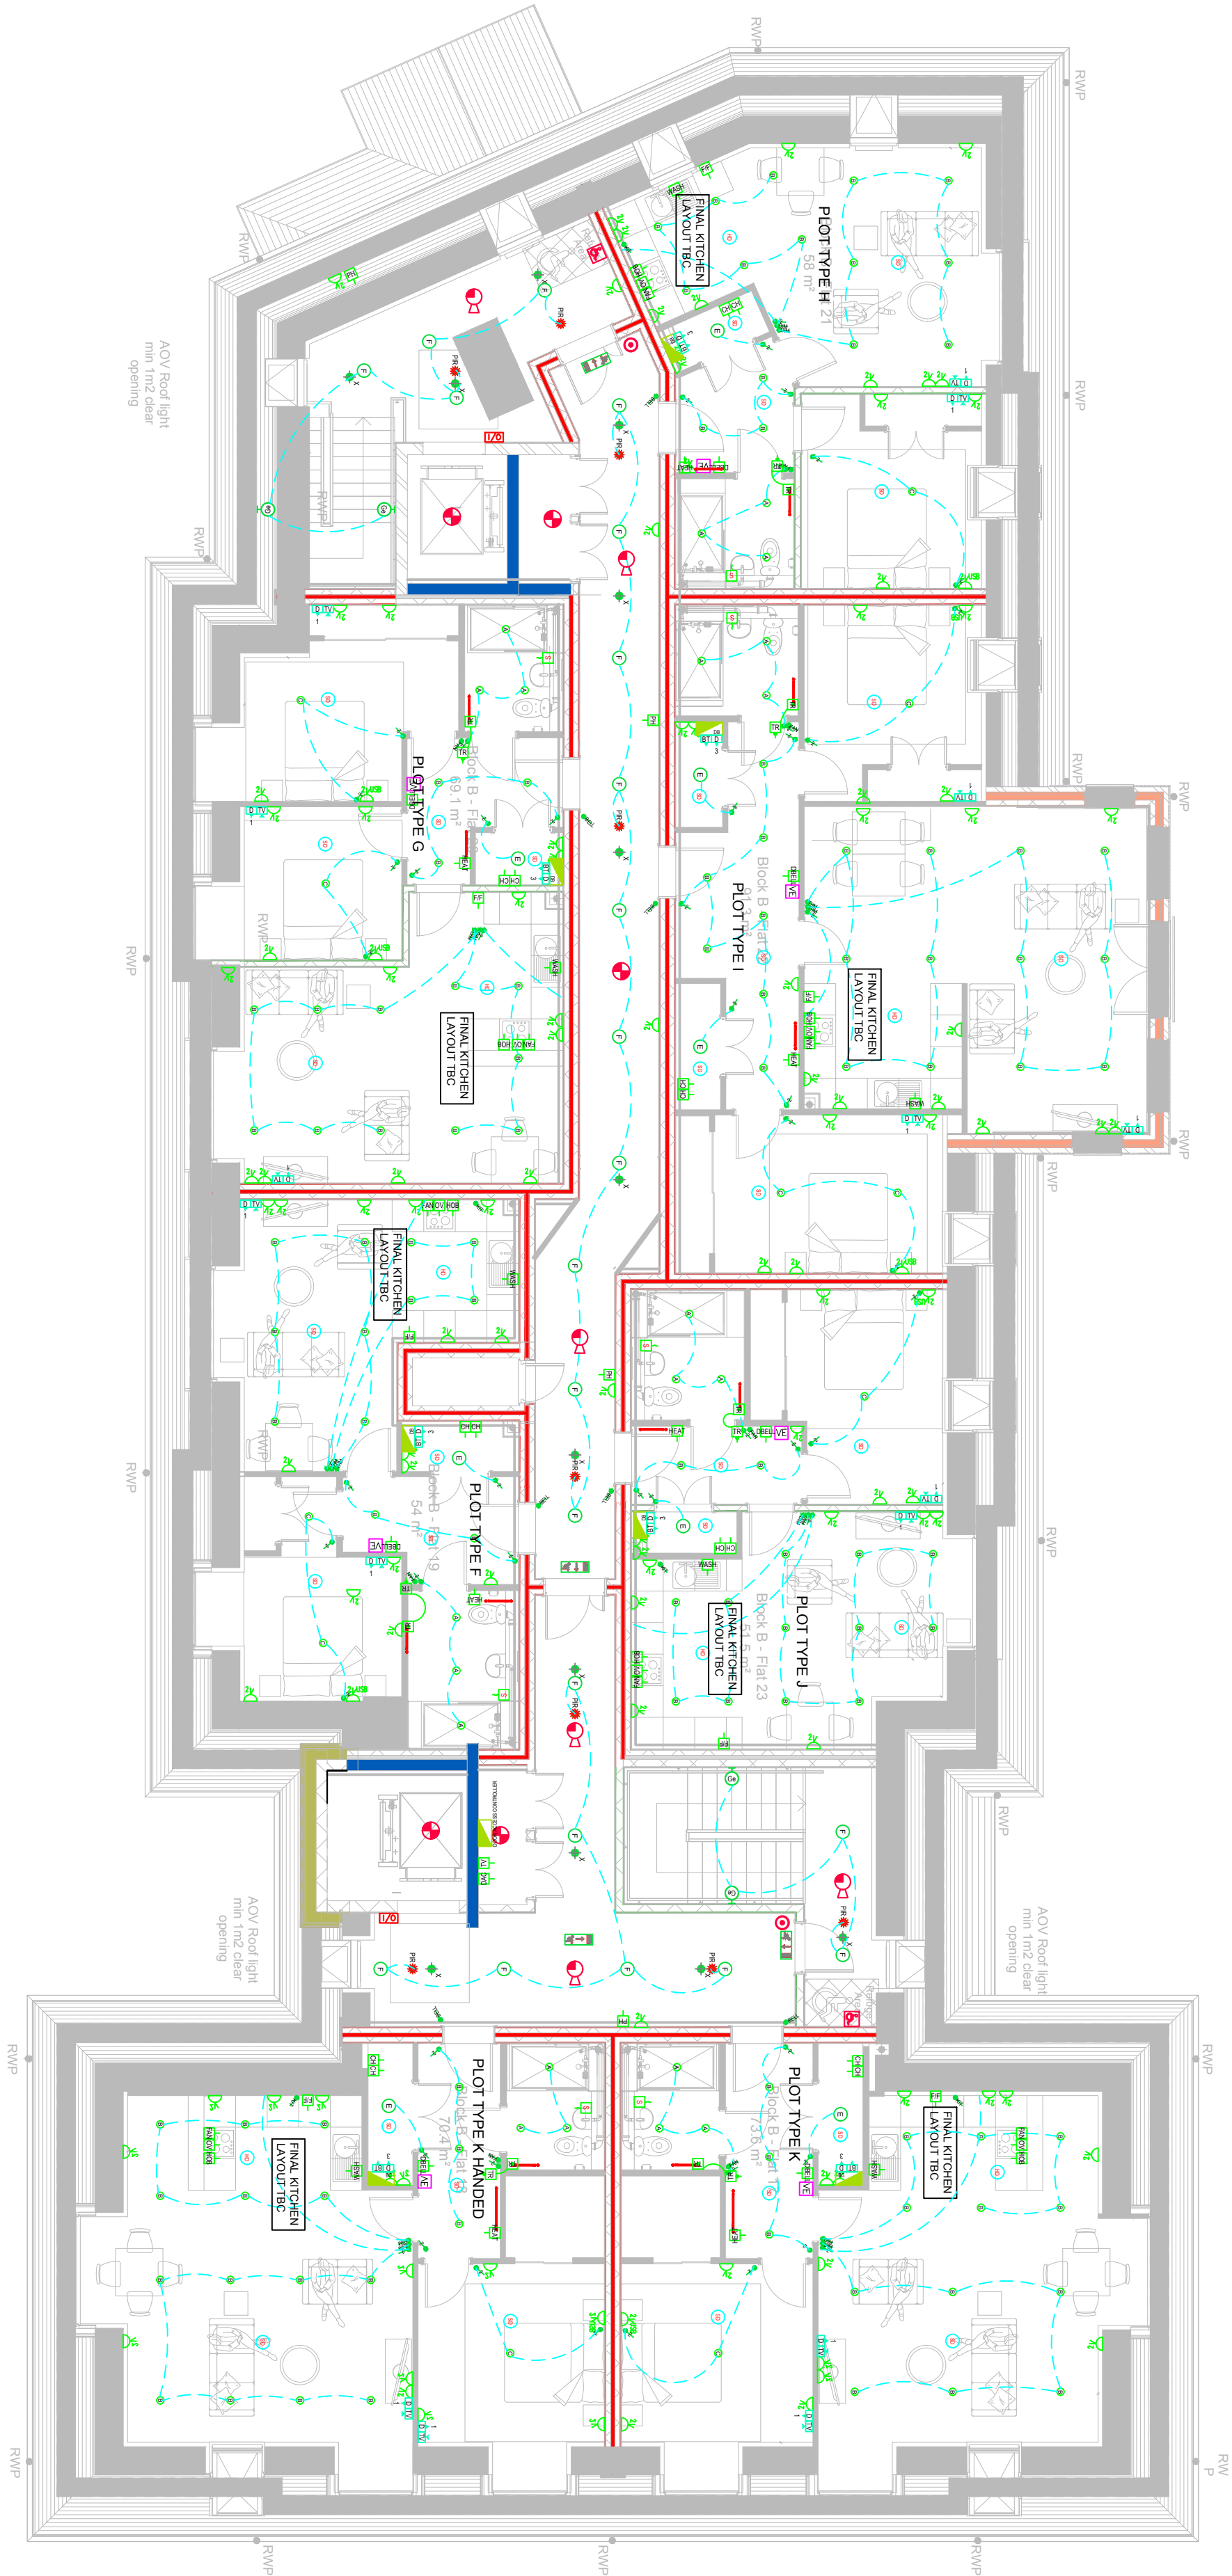

LEGEND:		LUMINAIRES		FIRE ALARM		SECURITY	
SMALL POWER		P rated gu10 fitting e - denotes em, m - denotes microwave, D - denotes dimmable		- Sounder		CCTV Camera	
	- SINGLE SWITCHED SOCKET OUTLET		- denotes em, m - denotes microwave, D - denotes dimmable		- Smoke / Heat Detector / Sounder		- CCTV Camera
	- FIXED CONNECTION UNIT		- denotes em, m - denotes microwave, D - denotes dimmable		- Smoke / Heat Detector / Sounder		- Smoke Alarm / Fire Detector
	- SWITCHED FIXED CONNECTION UNIT		- denotes em, m - denotes microwave, D - denotes dimmable		- Smoke / Heat Detector		- Smoke Alarm / Fire Detector
	- DATA OUTLET		- denotes em, m - denotes microwave, D - denotes dimmable		- Smoke		- Smoke Alarm / Fire Detector
	- TV SOCKET		- denotes em, m - denotes microwave, D - denotes dimmable		- Smoke		- Smoke Alarm / Fire Detector
	- SMOKE DETECTOR		- denotes em, m - denotes microwave, D - denotes dimmable		- Smoke		- Smoke Alarm / Fire Detector
	- HEAT DETECTOR		- denotes em, m - denotes microwave, D - denotes dimmable		- Smoke		- Smoke Alarm / Fire Detector
	- DISTRIBUTION BOARD		- denotes em, m - denotes microwave, D - denotes dimmable		- Smoke		- Smoke Alarm / Fire Detector
	- Flush mounted emergency light fitting		- denotes em, m - denotes microwave, D - denotes dimmable		- Smoke		- Smoke Alarm / Fire Detector
	- Flush mounted fire detector		- denotes em, m - denotes microwave, D - denotes dimmable		- Smoke		- Smoke Alarm / Fire Detector

LEVEL 2 SECOND FLOOR

CDM Regulations:
In addition to any information included in this drawing or the model from which it is derived, refer also to the project CDM Risk Register for information on residual risks

General Notes:
The drawing does not necessarily show all the information required to interpret the design intent or the construction details.
The drawing contains information from more than one source and must be read in conjunction with all other drawings and specifications shall be brought to our attention.

Project Notes:

DENOTES

NC = NURSE CALL
OS = OUTSIDE
CV = CEILING VOID OR MOUNTED
HT = HOT TROLLY
SD = SMOKE DAMPER
FA = FIRE ALARM
AC = AIR CONDITIONING
HM = HEATING MANIFOLD
TH = TRACE HEATING
AH = AIR HANDLING UNIT
WP = WATER PUMP
SP = SPRINKLER PUMP
HOB = KITCHEN HOB
EXT = KITCHEN EXTRACT
OVE = KITCHEN OVEN
DBELL = DOOR BELL CHIME
F/F = FRIDGE FREEZER
DISH = DISHWASHER
WASH = WASHING MACHINE
FAN = EXTRACT FAN
CH = CENTRAL HEATING SYSTEM
PH = FUTURE PANEL HEATER POSITION
DRP = DISABLED REFUGE PANEL
DA = DOOR ACCESS CONTROLLER

NO	FOR SUBMITTAL	TA	RM	RM	NOTES
Name	Description	Design	Reviewed	Approved	Date
REVISIONS:					

morelec (UK) Ltd
UNIT 4 BOURNEOUTH BUSINESS PARK,
BOURNEOUTH
T. 01675 333333
WWW.MORELEC.NET

ARCHITECT:
CORSTORPHINE & WRIGHT

CLIENT:
PARSONS AND JOYCE

PROJECT TITLE:
SUSSEXDOWN BLOCK B

DRAWING TITLE:
SECOND FLOOR SMALL POWER
AND LIGHTING LAYOUT

FOR SUBMITTAL

PERSON RESPONSIBLE FOR:			
Design:	TA	Review:	RM
Authoring:	RM	Issued:	RM
Project No:	Date:	Scale:	At:
PAJ-SD-BB-24-11	24 NOV 2025	1:100	
DRAWING NUMBER:	Revision:		
PAJ-SD-BB-24-11-2-2ND-SPLT-	04		