


A1 This drawing shall not be scaled. Work from the dimensions shown in the drawing or given in relevant specifications. This drawing is to be used as a guide only, please refer to scope of works for specific quantities and details

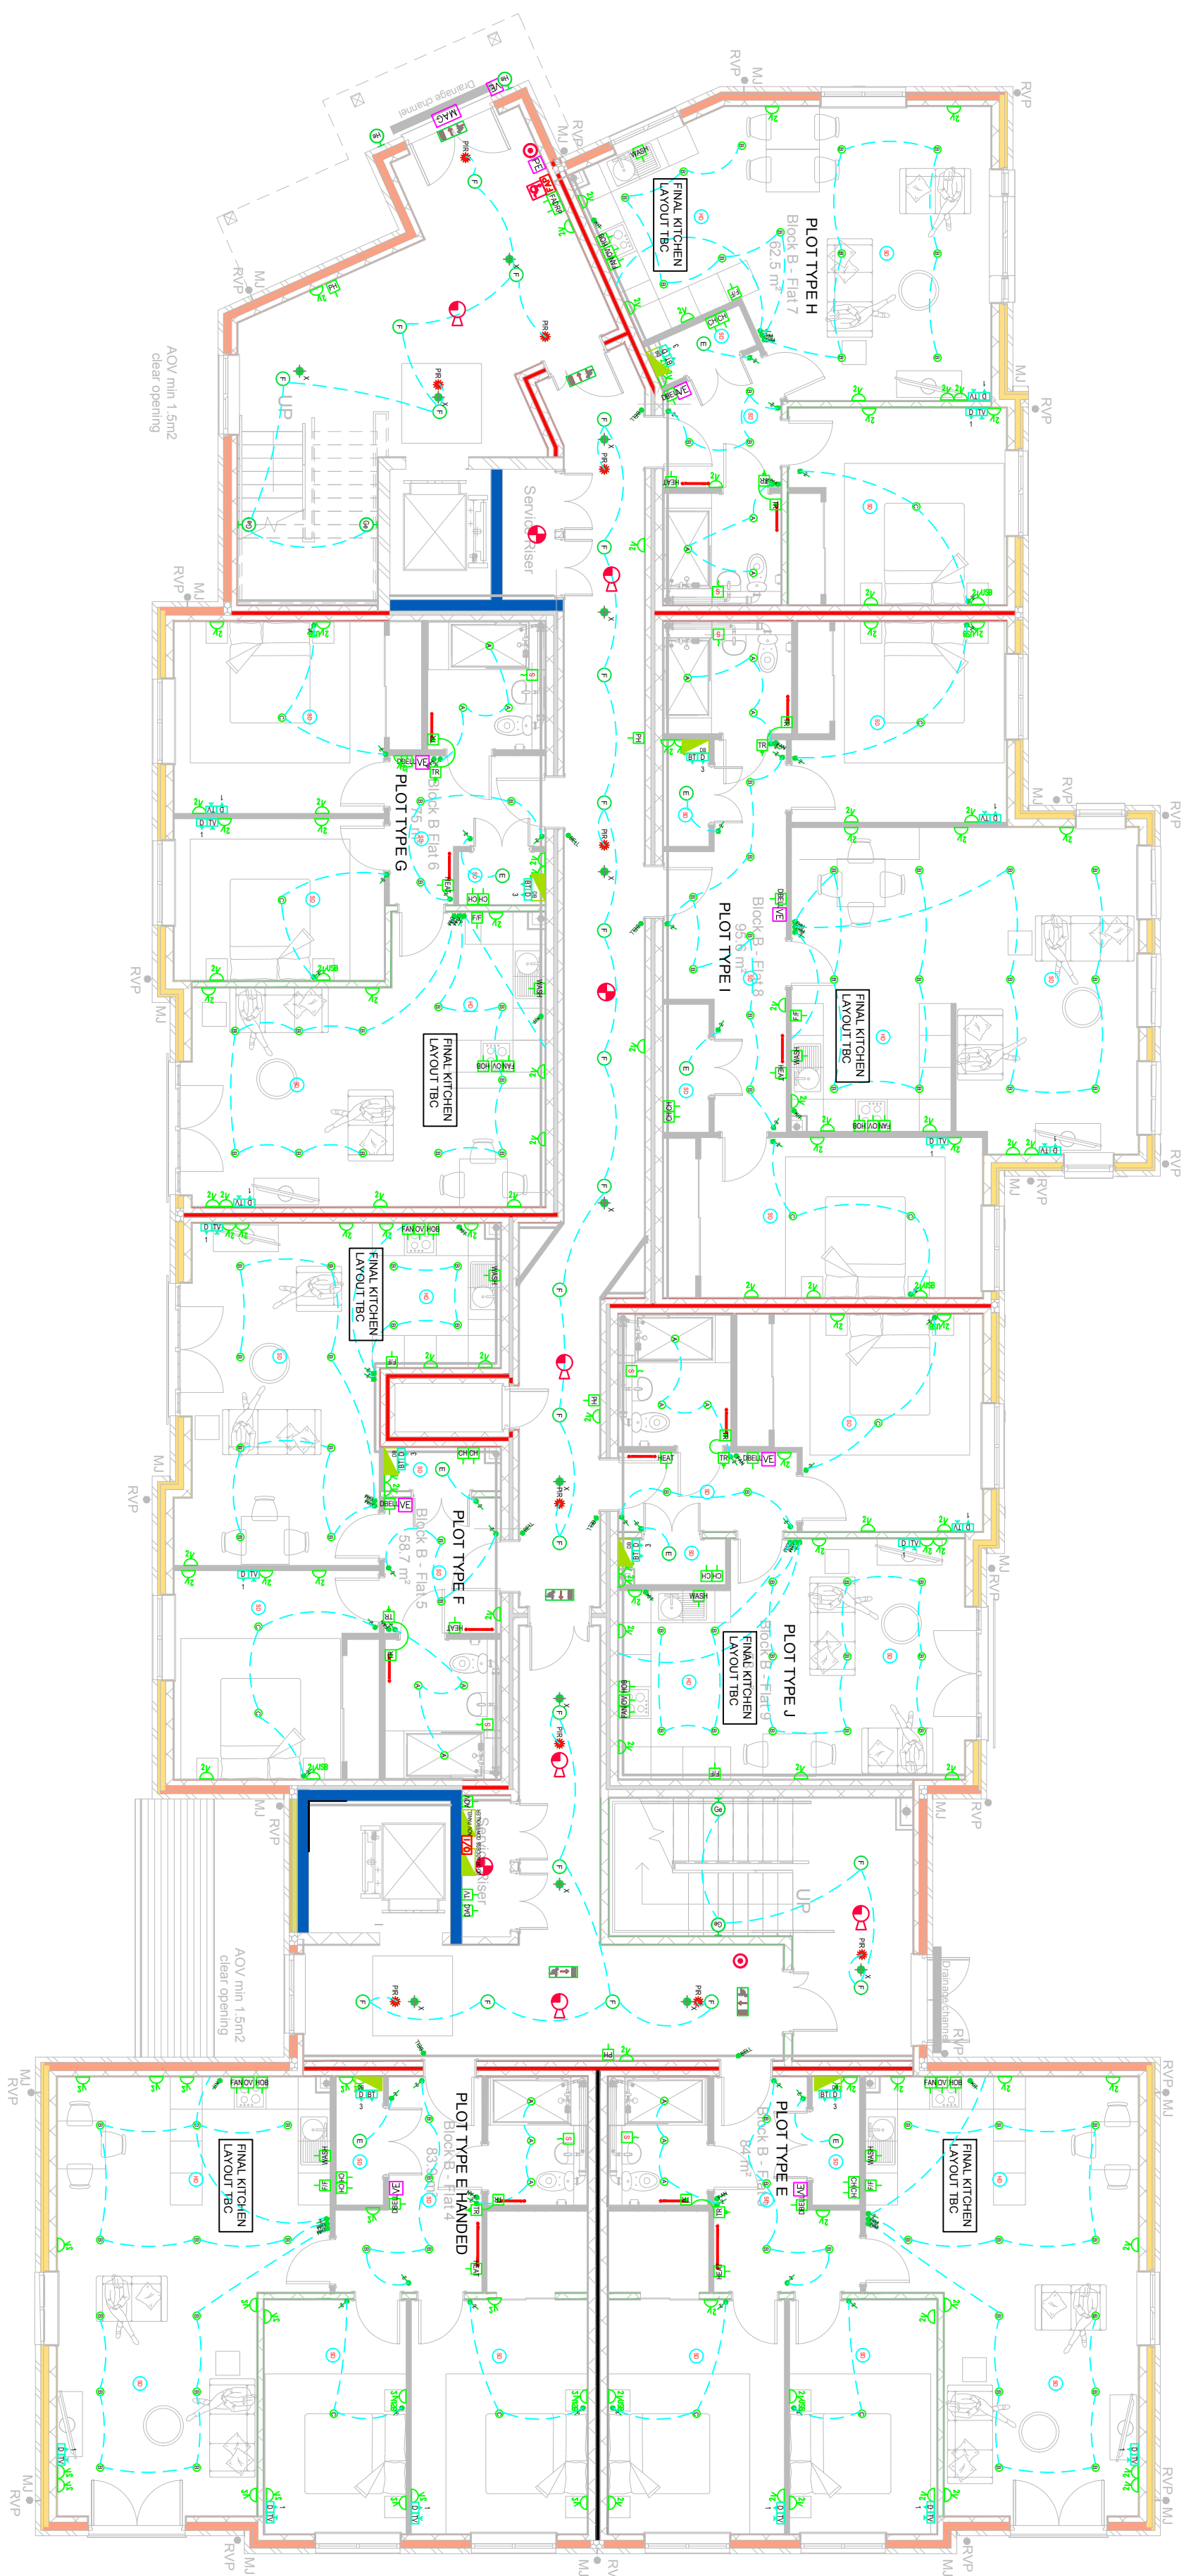

LEGEND:

SMALL POWER

- DOUBLE SWITCHED SOCKET OUTLET
- SINGLE UNSWITCHED SOCKET OUTLET
- FIRED CONNECTION UNIT
- SWITCHED FIRED CONNECTION UNIT
- RJ45 DATA OUTLET
- TV SOCKET
- SMOKE DETECTOR
- HEAT DETECTOR
- DISTRIBUTION BOARD

LUMINARIES

- IP rated gu10 fitting e - denotes sm, m - denotes microwave, D - denotes dimmable
- gu10 fitting e - denotes sm, m - denotes microwave, D - denotes dimmable
- Pendant e - denotes sm, m - denotes microwave, D - denotes dimmable
- Surface mounted wall / ceiling light e - denotes sm, m - denotes microwave, D - denotes dimmable
- Surface mounted wall / ceiling light 24 style fitting e - denotes sm, m - denotes microwave, D - denotes dimmable
- Recessed / mounted ceiling control light, fitting e - denotes sm, m - denotes microwave, D - denotes dimmable
- Surface mounted wall corner light, fitting e - denotes sm, m - denotes microwave, D - denotes dimmable
- Surface mounted running rain exit box
- Flush mounted emergency light fitting
- Flush mounted pir detector

FIRE ALARM

- [illegible]

SECURITY

- | | |
|-----------------------------|--------------------------------------|
| VE | Video entry panel / phone |
| KEEP | electronic keep to a single door |
| MAG | Magnets |
| IAP | Security Alarm Panel |
| SAB | Security Alarm Source |
| PE | Push to exit button |
| KF | Security Alarm / Door Access Key Pad |
| Green circle with checkmark | Security Alarm PIR detector |
| Green circle with X | Door Contact |
| Blue bell icon | CCTV Camera |

LEVEL 0

GROUND FLOOR

CDM Regulations

In addition to any information included in this drawing or the model from which it is derived, refer also to the project CDM Risk Register for information on residual risks

General Notes:

- The drawing does not necessarily show all the information needed to interpret the design intent or the construction details.
- The drawing contains information from more than one source and must be read in conjunction with all relevant specifications.
- Any apparent drafting errors and differences between other drawings and specifications shall be brought to our attention.

DENOTES

- NC = NURSE CALL
OS = OUTSIDE
CY = CEILING VOID OR MOUNTED
HT = HOT TROLLY
SD = SMOKE DAMPER
FA = FIRE ALARM
AC = AIR CONDITIONING
HM = HEATING MAINFOLD
TH = TRACE HEATING
AH = AIR HANDLING UNIT
WP = WATER PUMP
SP = SPRINKLER PUMP
HOB = KITCHEN HOB
EXE = KITCHEN EXTRACT
OVE = KITCHEN OVEN
DBELL = DOOR BELL CHIME
F/F = FRIDGE FREEZER
DISH = DISHWASHER
WASH = WASHING MACHINE
FAN = EXTRACT FAN
CH = CENTRAL HEATING SYSTEM
PH = FUTURE PANEL HEATER POSITION
DRP = DISABLED REFUGE PANEL
DA = DOOR ACCESS CONTROLLER

Index	Description	Designed	Reviewed	Author/Date	NOV
04	FOR SUBMITTAL	TA	RM	RM	NOV

REVISIONS:

REVISIONS:

morelec (UK) Ltd
UNIT 1, BOURNEMOUTH BUSINESS PARK,
SOUTHCOTE ROAD,
BOURNEMOUTH
BH1 3SJ
T 01202222980
www.morelec.net

ARCHITECT:
CORSTORPHINE & WRIGHT

CLIENT:
PARSONS AND JOYCE

PROJECT TITLE:
SUSSEXDOWN BLOCK B

DRAWING TITLE:
GROUND FLOOR SMALL POWER
AND LIGHTING LAYOUT

PERSON RESPONSIBLE FOR:			
Design:	Review:	Authorising Issue	
TA	RM	RM	
Project No:	Date:	Scale & Alt:	
P&L-SB-BB-24-11	24 NOV 2025	1:100	
DRAWING NUMBER:			Revision
P&L-SB-BB-24-11-L0-GF-SPL-T-			04