


- The contractor must verify all dimensions on site before any works are undertaken, discrepancies are to be reported to the project architect/designer for clarification.
- All works will be carried out in accordance with the SUPERDRUG INFO document & are to comply with the tenants fit out guidelines following landlords approval.
- HVAC, M&E layouts are indicative & must be verified with the relevant contractor before commencement of work.
- All works to be carried out in accordance with the fire strategy and fire cert application schedule produced by the landlord team issued at tender.
- The existing/proposed sprinkler system is to be assessed by contractor to ensure the system is in compliance with building regs part B.
- This drawing remains the property of ASHWATSON/SUPERDRUG & may not be reproduced in any way without prior consent.

 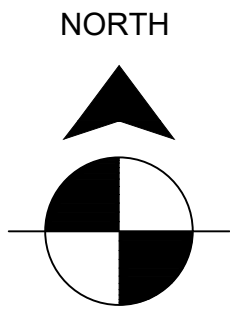


Key


- Site boundary line
- Advertisement Line



Location
Scale 1:1250



Block
Scale 1:500

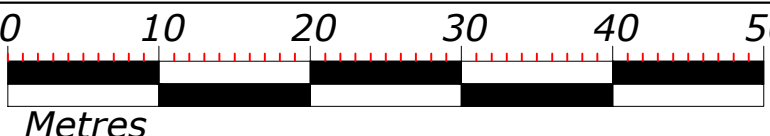

Photograph #1
Front Elevation - LHS



Photograph #2
Front Elevation - RHS

DRAWING TITLE				
Location / Block Plan				
DRAWING NUMBER				REVISION
AM26 9120 - 001				-
SCALE	DATE	DRAWN	CHECKED	
As shown @ A1	03/12/25	DS	-	
PROJECT				
30 West Street, HORSHAM, West Sussex, RH12 1PB				

STATUS

L3