


LEGEND OF LUX LEVELS	
	LINE DENOTES 1.0 LUX
	LINE DENOTES 2.0 LUX
	LINE DENOTES 5.0 LUX
	LINE DENOTES 10.0 LUX
	LINE DENOTES 15.0 LUX
	LINE DENOTES 20.0 LUX
	LINE DENOTES 30.0 LUX

LEGEND OF SYMBOLS	
SYMBOL	DESCRIPTION
	MAGNETIC DOOR LOCK
	GREEN BREAKGLASS C/W ANTI TAMPER COVER
	KEYPAD – ACTISE BLACK STANDALONE SURFACE MOUNTED KEYPAD
	PASSIVE EV CHARGE LOCATION DUCTS C/W DRAW ROPES ARE TO BE PROVIDED TO THESE POSITIONS CAPPED OFF AT GROUND LEVEL
	2No 7.4kW TWIN CAR CHARGING POINTS WITH EARTH STAKE

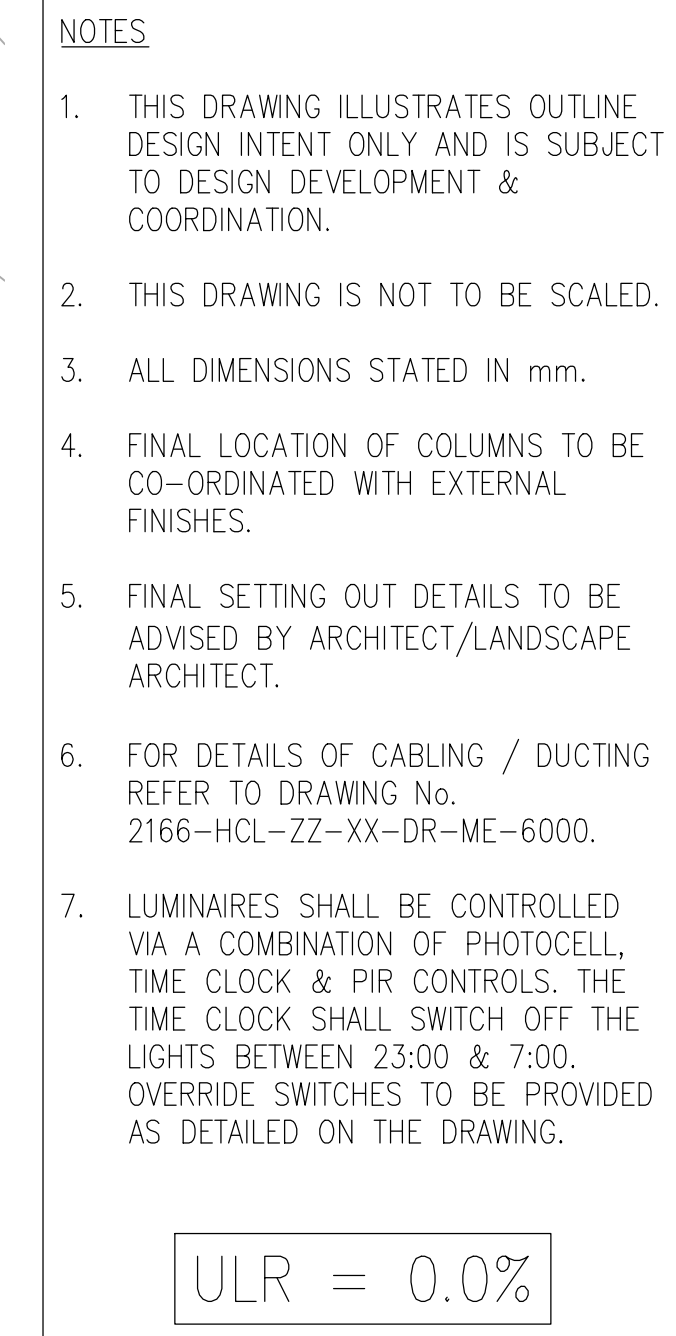

C01	08.05.25	i) ISSUED FOR CONSTRUCTION ii) SITE PLAN UPDATED iii) LUMINAIRE SCHEDULE DESCRIPTIONS UPDATED	TB
P04	16.04.25	i) LUX PLOT UPDATED FOLLOWING PLANNERS COMMENTS ii) LUMINAIRE REFERENCES AMENDED iii) MINOR UPDATES TO LUMINAIRE POSITIONS	TB
P03	13.02.25	UPDATES AS CLOUDED	DL
P02	11.02.25	UPDATES AS CLOUDED	DL
P01	29.01.25	ISSUED FOR COMMENT	DL
REV	DATE	DETAILS OF REVISION	BY



CLIENT
HIGHWOOD CONSTRUCTION
(BARCHESTER HEALTHCARE)

PROJECT
PROPOSED 60-BED CARE HOME
STORRINGTON ROAD
WEST SUSSEX, RH20 4AG

DRAWING TITLE
ELECTRICAL SERVICES
EXTERNAL ELECTRICAL LAYOUT

Issue Status							
FOR CONSTRUCTION							
Original Size A0		Scale 1:150		Drawn DL			
HCL Project No. 2166		Suitability -		Checked TB			
Project	Originator	Volume	Level	Type	Scale	Number	
2166	HCL-ZZ	XX	DR	E	6000		