


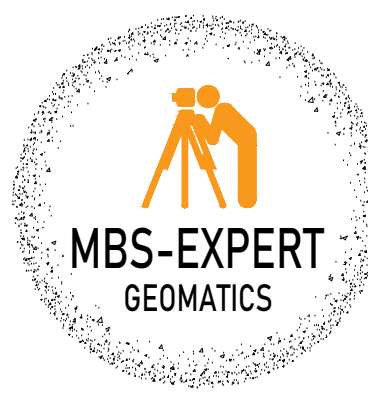

MBS-EXPERT

Phone: +44 (0) 7513 166 760

Email: info@mbs-expert.co.uk


Website:

www.mbs-expert.co.uk

LEGEND

Bottom of Bank	Air Valve	AV
Building	Barbed	BAR
British Telecom	Cable TV Point	CATV
Cable TV	Cable Riser	CR
Canopy	Chimney Top Level	CHT
Channel	Down Pipe	DP
Chimney Line	Eave Level	EL
Contour	Electric Pole	EP
Fence	Flat Roof Level	FRL
Gate	Floor Level	FL
Gas Pipe	Gas Marker	GM
General Detail	Gas Meter	GM
Hedge	Gas Valve	GV
Vegetation Overgrown	Gully	G
Inspection Cover	Hydrant Marker	HM
Kerb	Invert Level	IL
Kerb Top	Lamp Post	LP
Overhead Cable	Overhead	OH
Manhole	Pipe Riser	PR
Ramp	Post	PO
Road	Road Sign	RS
Ridge	Roofing Eye	RE
Stop/Stream	Station	ST 00
Top of Bank	Sign Post	SP
Track	Stop Valve	SV
Miscellaneous	Stay / Plug	SP
Vegetation	Stay / Plug	SP
Vegetation Hatch	Stump	ST
Water Feature	Tap	TAP
Wall / Retaining Wall	Telegraph Pole	TP
	Threshold Level	THL
Methods	Top of Fence	TF
Inspection Cover	Top of Vegetation	TV
	Top of Tree	TT
	Top of Hedge	TH
	Top of Wall	TW
	Water Level	WL
	Water Meter	WM

Site Preview:

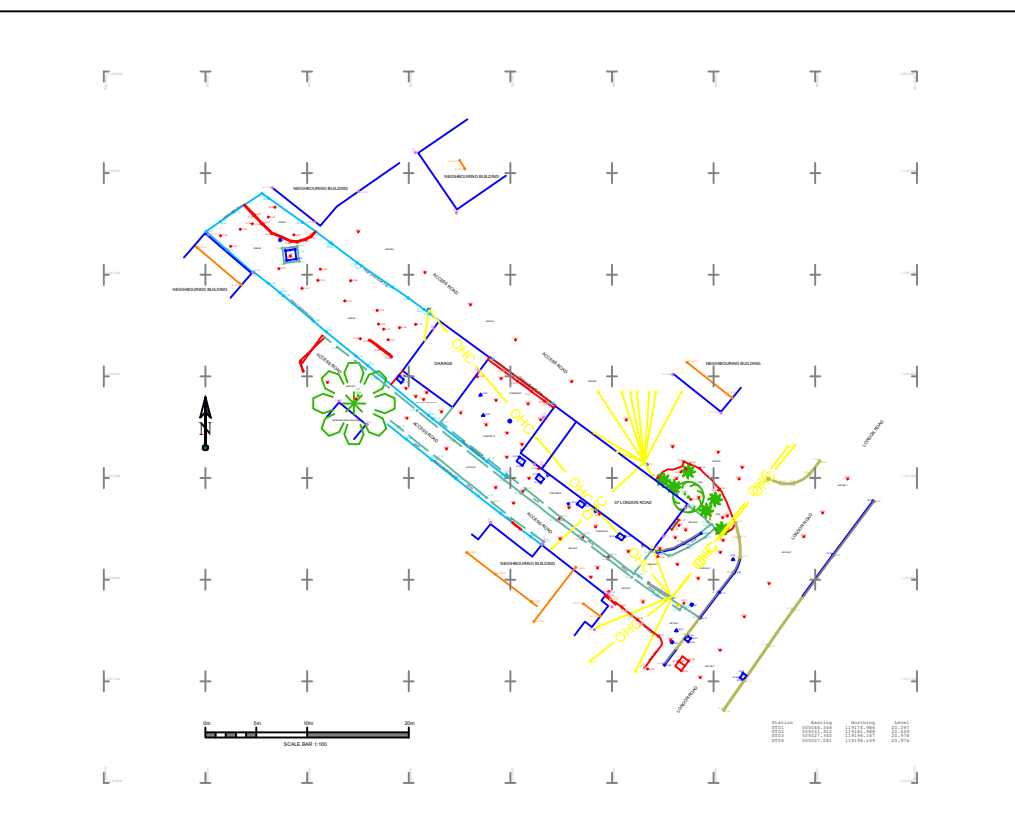

Revisions:


Revision	Description	Made By	Date
----------	-------------	---------	------

Revision Notes:

Client Name:	MCHALE CONSTRUCTIONS
Project Name:	37 London Road
Project Address:	37 London Road, Pulborough, RH20 1AS
Drawing Title:	Topographical Site Plan
File Name:	PN142 - TOPO.dwg

Scale:	Date:	Drawn by:	Checked By:	Project No:
A0@1:100	28/03/2026	DP	DP	PN142
Rev. No:	Drawing Units:	Grid Orientation:	Site Level Datum:	
None	METRES	GPS	GPS	

Notes: This drawing is not to be scaled. Only written dimensions should be respected. All information contained in this drawing, including the digital data, should be verified prior to any fabrication or construction. Tree species are to be verified by an arboriculturist.

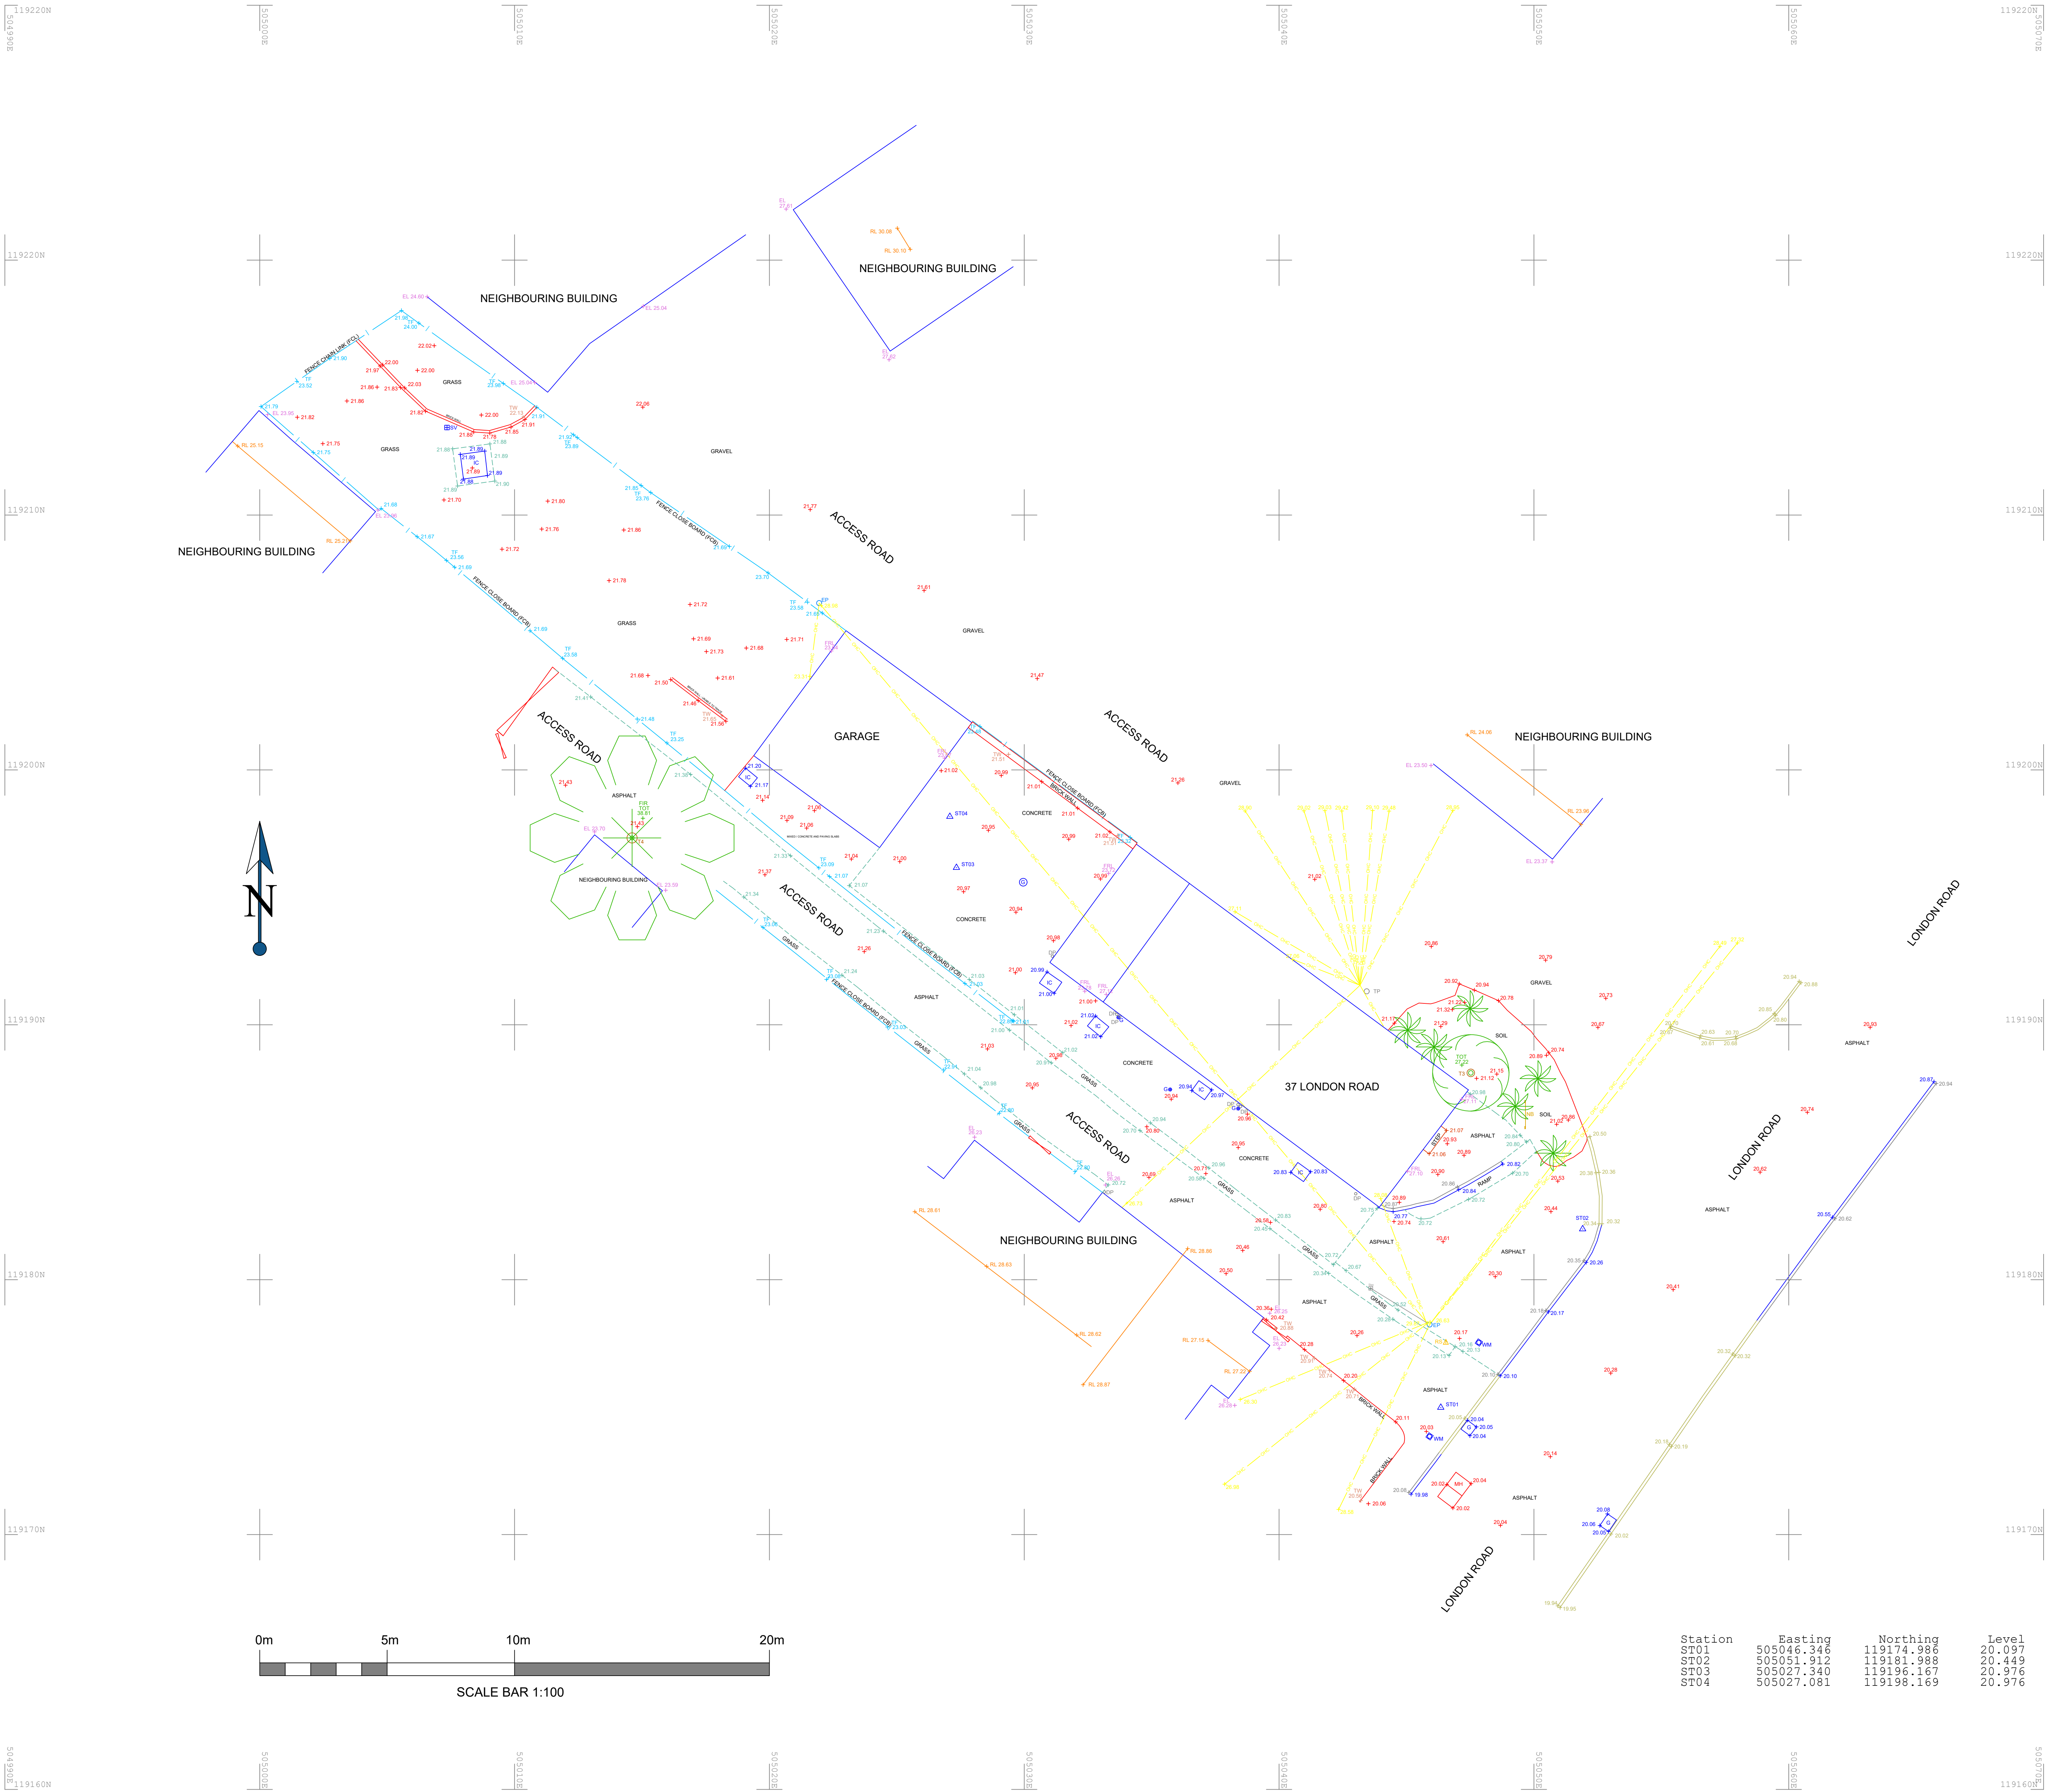

Station	Easting	Northing	Level
ST01	505046.346	119174.988	20.097
ST02	505051.912	119181.988	20.449
ST03	505027.340	119196.167	20.976
ST04	505027.081	119198.169	20.976