


Figure 14: Dimension (Outdoor Unit)

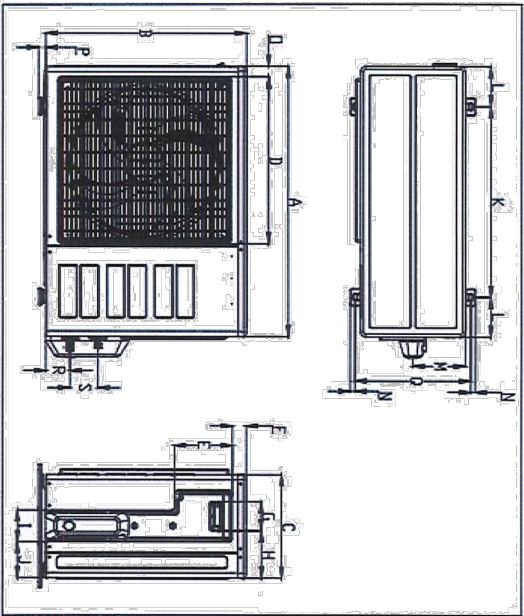


MODEL	A	B	C	D	E	F	G	H	I	J	K	L	M	N
JA6LC26CV1	855	628	328	508/520	181/179	44/46	93	149	101	113	603	126	164	17/15
JA6LC41CV1	855	730	328	513/520	182/179	44/46	93	149	101	113	603	126	164	17/15

MODEL	O	P	Q	R	S
JA6LC26CV1	49/34	23	362	73	75
JA6LC41CV1	47/34	23	362	73	75

REFRIGERATOR FAN UNIT TO BE PART OF A/E HALL PACKAGE COOLING SYSTEM AND EXTERNAL FAN (REF. JAC26CV1) UNIT SIZE IS APPROX. 800mm (H) x 1000mm (W) x 100mm (D). UNIT WILL BE MOUNTED ON HEAVY DUTY NOISE REDUCING MOUNTINGS ON SMALL CONCRETE SLAB AT GROUND LEVEL.

REFRIGERATOR FAN UNIT TO BE PART OF A/E HALL PACKAGE COOLING SYSTEM AND INTERNAL FAN (REF. JAC26CV1) UNIT SIZE IS APPROX. 800mm (H) x 1000mm (W) x 100mm (D). UNIT WILL BE MOUNTED ON HEAVY DUTY NOISE REDUCING MOUNTINGS ON SMALL CONCRETE SLAB INSIDE BUILDING.

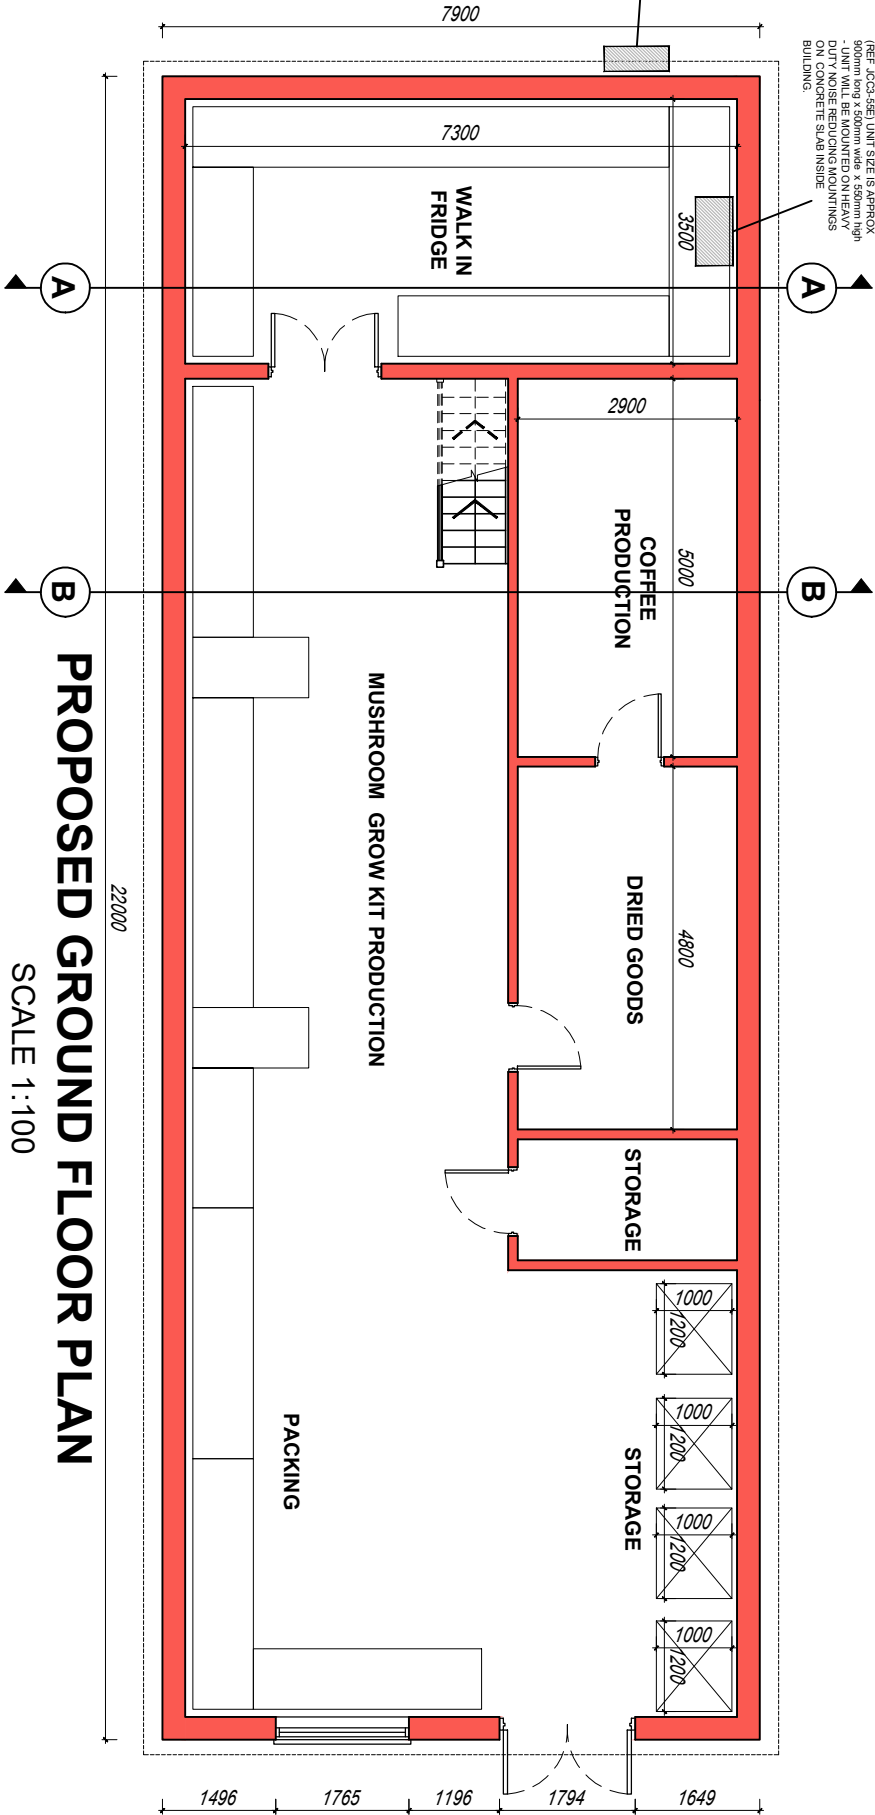


EXTERNAL FAN UNIT DETAILS - NTS

PROPOSED GIA

Ground floor - 156.2m²

First floor - 62.7m²

 Total - 218.9m²



Scale Bar 1:100

Copyright reserved.

- This drawing may only be used for the client and location specified in the title block. It may not be copied or disclosed to any other third party without prior written consent from DMA Building Designs.
- Prior to any works commencing on site, DMA Building Designs is to be contacted regarding the current status, revision or regulatory approval of this drawing.
- The works shown have been drawn for submission to the local planning authority and are not to be used for construction. No works shall commence until planning approval has been given by the local authority.


- No works to commence without either full plans building control approval or a building notice served with the local authority.
- The dimensions indicated are approximate and subject to site checks by the contractor prior to commencement.
- DMA Building Designs accept no responsibility for any unknown factors which either preclude the works from construction or add additional costs, ie location of public sewers and underground services, abnormal foundation designs, due to trees, ground conditions or any underground structure or obstruction, condition of the existing building.

DMA
BUILDING DESIGNS

UNIT 4B, RUDGWICK BRICKWORKS, LYNNICK ST
RUDGWICK, HORSHAM, WEST SUSSEX, RH12 3DH.
TEL No 01403 822220 Mobile 07730 523447
Email - admin@dmabuildingdesigns.co.uk

PROPOSED FIRST FLOOR PLAN

SCALE 1:100

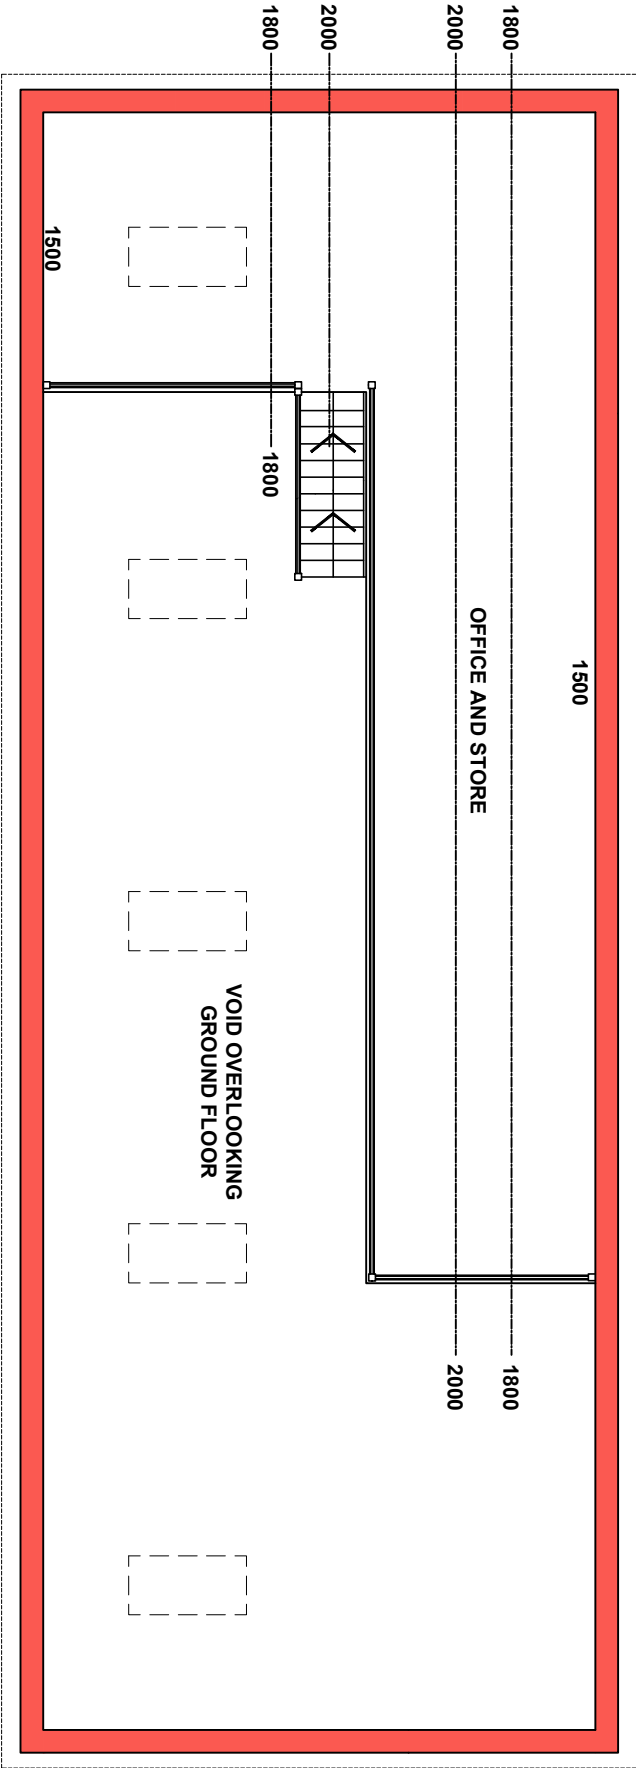

P3	ISSUED FOR CONDITIONS APPROVAL	26.03.2026
P2	ISSUED FOR APPROVAL	09.04.2025
P1	ISSUED FOR PLANNING APPROVAL	03.09.2024

REV	DESCRIPTION	DATE
DRAWING		
PROPOSED FLOOR PLANS		
MERRYHILL MUSHROOMS, STORINGTON ROAD, THAKEHAM ROAD, RH20 3ED.		
SCALE @ A3	DATE	DRG No
1:100	MAY 2025	DE1223 / 04
		REVISION
		P3