

This drawing is copyright and owned by Horsham CAD Services, and is for use on this site only unless contractually stated otherwise.

DO NOT SCALE this drawing (printed or electronic versions). Contractors must check all dimensions from site.

All other design team elements, where indicated, have been imported from the consultant's drawings and reference should be made to the individual consultant's drawings for exact setting out, size and type of component.

Discrepancies and / or ambiguities within this drawing, between it and information given elsewhere, must be reported immediately to the architect for clarification before proceeding.

All works are to be carried out in accordance with the latest British Standards and Codes of Practice unless specifically directed otherwise in the specification.


Responsibility for the reproduction of this drawing in paper form, or if issued in electronic format, lies with the recipient to check that all information has been replicated in full and is correct when compared to the original paper or electronic image. Graphical representations of equipment on this drawing have been co-ordinated, but are approximations only. Please refer to the Specifications and / or Details for actual sizes and / or specific contractor construction information.

This original document is issued for the purpose indicated below and contains information of confidential nature. Further copies and circulation will be strictly in accordance with the confidentiality agreement under the contract. This original must be destroyed or returned to the contractor.


SAFETY, HEALTH AND ENVIRONMENTAL INFORMATION

Refer to the relevant Construction (Design and Management) documentation where applicable.


It is assumed that all works on this drawing will be carried out by a competent contractor, working where appropriate to an approved method statement.

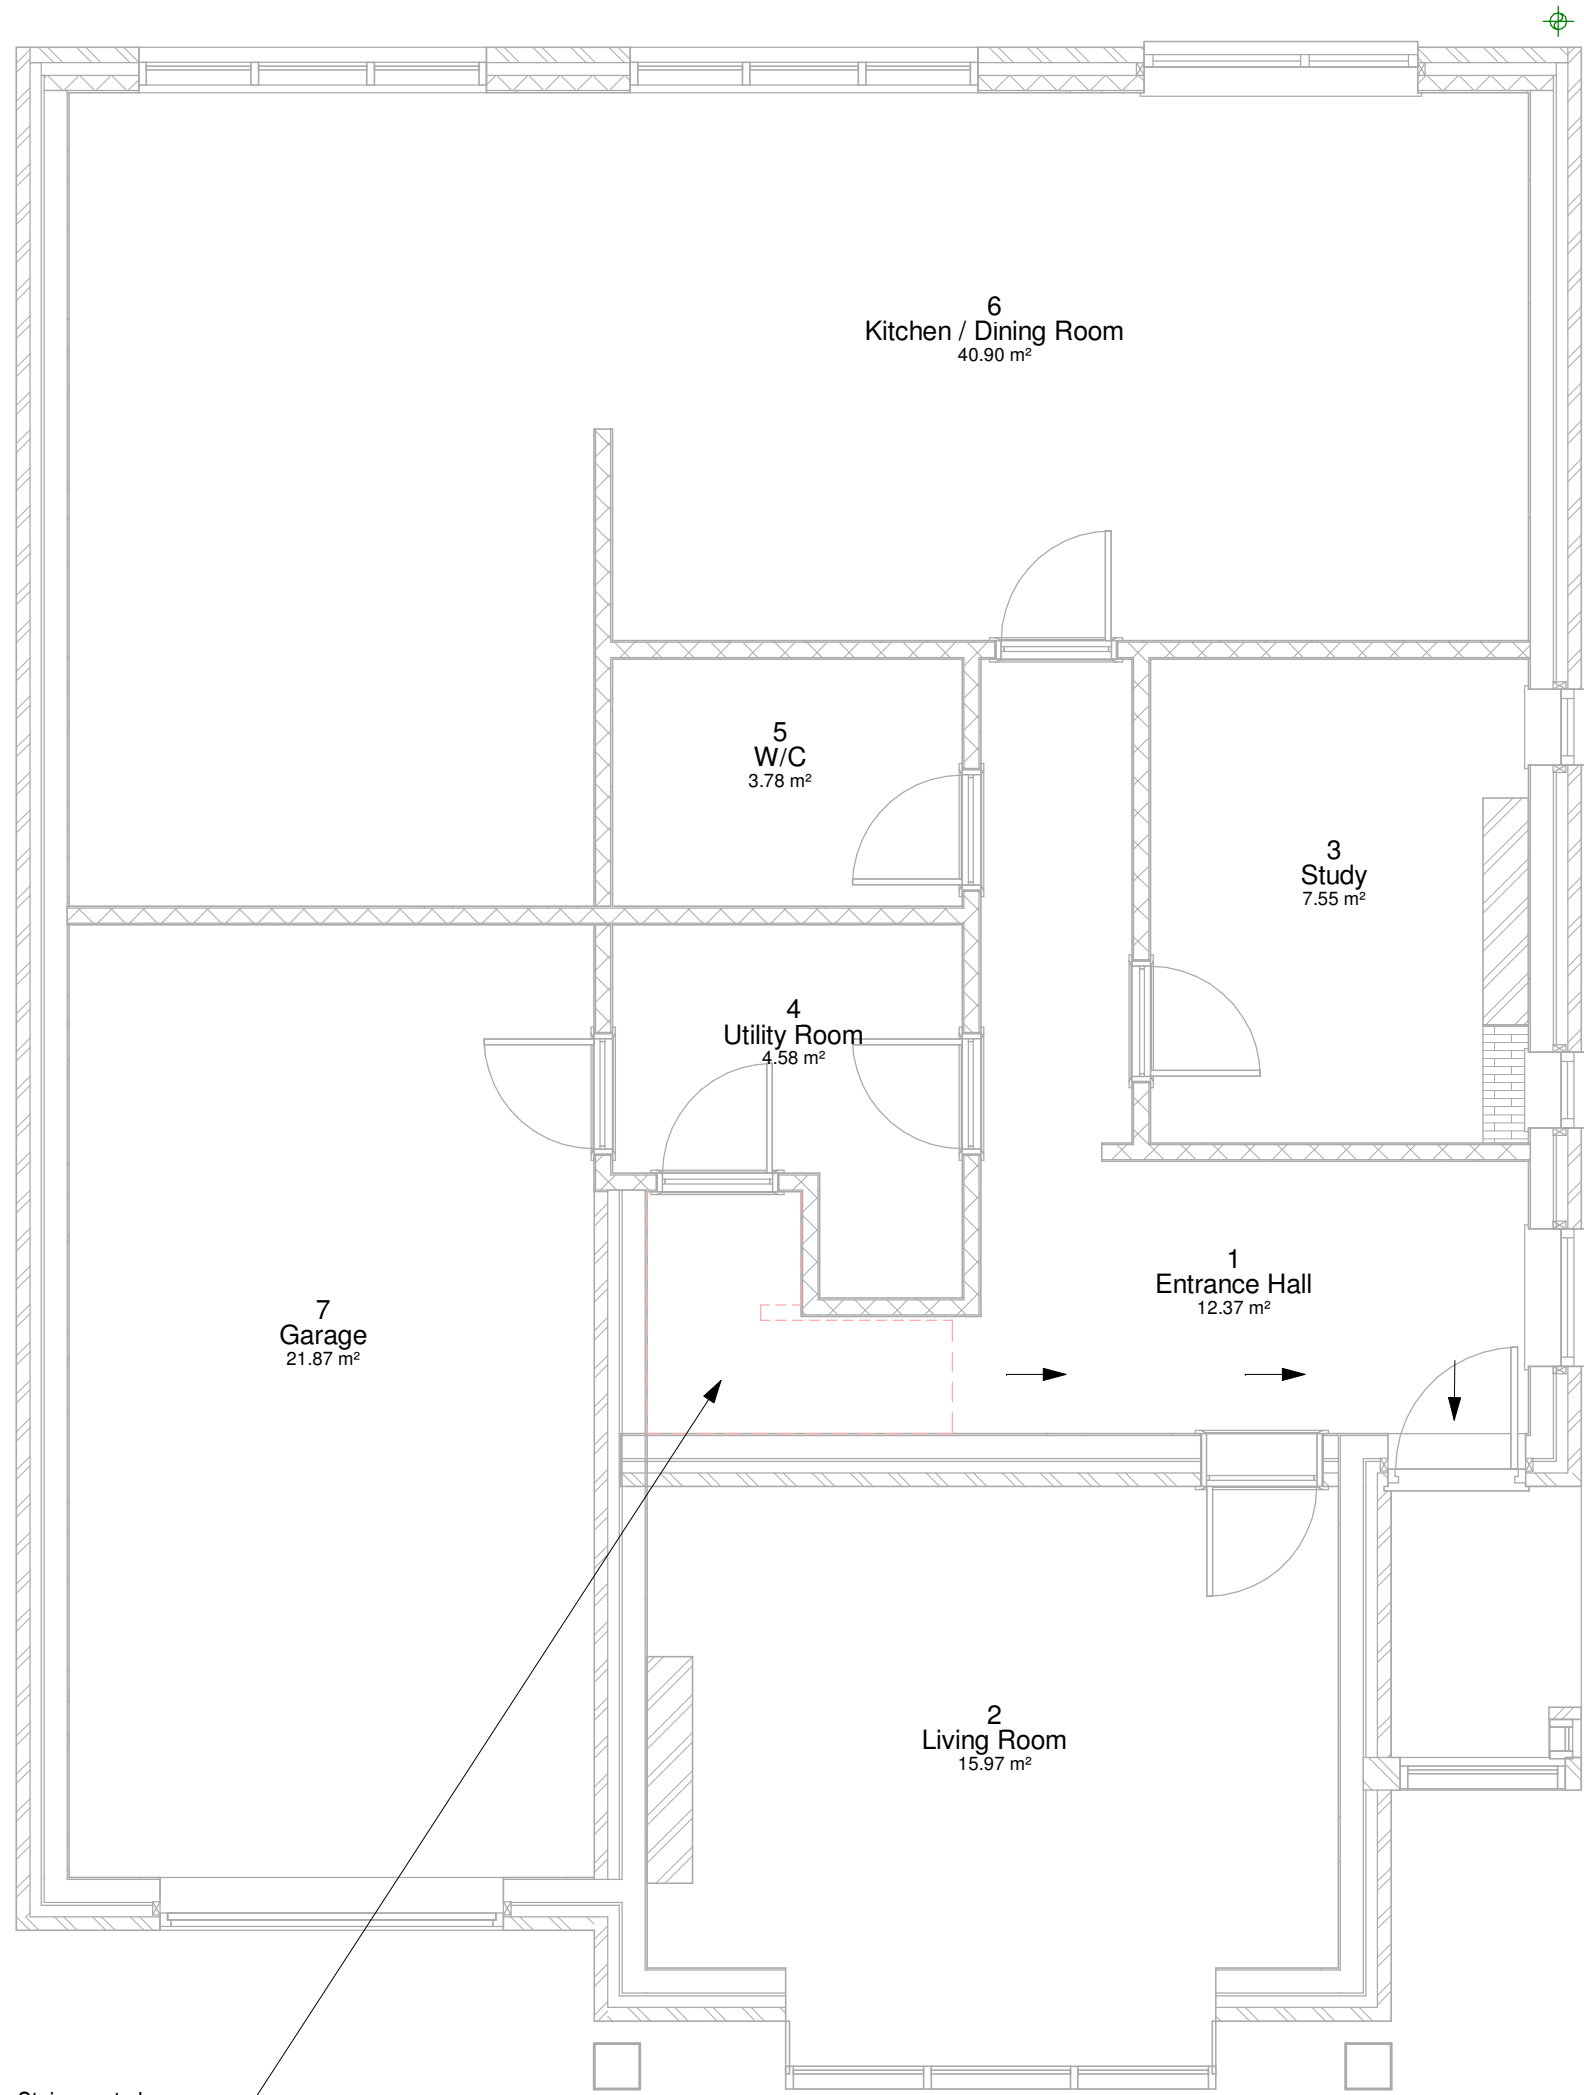

1 Ground Floor Fire Detection, Escape and Alarm (Proposed)
1 : 50

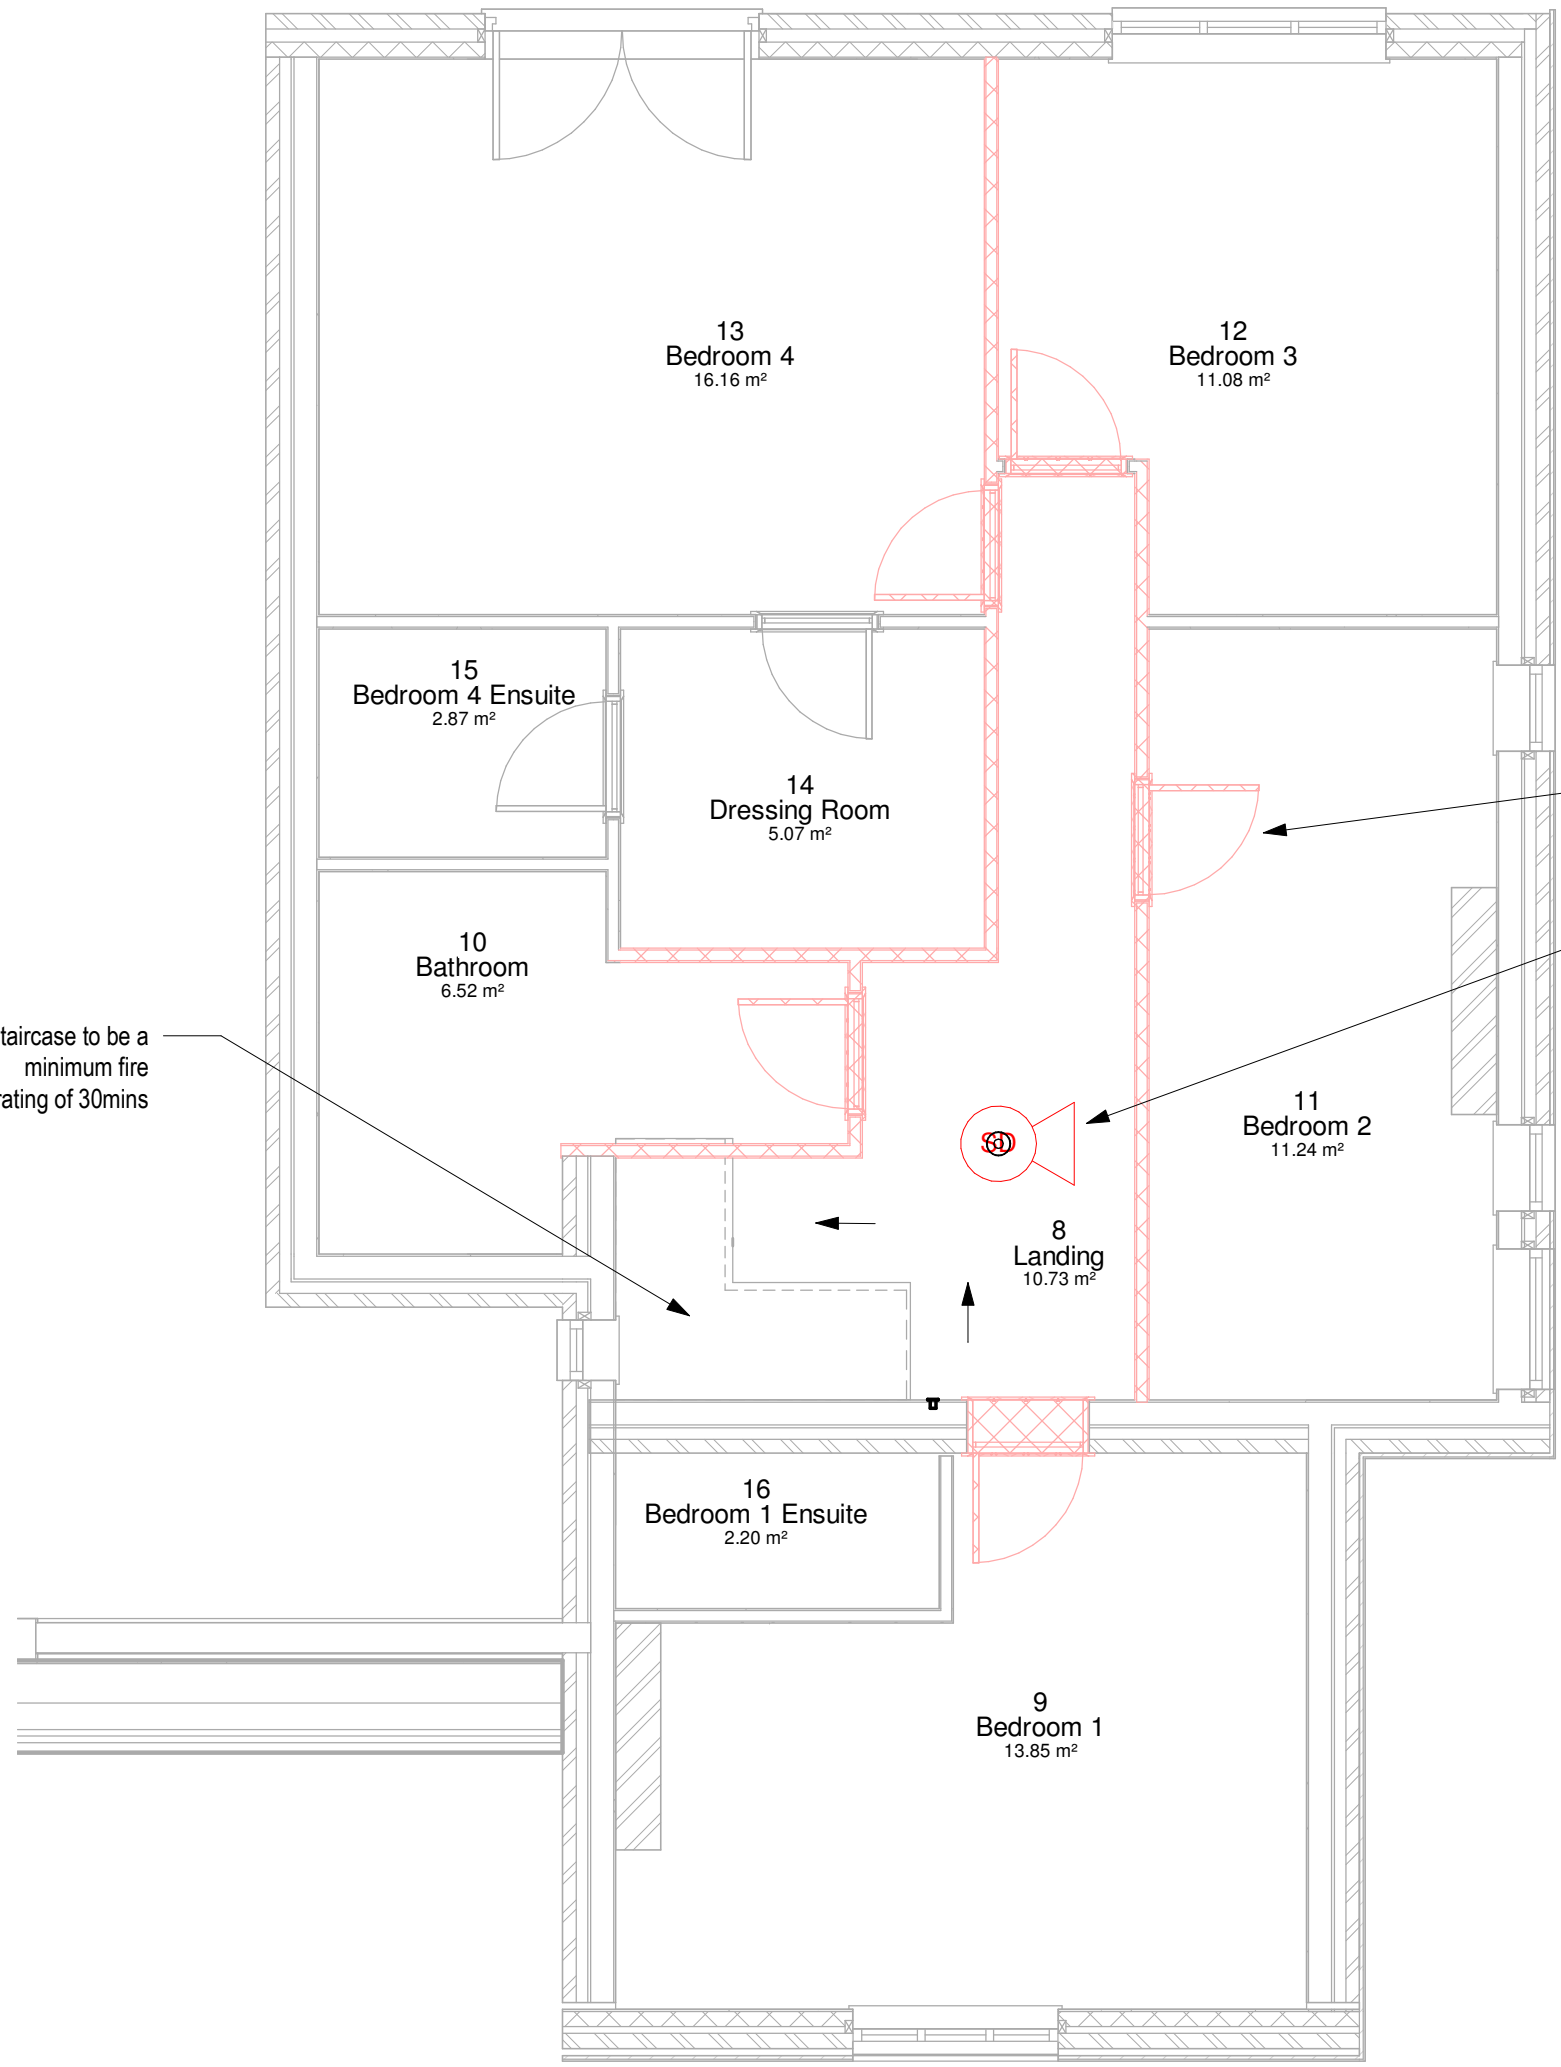

2 First Floor Fire Detection, Escape and Alarm (Proposed)
1 : 50

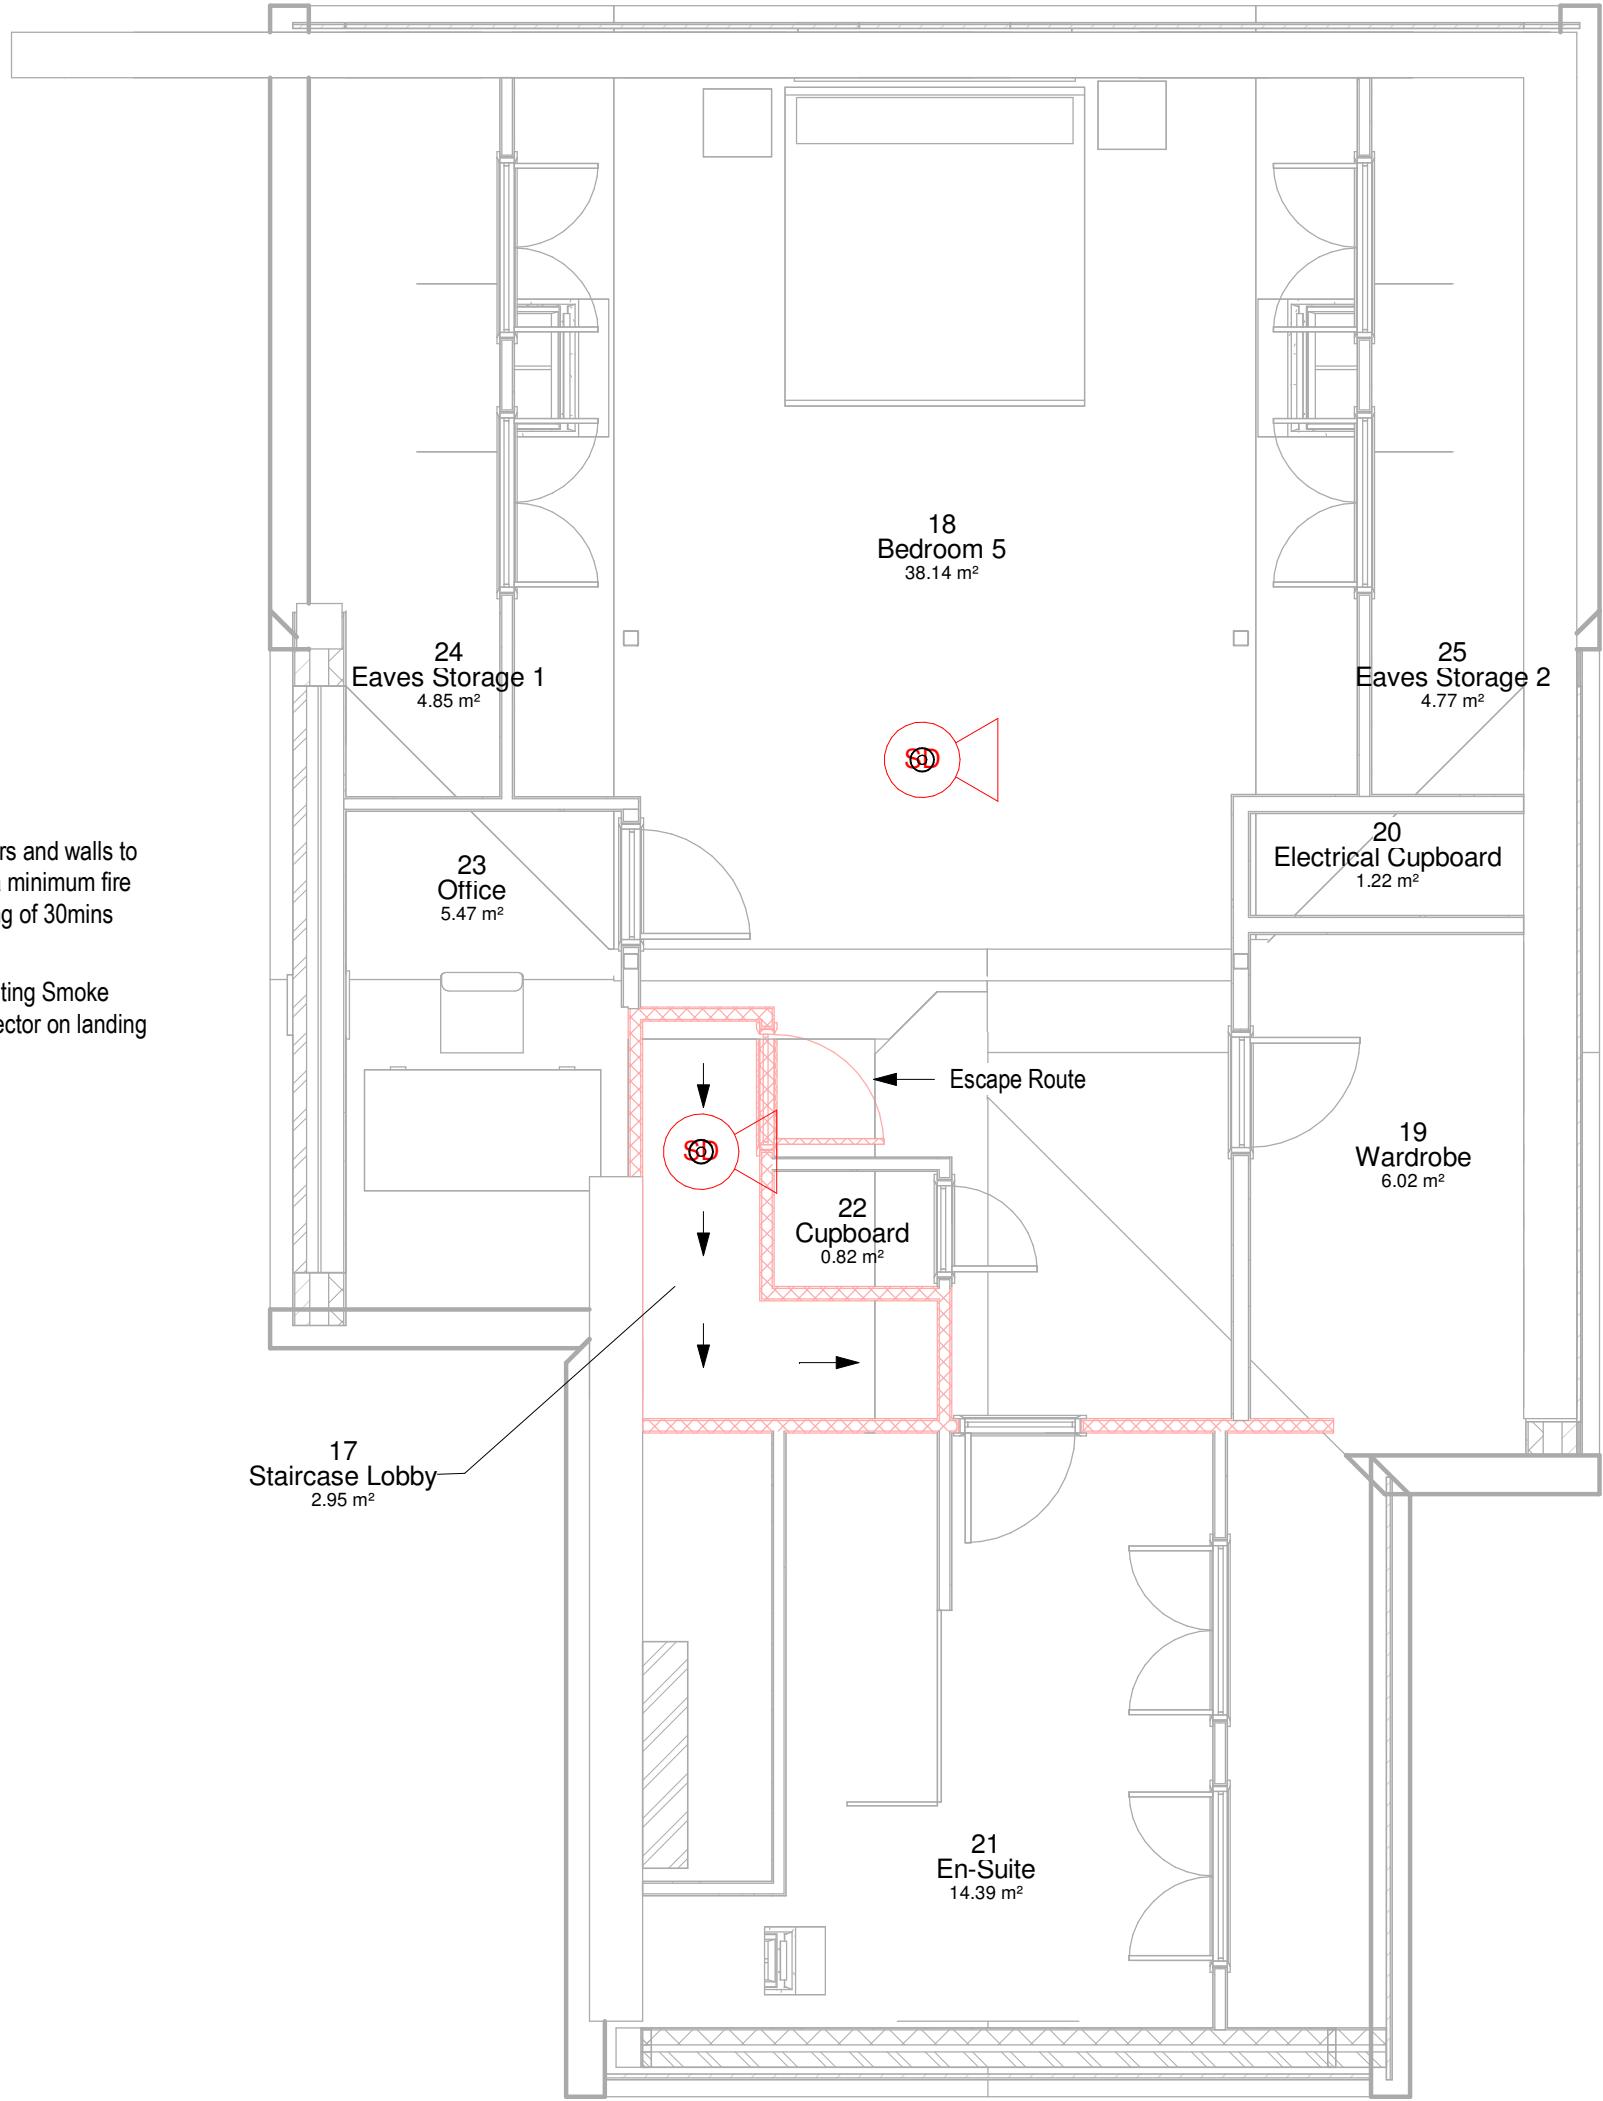

3 Second Floor Fire Detection, Escape and Alarm (Proposed)
1 : 50

- Legend**
- SD Smoke Detector + Sounder
 - 30 Minute Fire Rated Structure

P02	Second Release	HL	HL	HL	13.08.2025
P01	First Release	HL	HL	HL	16.06.2025

Rev	Description / By / Chk'd / App'd	Date
-----	----------------------------------	------

Purpose of Issue	Status
Building Control	S3

Client
Heidi Alobaidi

Project
70 Hurst Road
Loft Conversion

Drawing
Fire Detection, Escape & Alarm
Second Floor Reflected Ceiling Plan
Proposed

Scale @ A1	Drawn	Checked	Approved
As indicated	HL	HL	HL

Project No.	Date
HCS2025-06	16.06.2025

Drawing Identifier						BS1192 / Uniclass Compliant	
project	origin	zone	level	file type	role	uniclass and number	revision
70H	HCS	01	02	D	E	2009	P01



Horsham CAD Services

Design & Engineering

16 Freeman Road, Warnham, Horsham, West Sussex, RH12 3RQ
www.horshamcadservices.webs.com
Horsham CAD Services

