


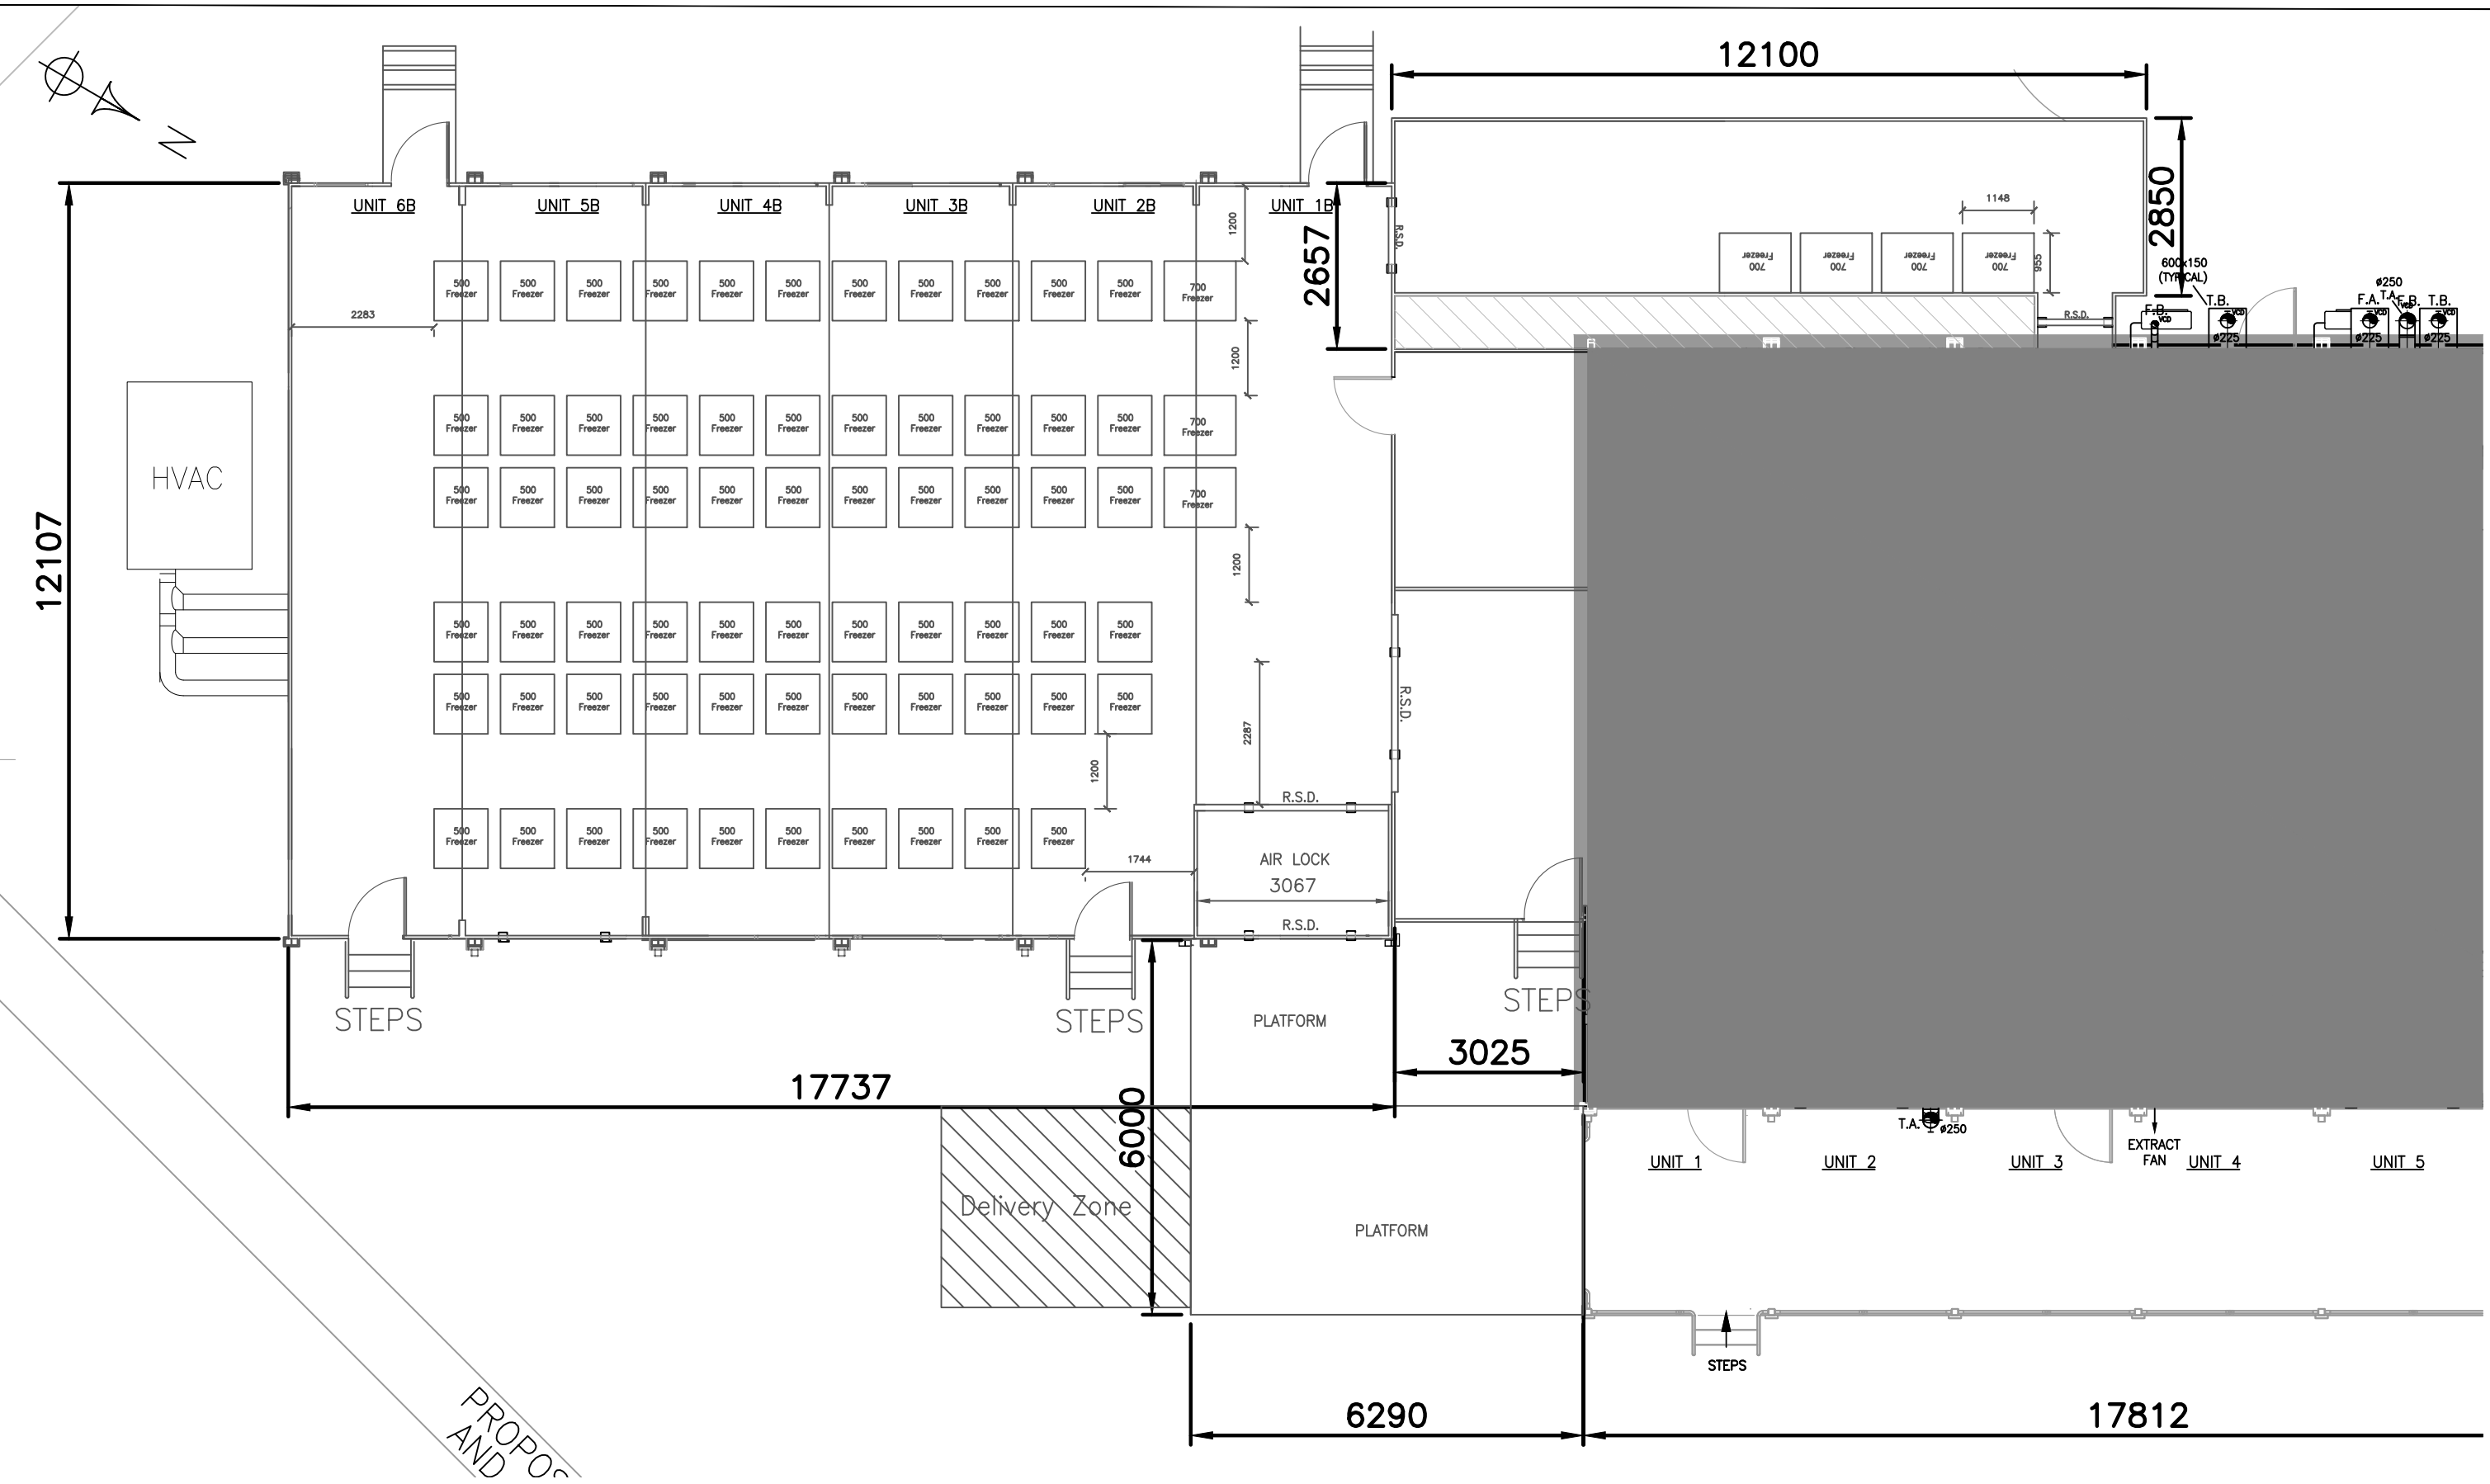

Project address ThermoFisher Scientific Langhurstwood Road Horsham West Sussex RH12 4QD	Drawing description 02-01 Proposed Cryo-Hub Floor Plan			SOVEREIGN COMMERCIAL Installations Limited Sovereign Commercial Installations Ltd Commercial House 13 Westham Business Park Eastbourne, BN24 5NP Tel: 01323 763179 Fax: 01323 763081 www.sovereigncommercial.com stuart@sovcomm.co.uk
Project description Additional Cryo-Hub Storage Facility on Carpark D	Scale 1:100@A3	Date 03.03.26	Drawn by Zoe Volkes	
	Drawing No: © SMCA/Q12089 This drawing is copyright & may not be reproduced or used in any way without the permission of the drawer	Revision 01		