


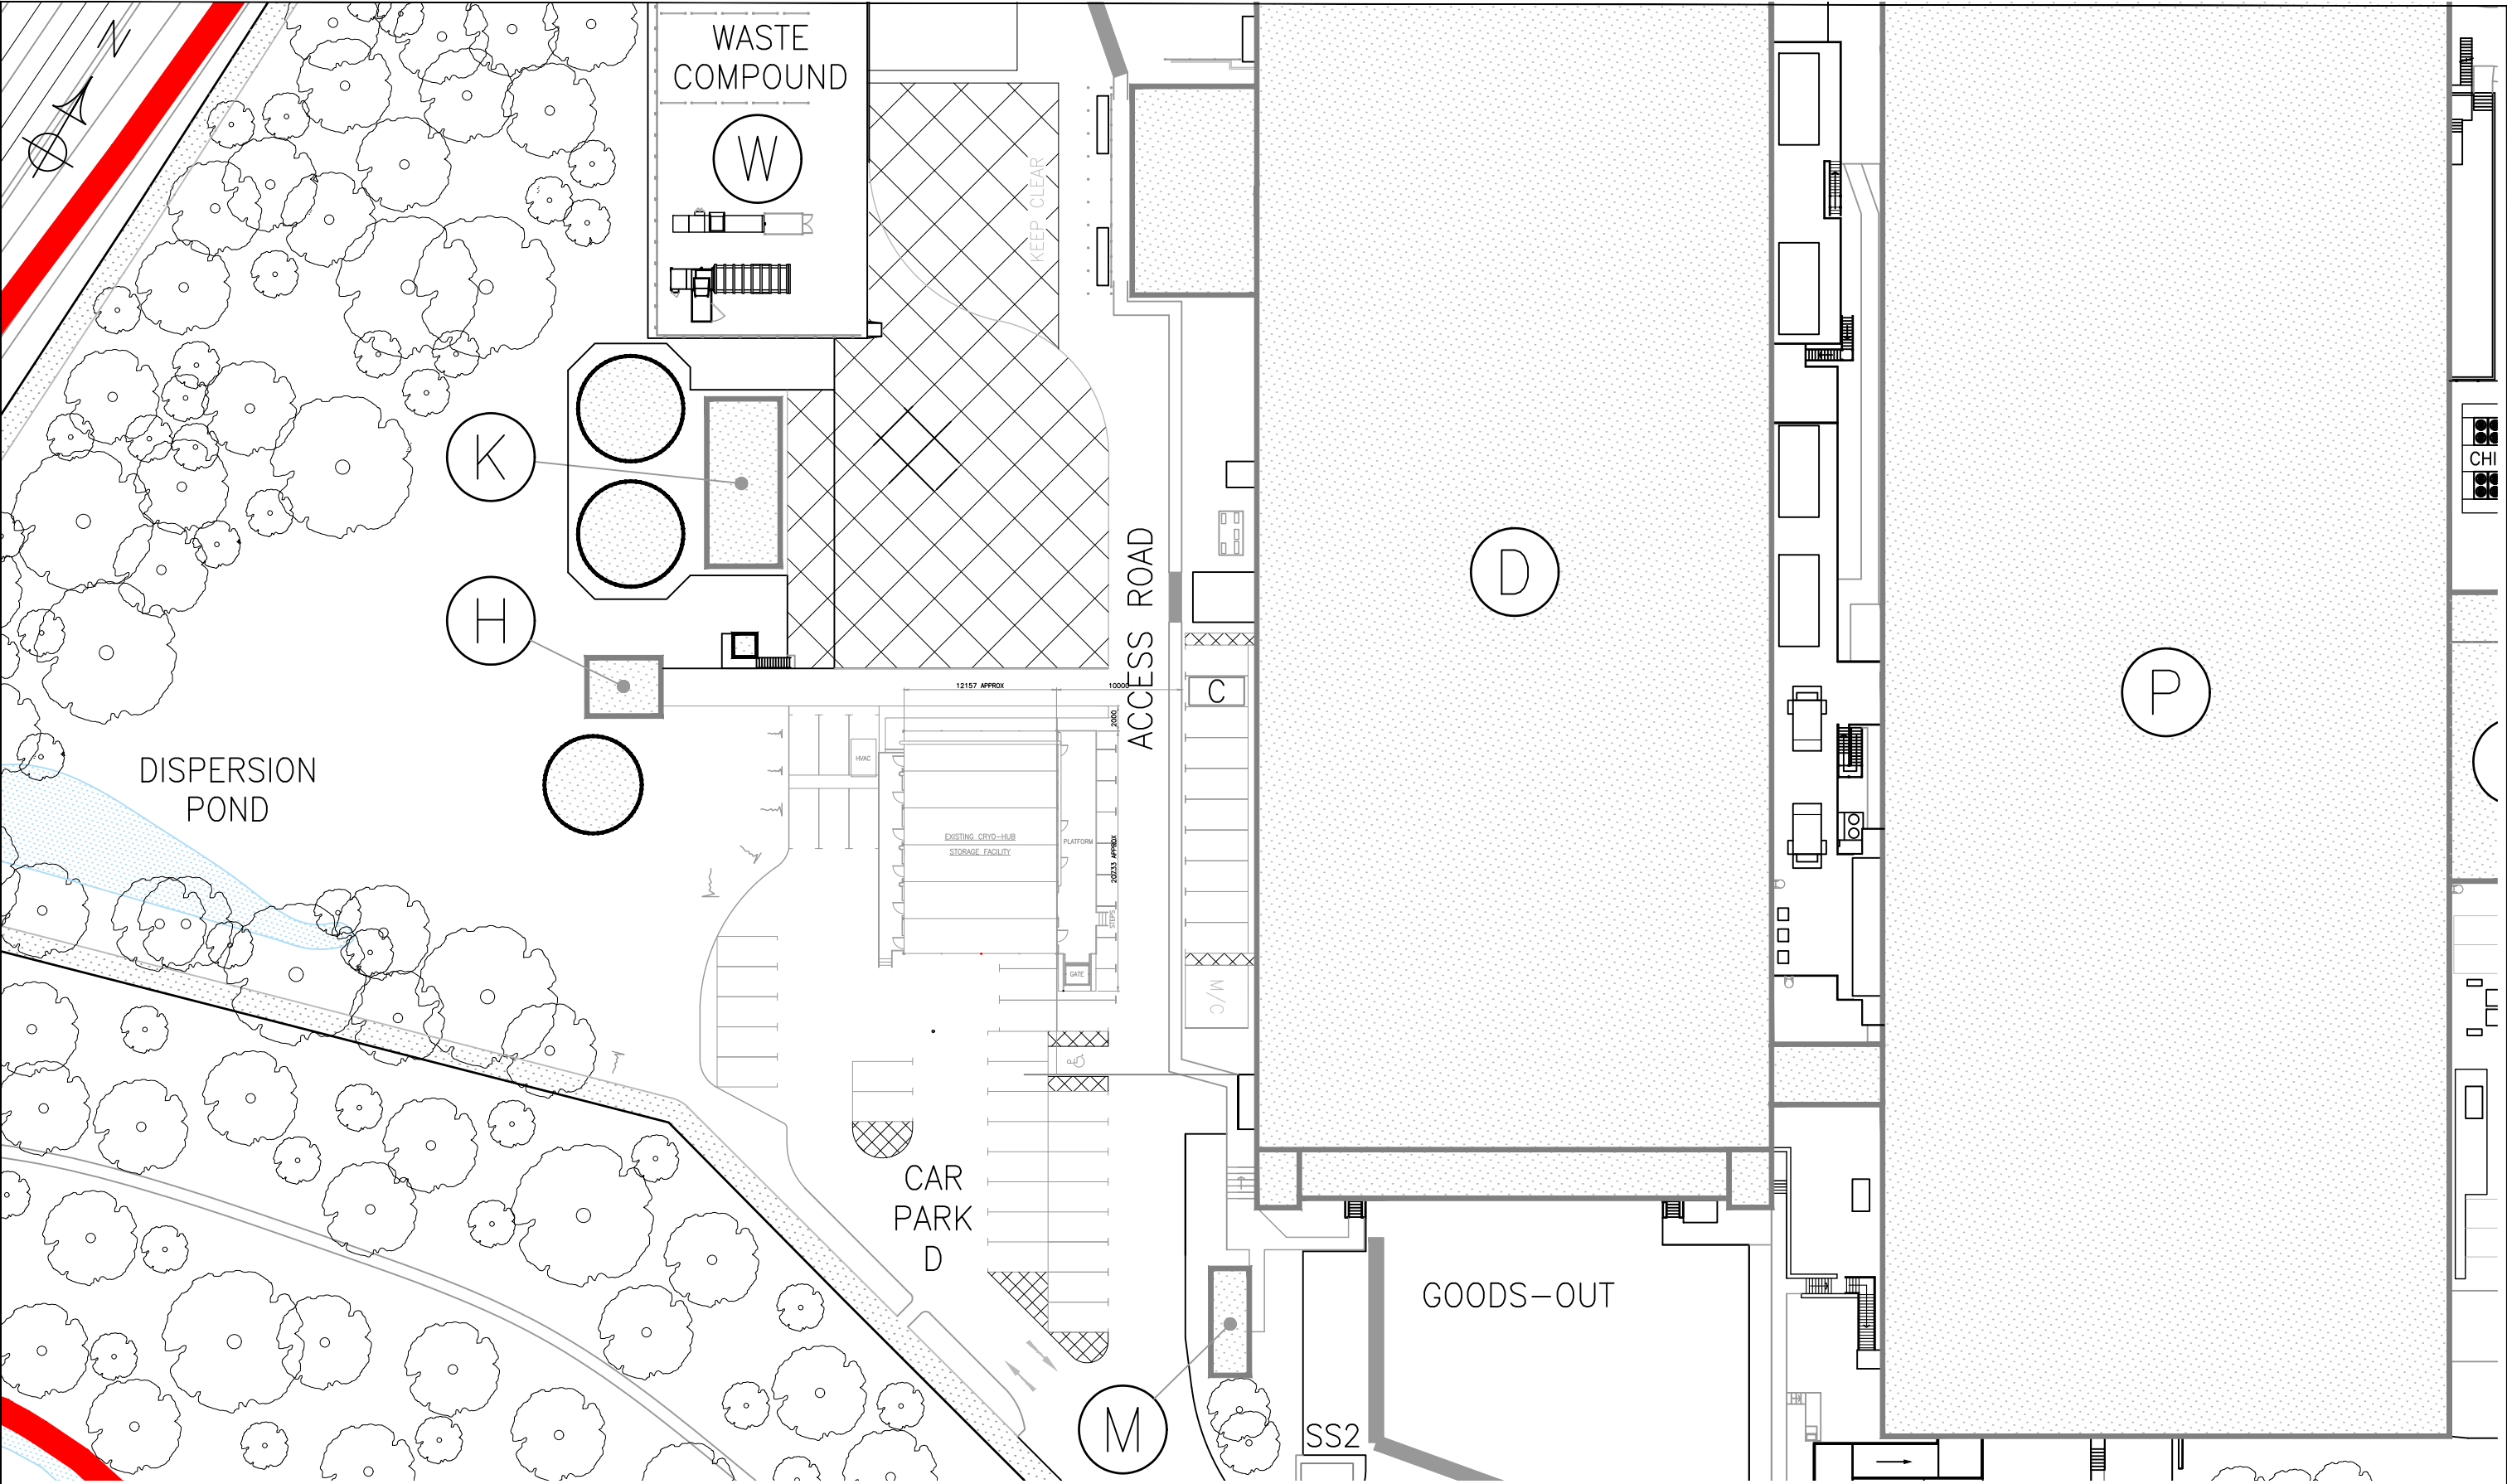

Project address
ThermoFisher Scientific
Langhurstwood Road
Horsham
West Sussex
RH12 4QD

Project description
Additional Cryo-Hub Storage Facility on
Carpark D

Drawing description
01-01 Existing Site Plan

Scale
1:500@A3

Date
03.03.26

Drawn by
Zoe Volkes

Drawing No: © SMCA/Q12089

Revision
-

SOVEREIGN COMMERCIAL
Installations Limited

Sovereign Commercial Installations Ltd
Commercial House
13 Westham Business Park
Eastbourne, BN24 5NP

Tel: 01323 763179
Fax: 01323 763081

www.sovereigncommercial.com
stuart@sovcomm.co.uk