


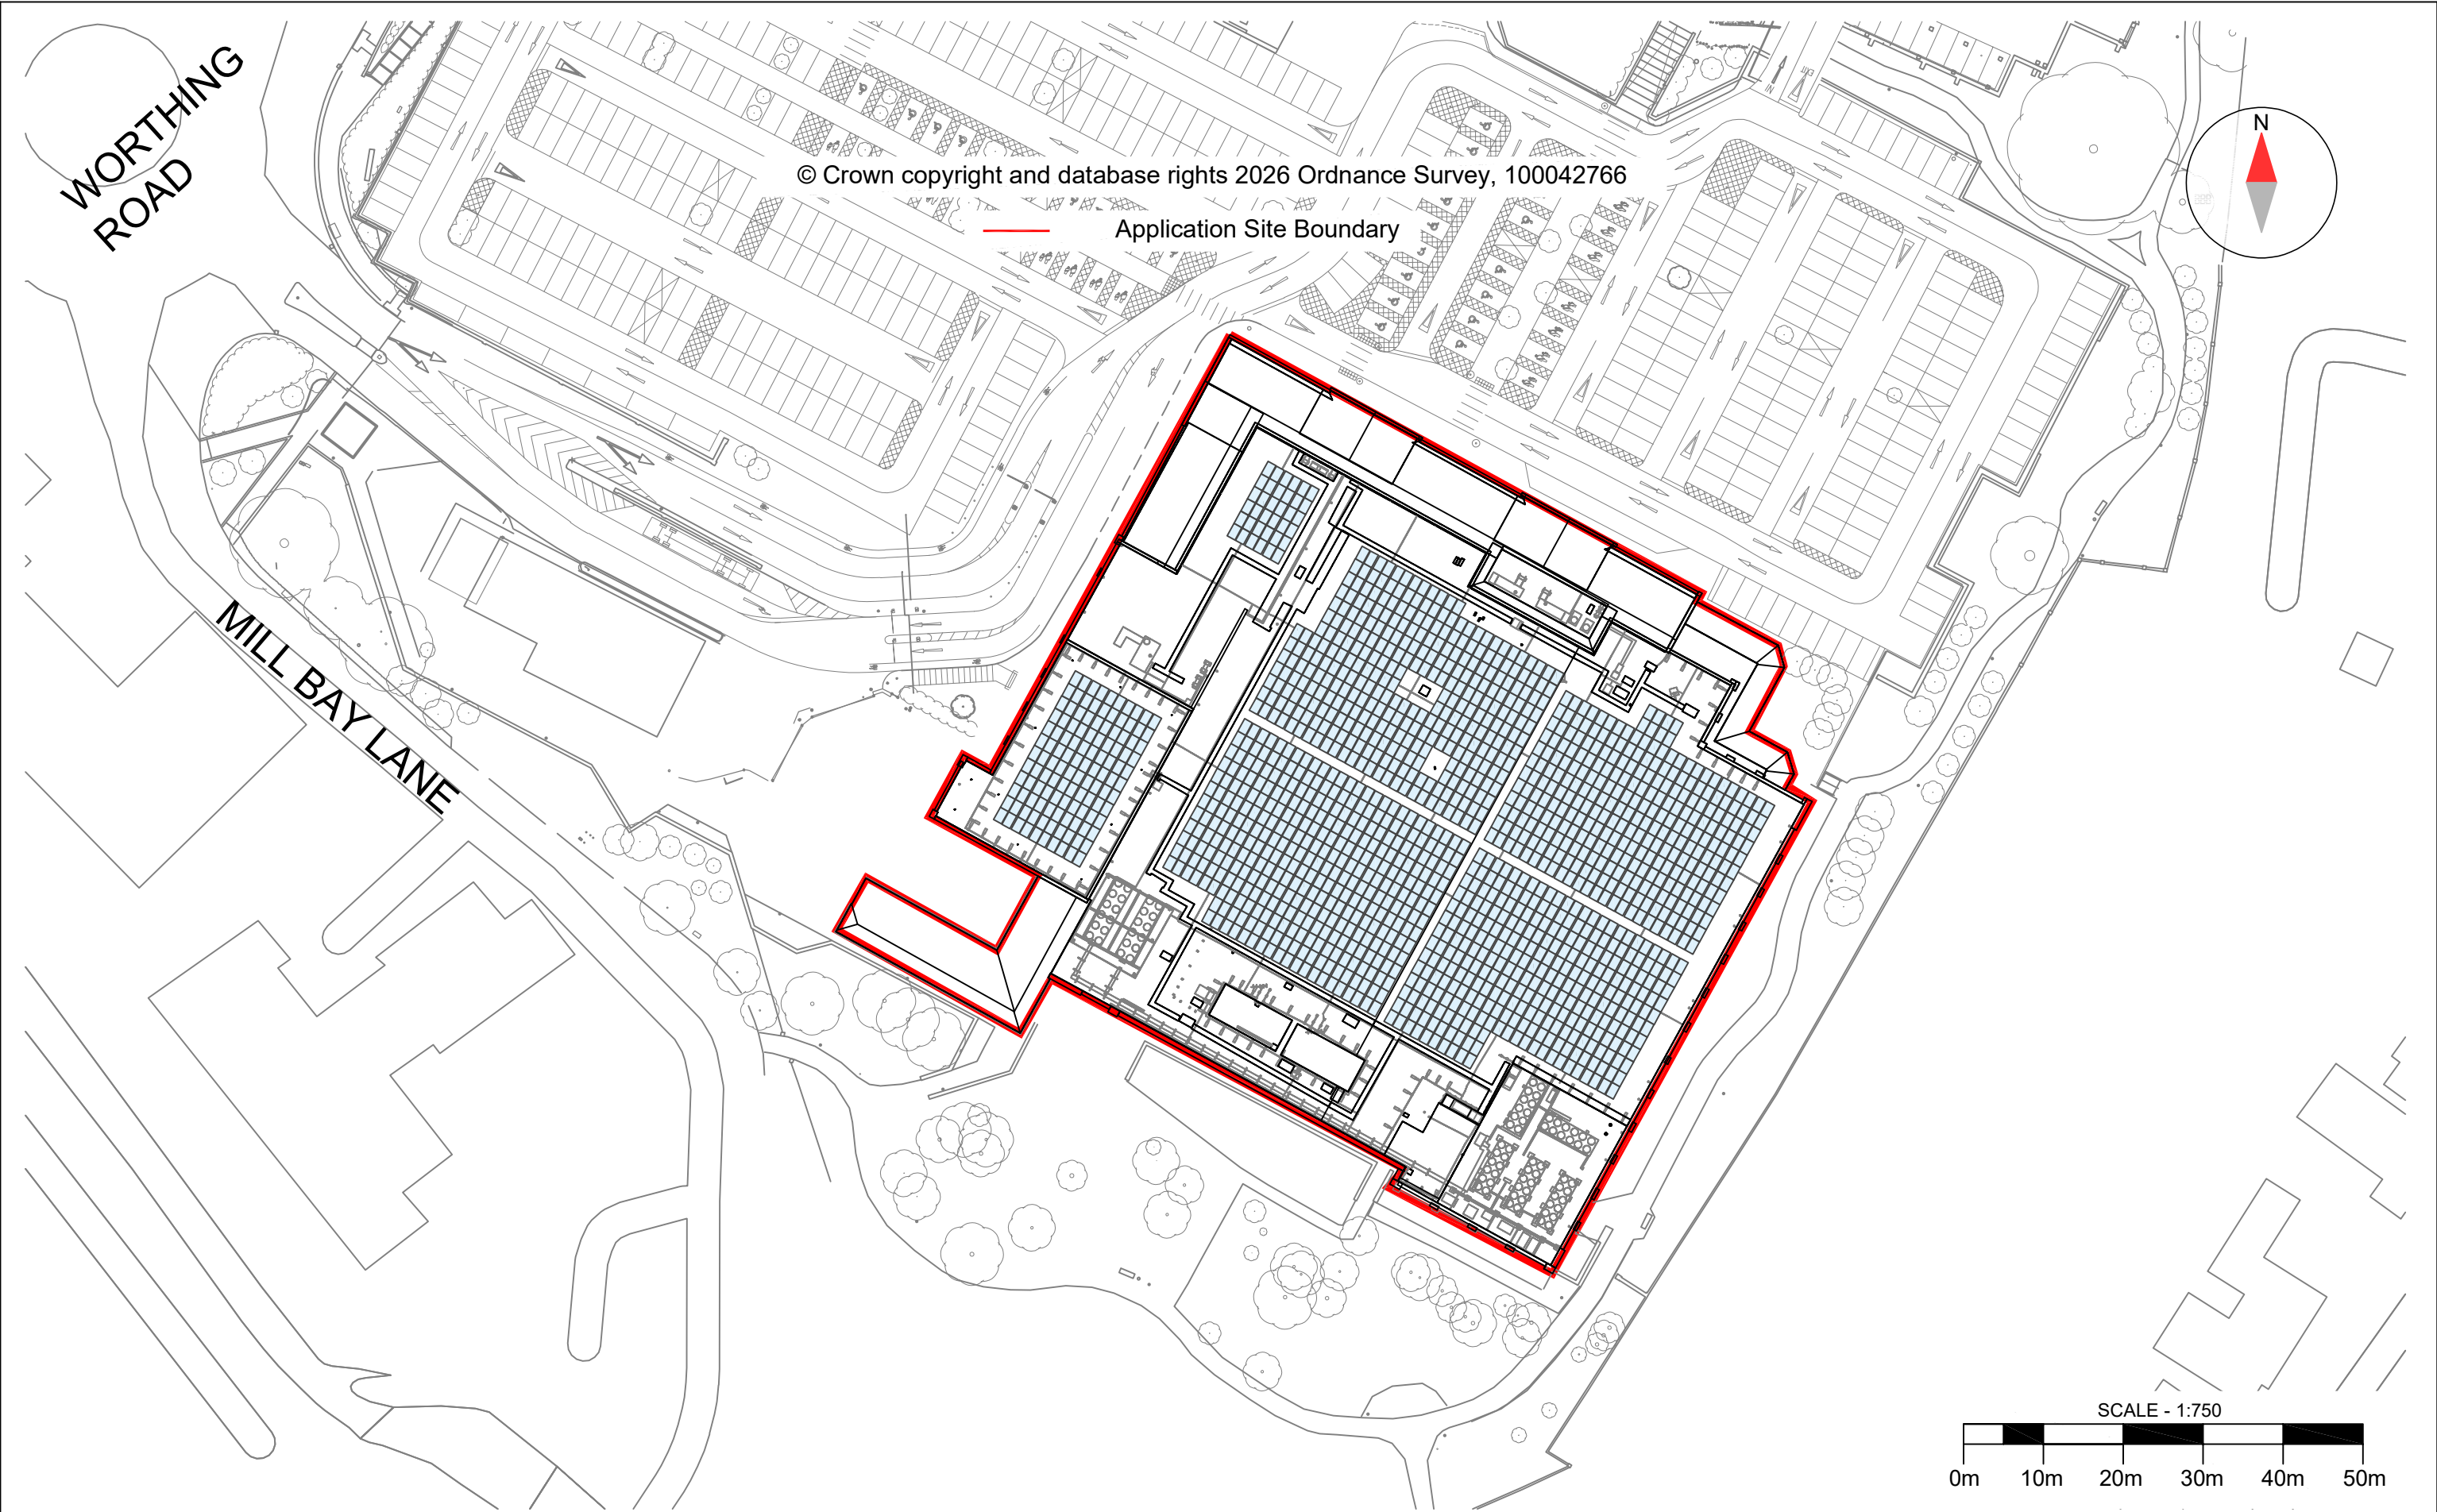

Notes:
1. All details are indicative only.
2. All equipment designed, and to be installed in accordance with BS 7671:2018.
3. Installation drawings must always be read in conjunction with the relevant manufacturer's installation manuals.

Ineco Energy Ltd is a limited company registered in England and Wales.
Company Registration No: 1047724
Registered Office: Office 21, Rural Innovation Centre, Stoneleigh Park, CV8 2LG

This drawing or any part of it may not be reproduced without prior consent. Do not scale.
Always cross check dimensions on site. Always check you are viewing the latest version.

CLIENT:	Sainsbury's Supermarkets Ltd	DC CAPACITY (TIC):	655.0 kWp	DRAWN:	JN
PROJECT:	Sainsbury's Horsham	AC CAPACITY (DNC):		DATE:	26/02/26
		EXPORT LIMIT (ELS):		DRAWING NO:	IE-RH503-05
ADDRESS:	Sainsbury's, 7 Worthing Road, Horsham RH12 1SQ	MODULE:	1,424 x JA Solar JAM54D40 445Wp	DRAWING TITLE:	Proposed Site Plan
		OPTIMISER:		REVISION:	D1
CONTRACTOR:	Ineco Energy Ltd www.inecoenergy.com 02920 021777 info@inecoenergy.com	INVERTER:		PLANNING	