


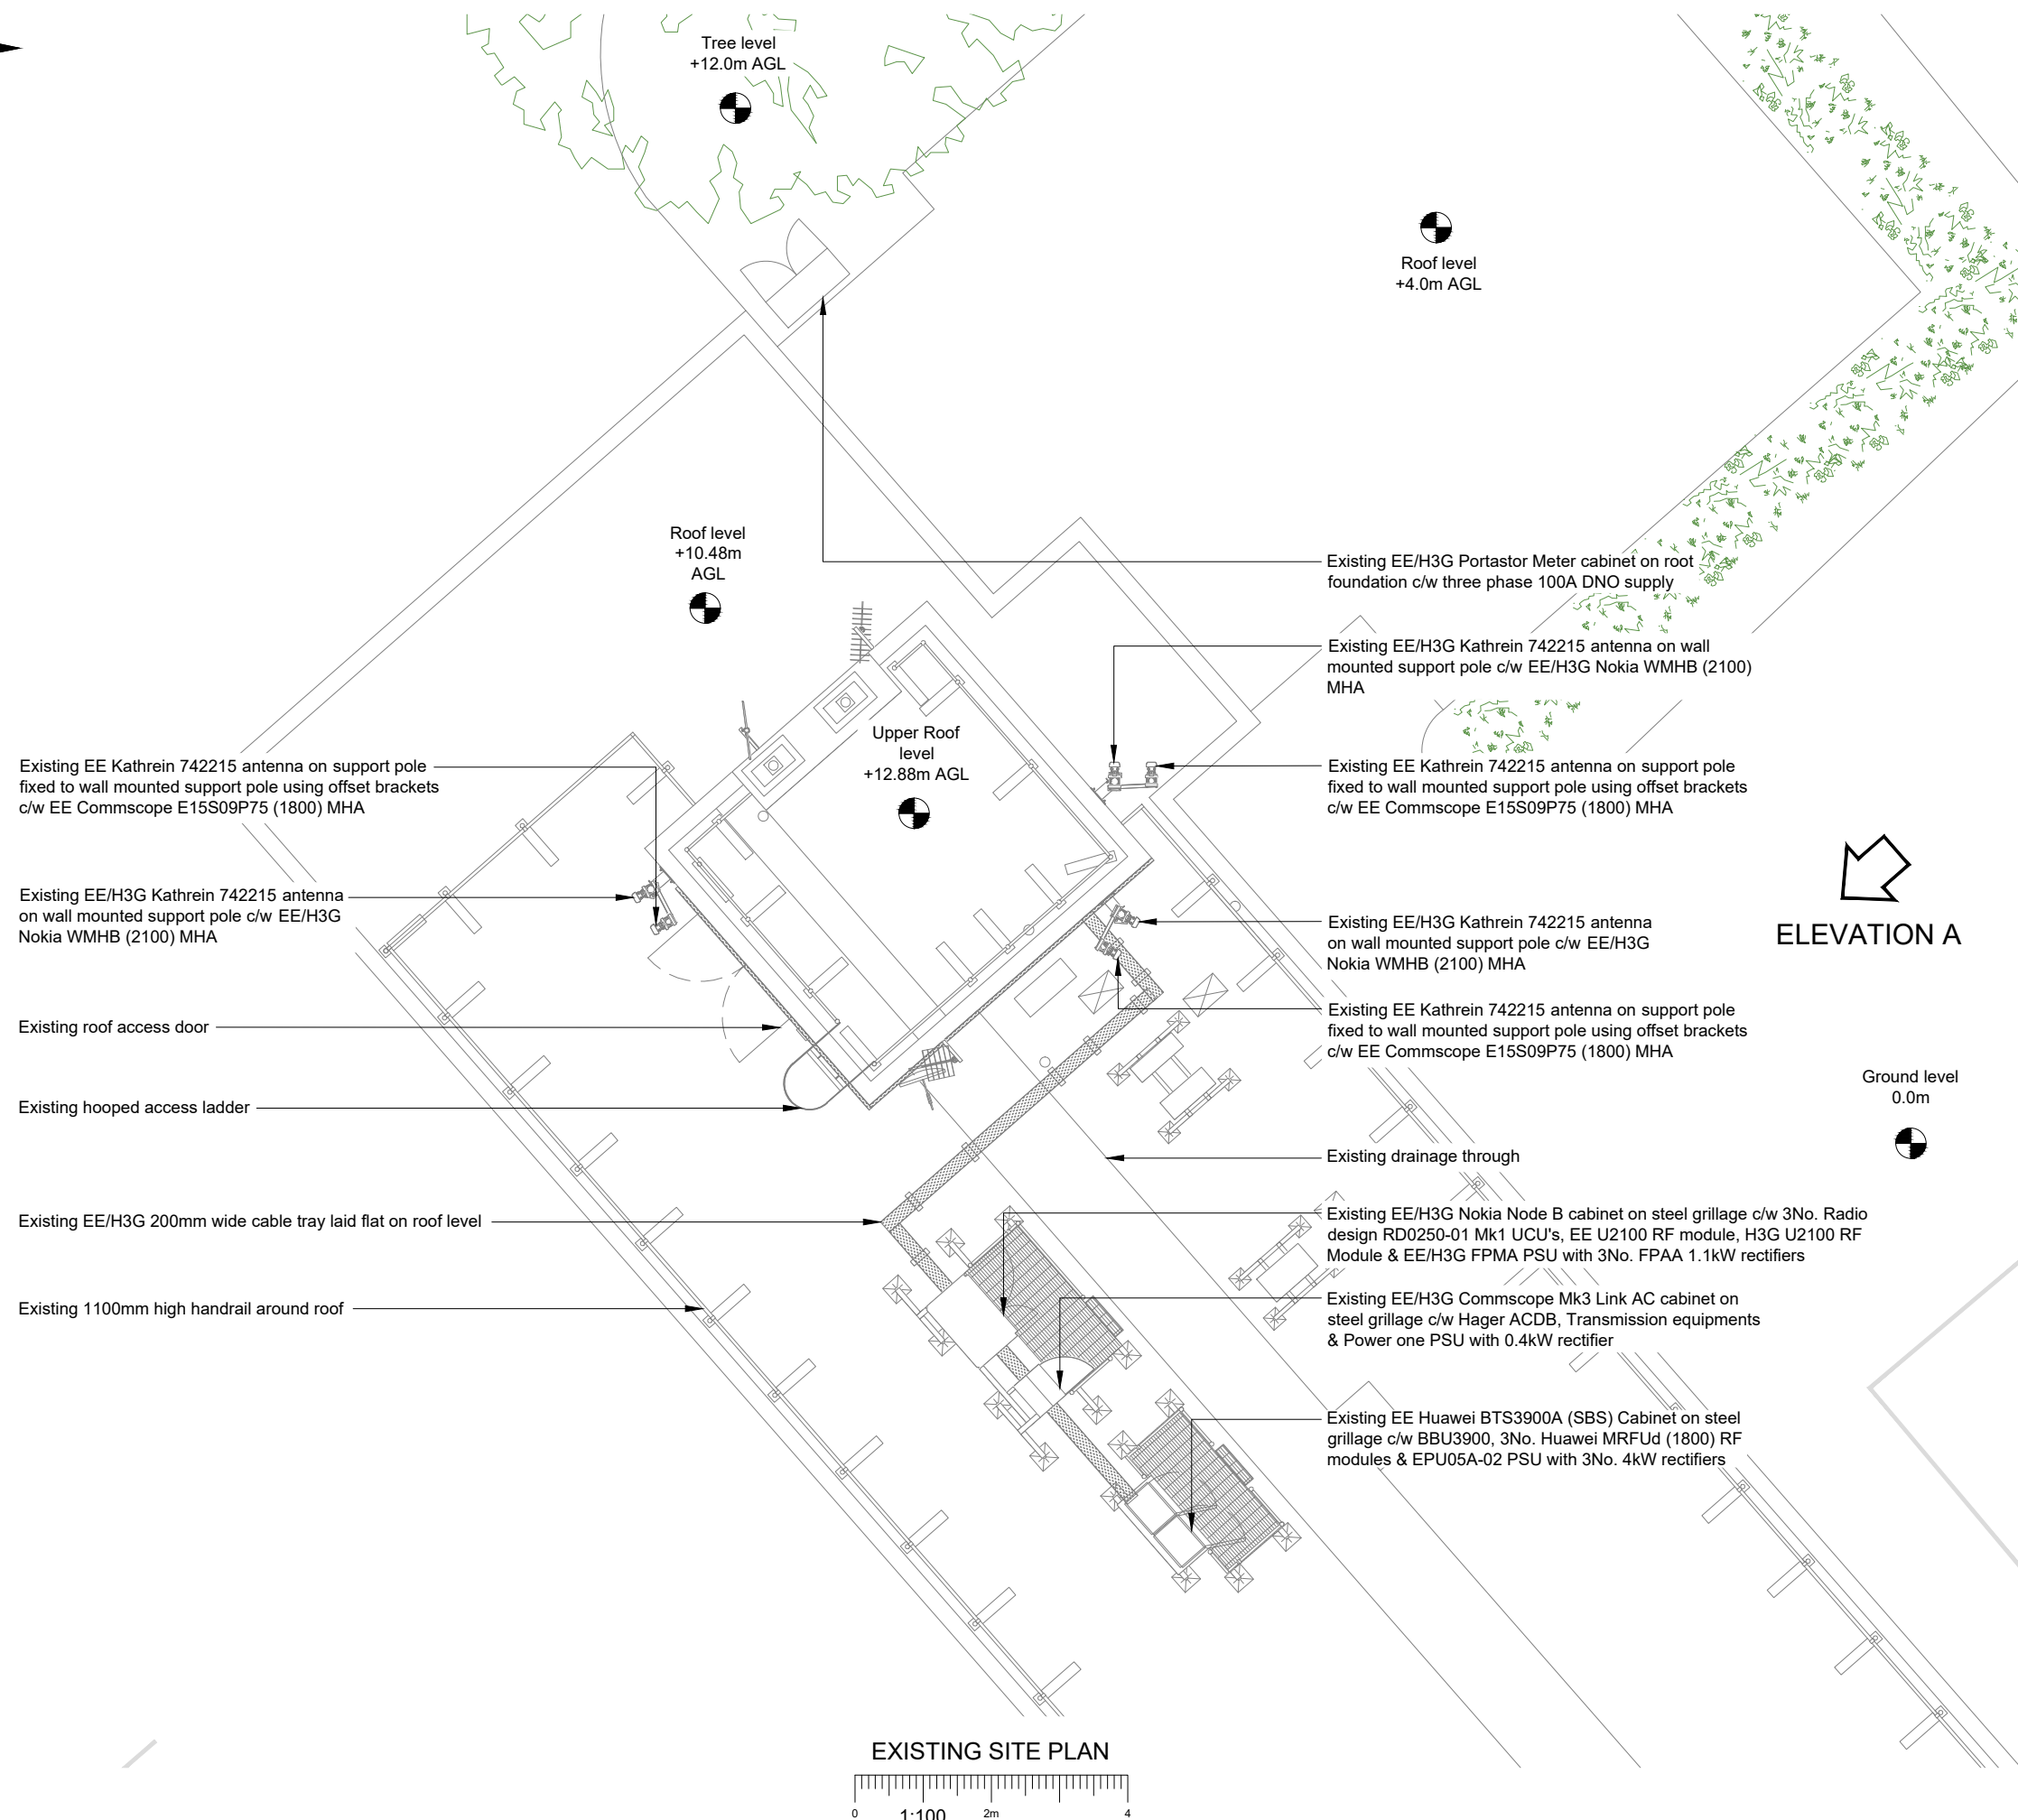

1. ALL DIMENSIONS IN MM UNLESS OTHERWISE NOTED.

Master: M004	MBNL / EE / H3G:	Project: Vendor Swap	Purpose of Issue: Detailed Design	Issue: B1
Date: 03/04/2026		Revision / Upgrade Description: Minor updates		
Drawn: ACL				
Checked: M.Ashworth				
Approved: L.Napolitano				
Master: M003	MBNL / EE / H3G:	Project: Vendor Swap	Purpose of Issue: Detailed Design	Issue: B1
Date: 26/03/2026		Revision / Upgrade Description: Detailed Design - First Issue		
Drawn: R.Raja				
Checked: M.Ashworth				
Approved: L.Napolitano				
Master: M002	MBNL / EE / H3G:	Project: Vendor Swap	Purpose of Issue: General Arrangement	Issue: B
Date: 18/06/2025		Revision / Upgrade Description: Demand updated by BT to add 3.5		
Drawn: R.Raja				
Checked: R.Bembridge				
Approved: L.Napolitano				
Master: M001	MBNL / EE / H3G:	Project: Vendor Swap	Purpose of Issue: General Arrangement	Issue: A
Date: 28/03/2025		Revision / Upgrade Description: First Issue		
Drawn: R.Raja				
Checked: R.Bembridge				
Approved: L.Napolitano				



EE Limited
1 Braham Street
London
United Kingdom
E1 8EE



Site Name: **HORSHAM POLICE STATION**

Site ID: 940666

Address: HORSHAM POLICE STATION
HURST ROAD
HORSHAM
WEST SUSSEX
RH12 2DJ

Title: 100 EXISTING SITE PLAN

Project: **VENDOR SWAP**

Purpose of Issue:	DETAILED DESIGN
-------------------	-----------------

EE Cell ID: 51765	MBNL Cell ID: HSM003	3UK Cell ID: RH0298
-----------------------------	--------------------------------	-------------------------------

Master Drawing No:	Issue:
HSM003 51765 RH0298 EE VS DDD B2	B2