


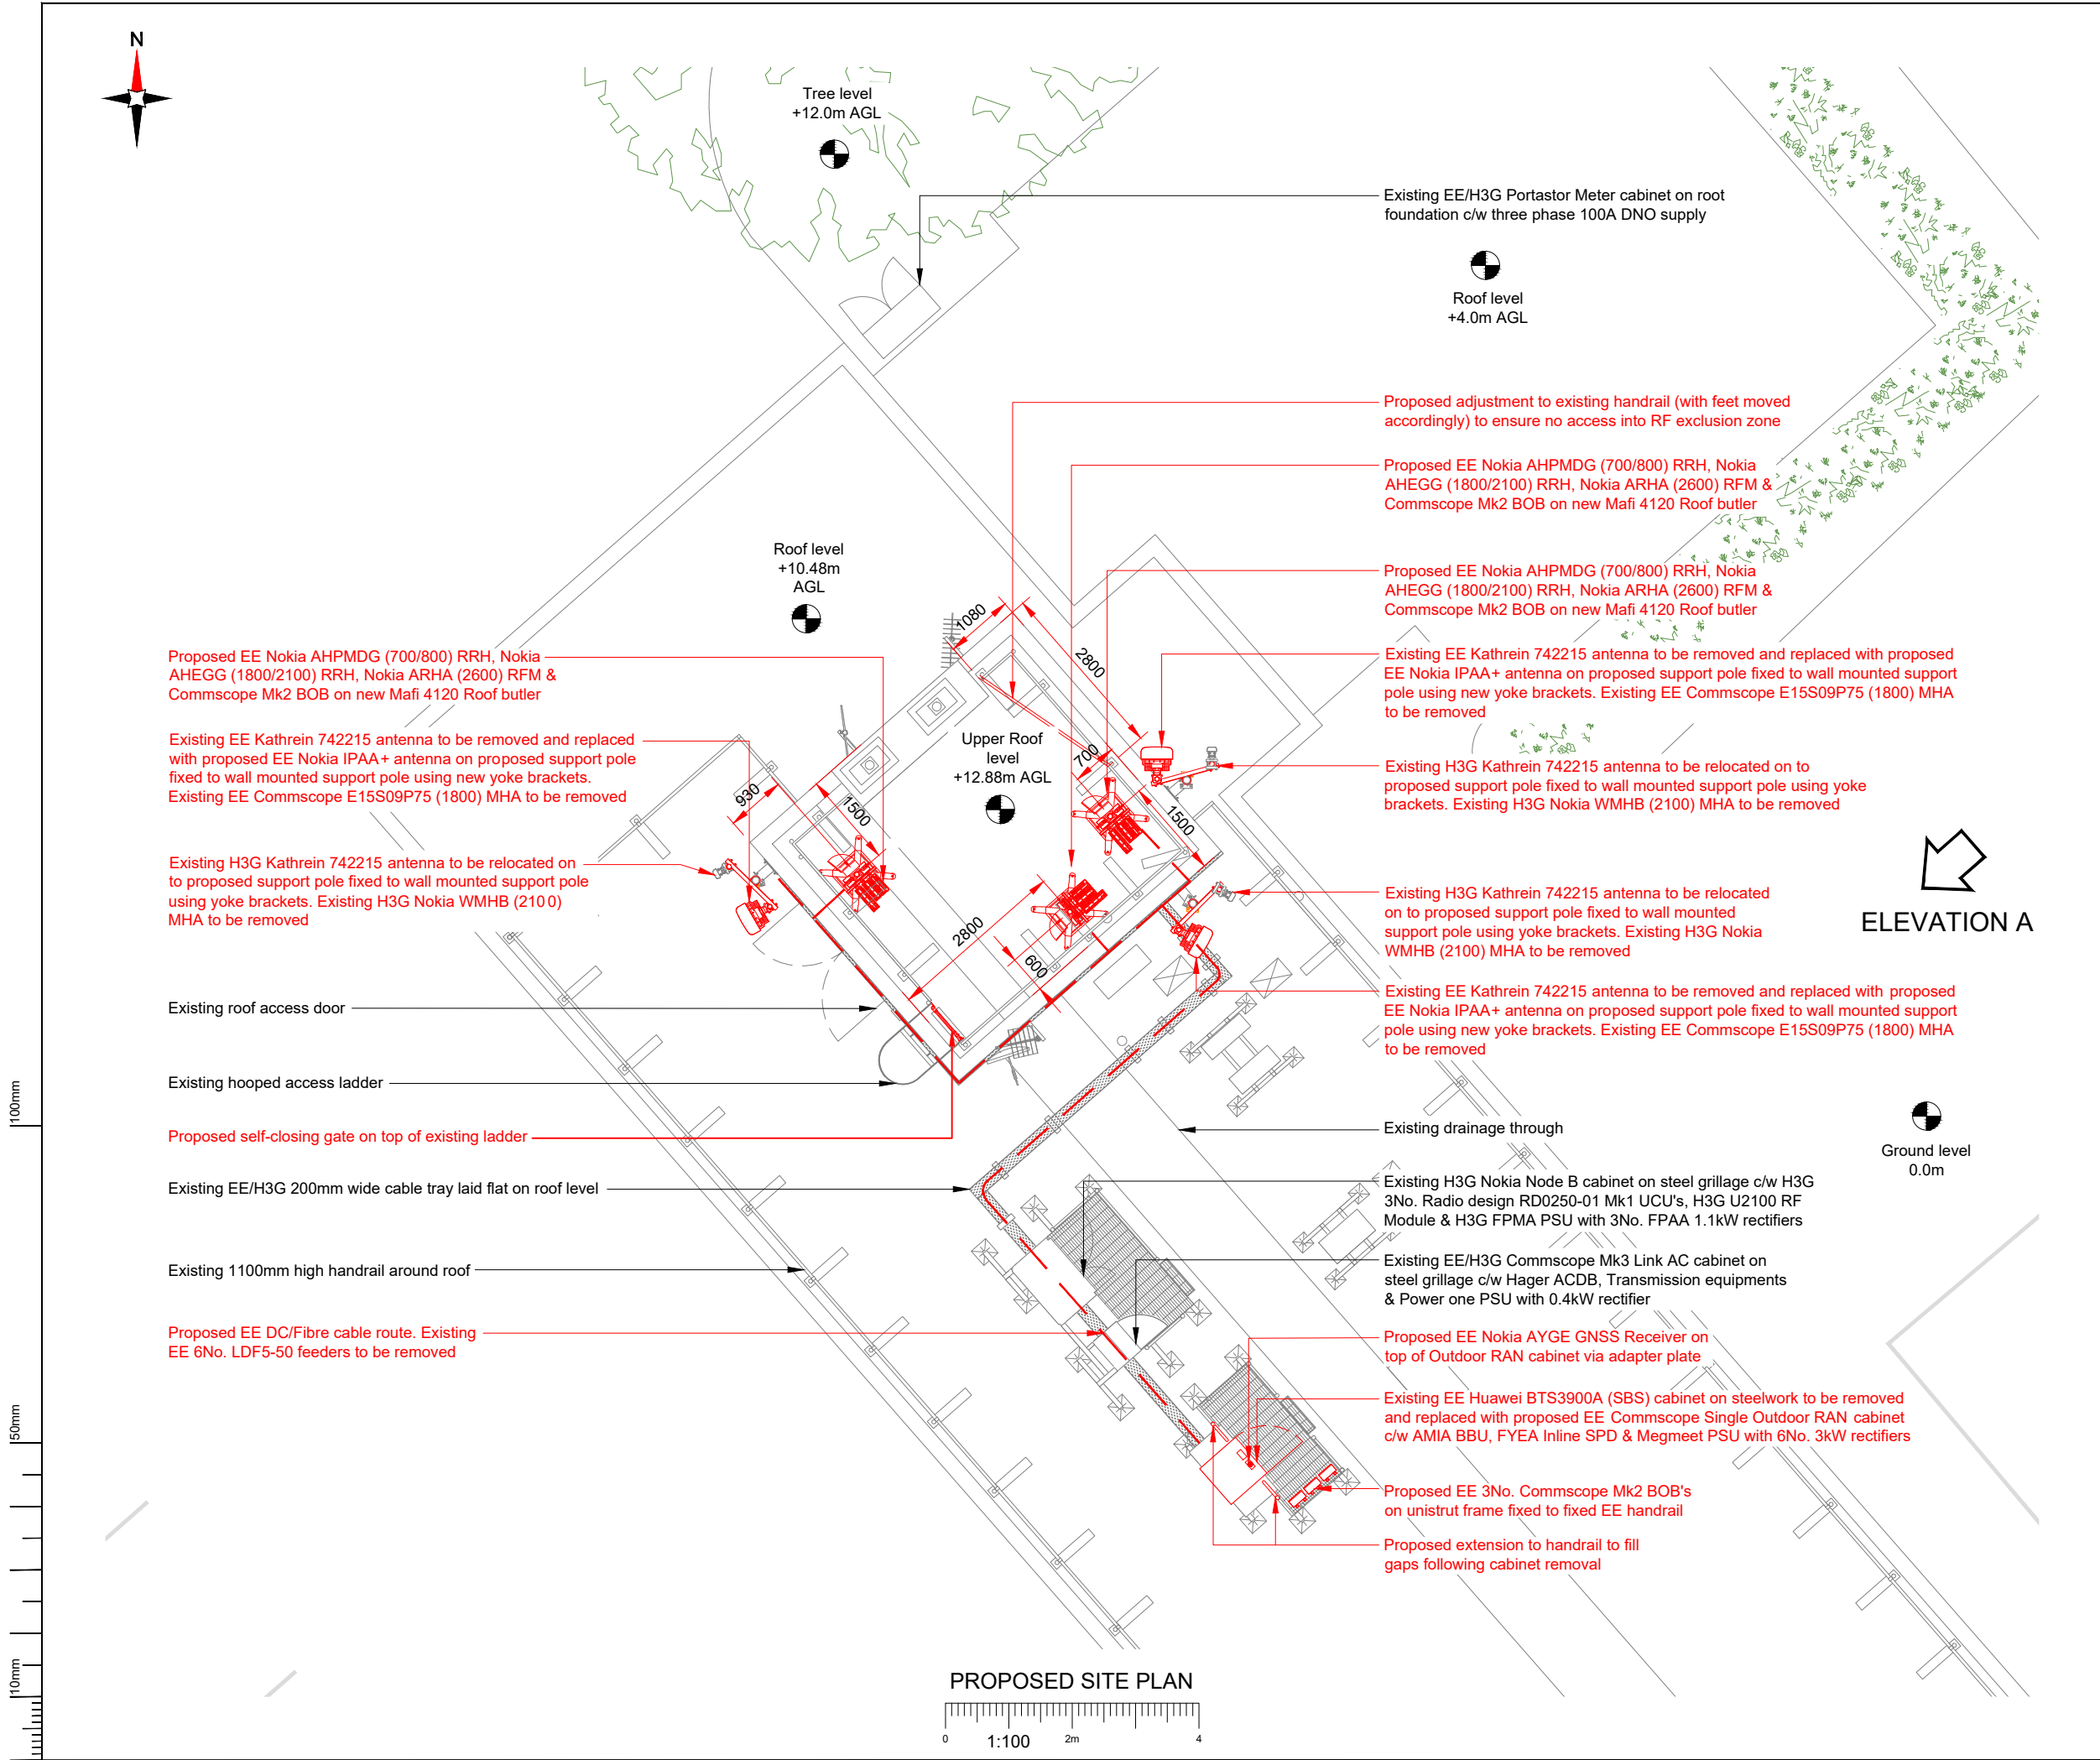

NOTES:

1. ALL DIMENSIONS IN MM UNLESS OTHERWISE NOTED.

Note:
The sub-main power & TX cables run on existing tray beneath the cabinets. All new power cables to use the existing cable tray

Master:	MBNL / EE / H3G:	Project:	Purpose of Issue:	Issue:
M004	EE	Vendor Swap	Detailed Design	B1
Date:	03/04/2026	Revision / Upgrade Description:		
Drawn:	ACL	Minor updates		
Checked:	M.Ashworth			
Approved:	L.Napolitano			
Master:	MBNL / EE / H3G:	Project:	Purpose of Issue:	Issue:
M003	EE	Vendor Swap	Detailed Design	B1
Date:	26/03/2026	Revision / Upgrade Description:		
Drawn:	R.Raja	Detailed Design - First Issue		
Checked:	M.Ashworth			
Approved:	L.Napolitano			
Master:	MBNL / EE / H3G:	Project:	Purpose of Issue:	Issue:
M002	EE	Vendor Swap	General Arrangement	B
Date:	18/06/2025	Revision / Upgrade Description:		
Drawn:	R.Raja	Demand updated by BT to add 3.5		
Checked:	R.Bembridge			
Approved:	L.Napolitano			
Master:	MBNL / EE / H3G:	Project:	Purpose of Issue:	Issue:
M001	EE	Vendor Swap	General Arrangement	A
Date:	28/03/2025	Revision / Upgrade Description:		
Drawn:	R.Raja	First Issue		
Checked:	R.Bembridge			
Approved:	L.Napolitano			



EE Limited
1 Braham Street
London
United Kingdom
E1 8EE



Site Name:
HORSHAM POLICE STATION

Site ID:
940666

Address:
HORSHAM POLICE STATION
HURST ROAD
HORSHAM
WEST SUSSEX
RH12 2DJ

Title:
150 PROPOSED SITE PLAN

Project:
VENDOR SWAP

Purpose of Issue:
DETAILED DESIGN

EE Cell ID: 51765	MBNL Cell ID: HSM003	3UK Cell ID: RH0298
----------------------	-------------------------	------------------------

Master Drawing No: HSM003_51765_RH0298_EE_VS_DDD_B2	Issue: B2
--	--------------