

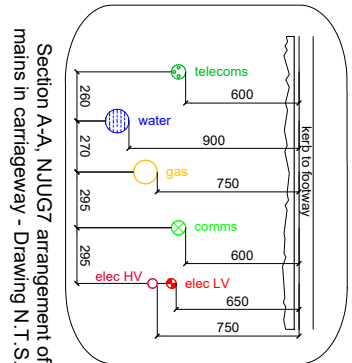
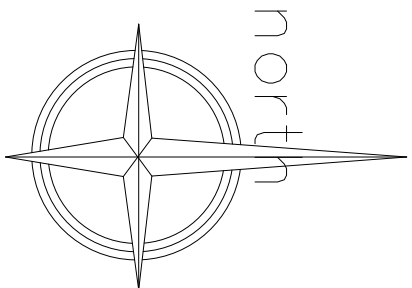


WARNING
ALL EXCAVATION SHOULD BE DONE BY TAKING THE APPROPRIATE SAFETY PRECAUTIONS IN THE "HEALTH & SAFETY EXECUTIVE GUIDE Note47"(HSEg47)
"AVOIDING DANGER FROM UNDERGROUND SERVICES" TAKING COGNIZANCE OF THE FACT THAT OTHER PLANT MAY BE IN THE VICINITY WHICH IS NOT SHOWN ON THE PLANS.

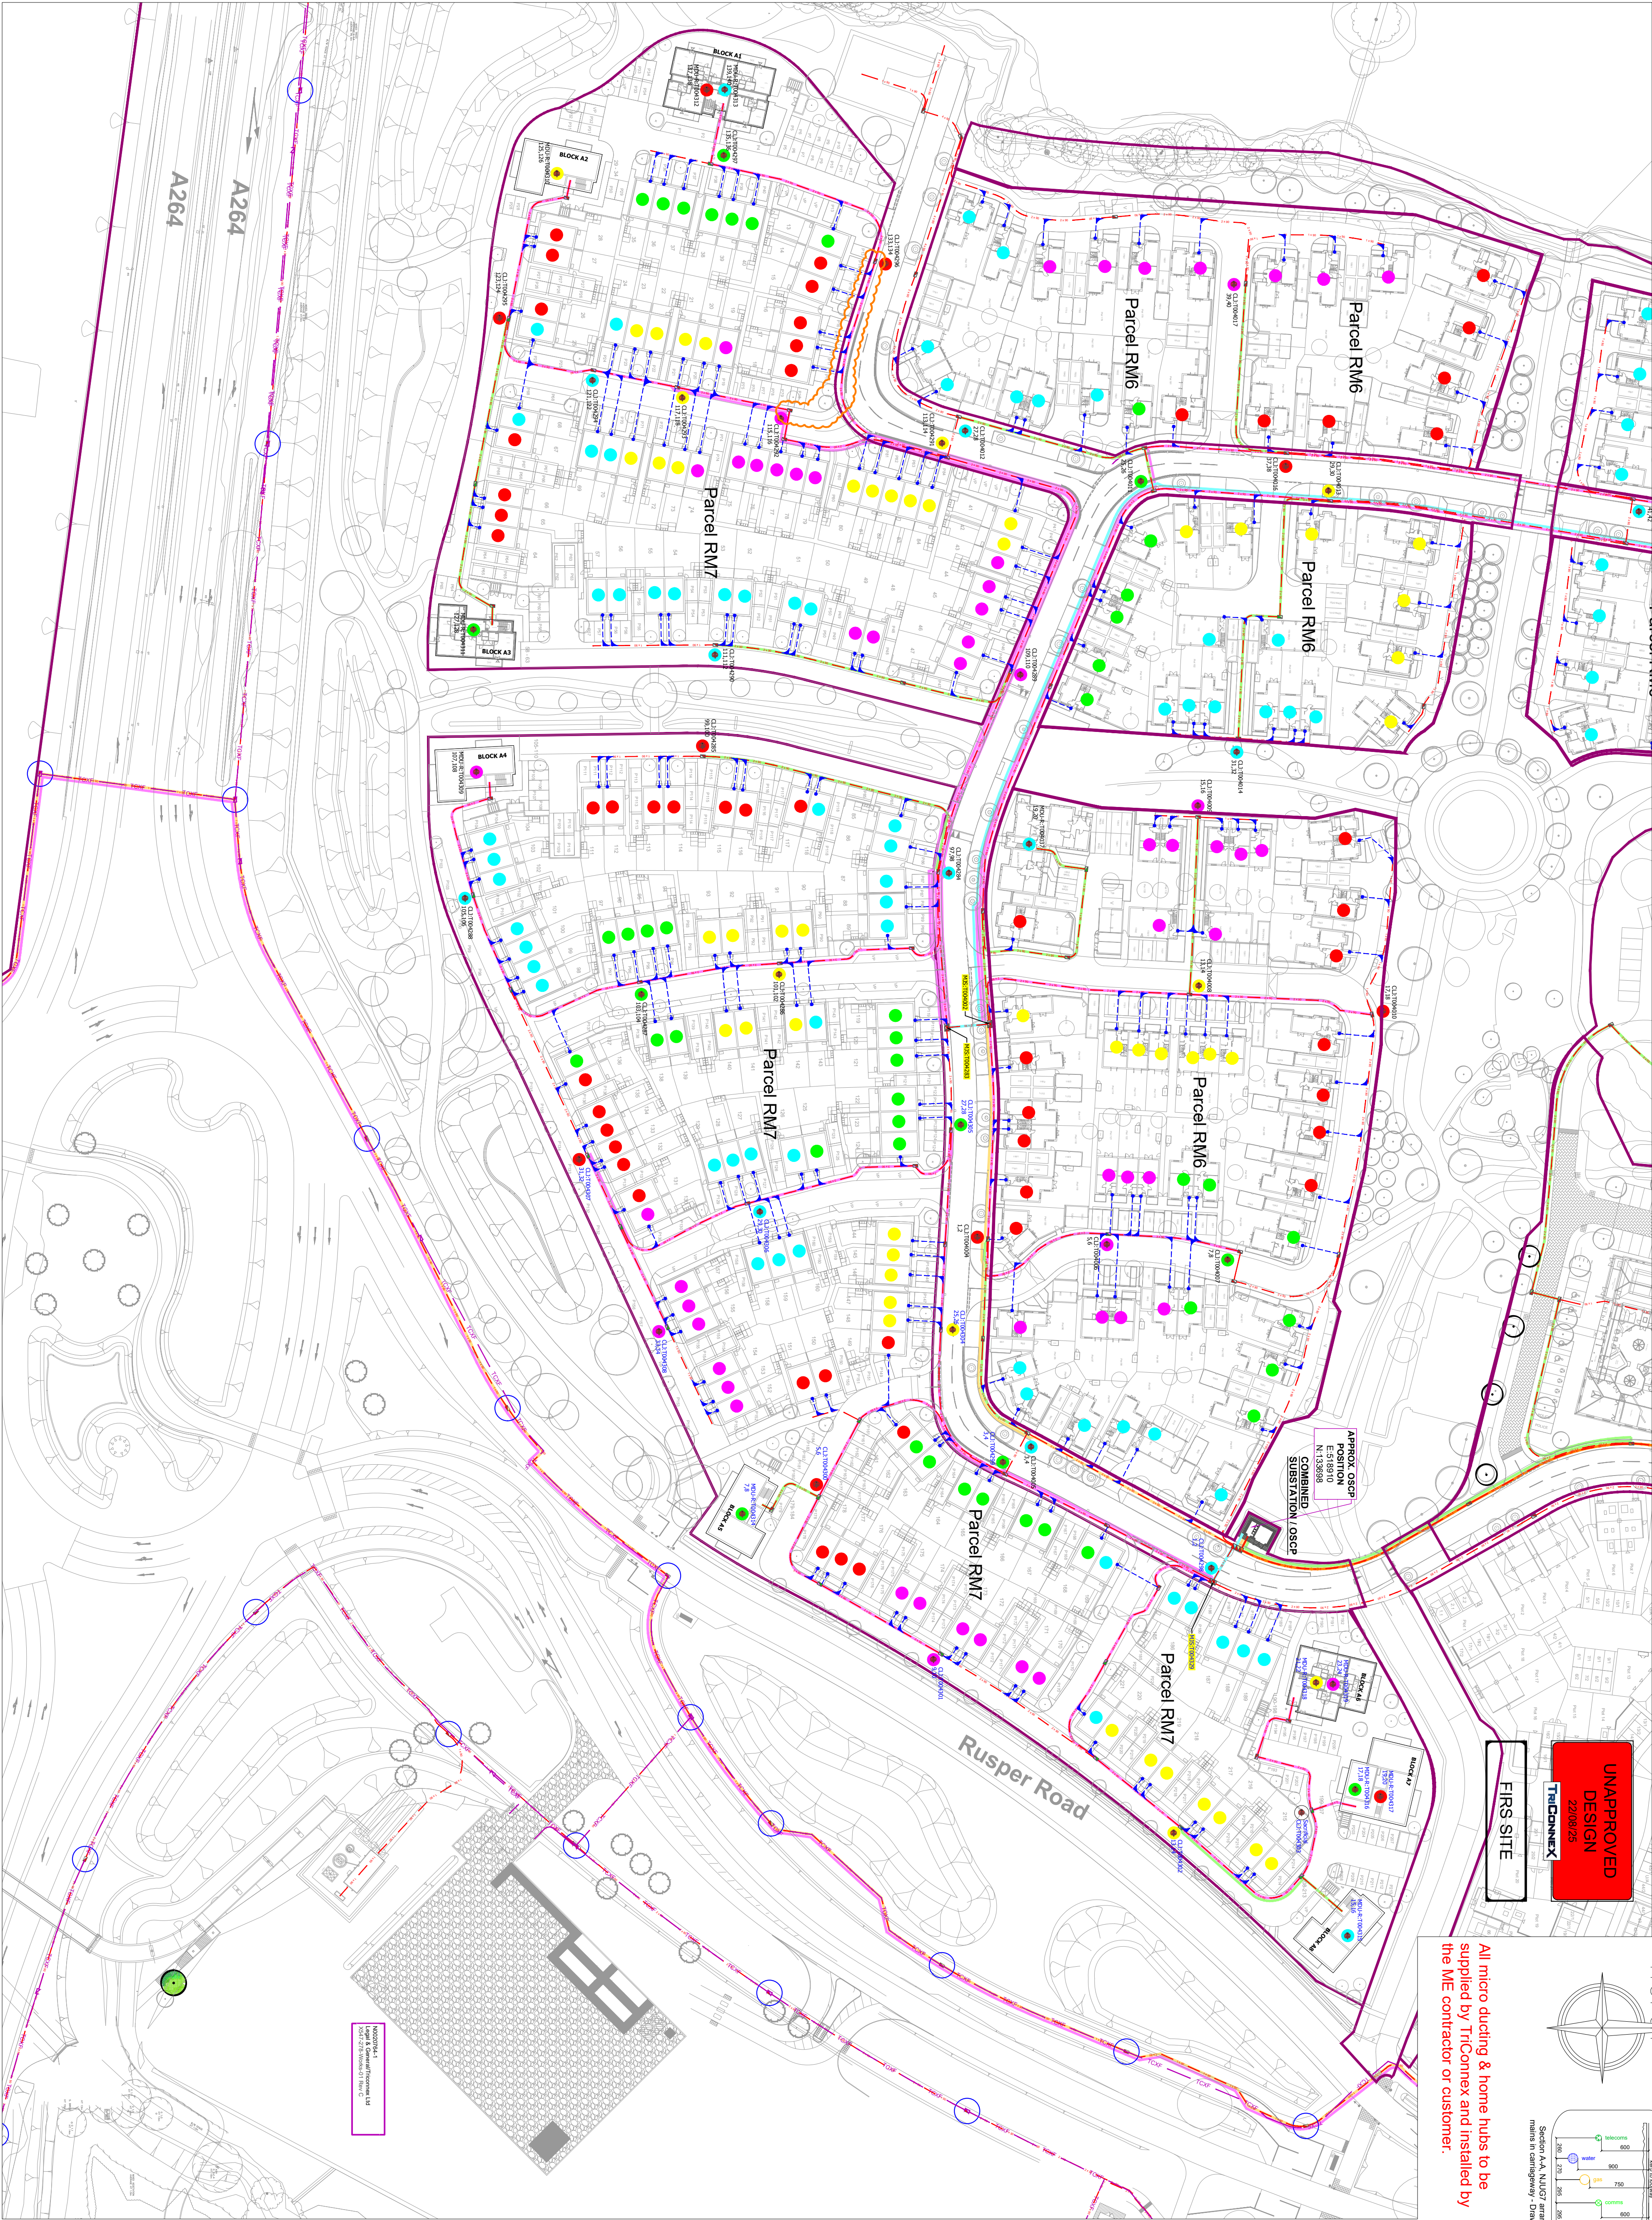


All micro ducting & home hubs to be supplied by Tricomex and installed by the MIE contractor or customer.


FIBRE ALLOCATION

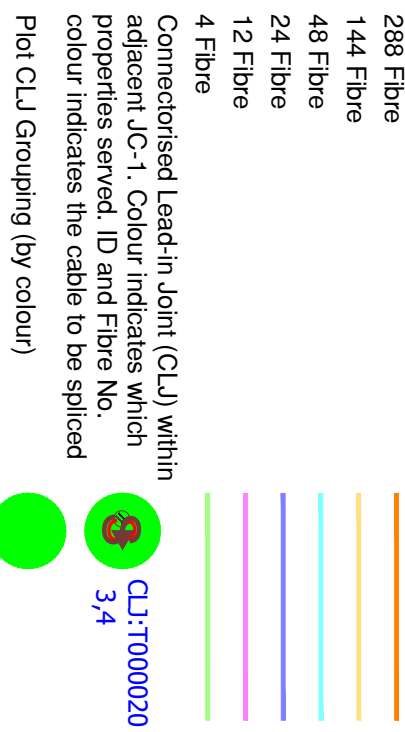


FIBRE DUCTING

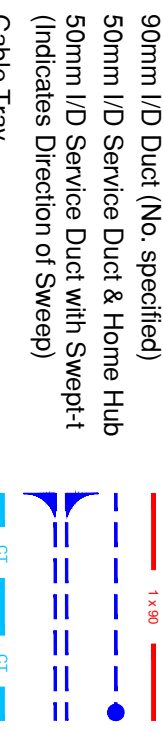

FIBRE CHAMBERS

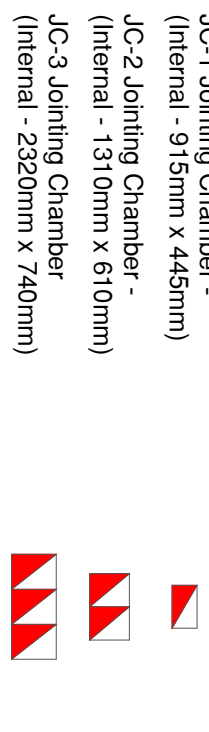

REINFORCED CARRIAGEWAY FIBRE CHAMBERS

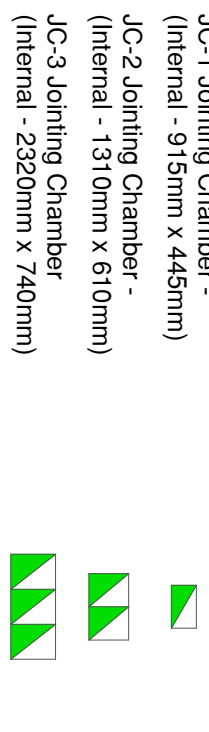

The details provided on this drawing must be read in conjunction with the developer guidelines and all other design and construction specifications. In the event of any conflict, the developer guidelines shall prevail. The positions of existing mains is given for guidance only and, as such, no liability can be accepted by Tricomex for any damage caused to, nor any injury sustained, commence as up to date copy of the relevant utilities records must be obtained.

DATE	DESCRIPTION	REV.	DES.	QC.	Status
16/07/25	Phase RM7 mains dip 286d, 104, 102, 178-215 moved out of pit and emergency. (Note above address).	AY	K.M.	W.I.	
03/07/25	Phase RM7 added to design. Phase RM7&S8 movement by just 195 to avoid drainage. Mains dip 120 moved to footpath. mains dip 2 trimmed back, see rev cloud.	AX	K.M.	W.I.	
22/07/25	Phase RM7 240 duct omitted as not needed. see rev cloud.	BA	K.M.	W.I.	
06/06/25	Phase RM7 mains amended outside 6d, 67 to be on the same side of road and are parallel. see rev cloud.	AZ	K.M.	W.I.	

Site plan: 4100001 Rev. 01
Status key: A - Approved, D - Draft, U - Unapproved
Note: No liability of any kind what so ever is accepted by Tricomex Ltd or its representatives for any damage caused to, nor any injury sustained, commence as up to date copy of the relevant utilities records must be obtained. The actual position of utilities and other apparatus on site before any mechanical plant is used. It is your responsibility to ensure that this working on or near any utilities.

TRICOMNEX

4 Tandown Way, Banham,
Eassey, CN7 2DL
Email: info@tricomex.co.uk
Tel: 01506 332 680
www.tricomex.co.uk

FIBRE NETWORK DESIGN

SITE ADDRESS
RH12 4QR, Rusper Road, Horsham

STATUS
APPROVED

SCALE
1:750 ON A1

NETWORK NUMBER
X547

DRAWING NUMBER
X547-RM7-FND-01

CLIENT
Dandara

NOTE: All service routes are indicative only and must be confirmed on site by the installation contractors representative. It is the responsibility of the customer to ensure that all service routes are within the demise of the property being supplied and the exact location of ducts are clearly identified.

COPYRIGHT: Not to be reproduced without written permission
A1

TCS STD 010/9
September 2019/9