 



EMERGENCY LIGHTING LEGEND

	PHOTO-LUMINESCENT EMERGENCY EXIT SIGN
	EMERGENCY EXIT LIGHT
	EMERGENCY BULKHEAD
	EMERGENCY BULKHEAD WEATHER-PROOF


SOLUS SL102




GROUND FLOOR

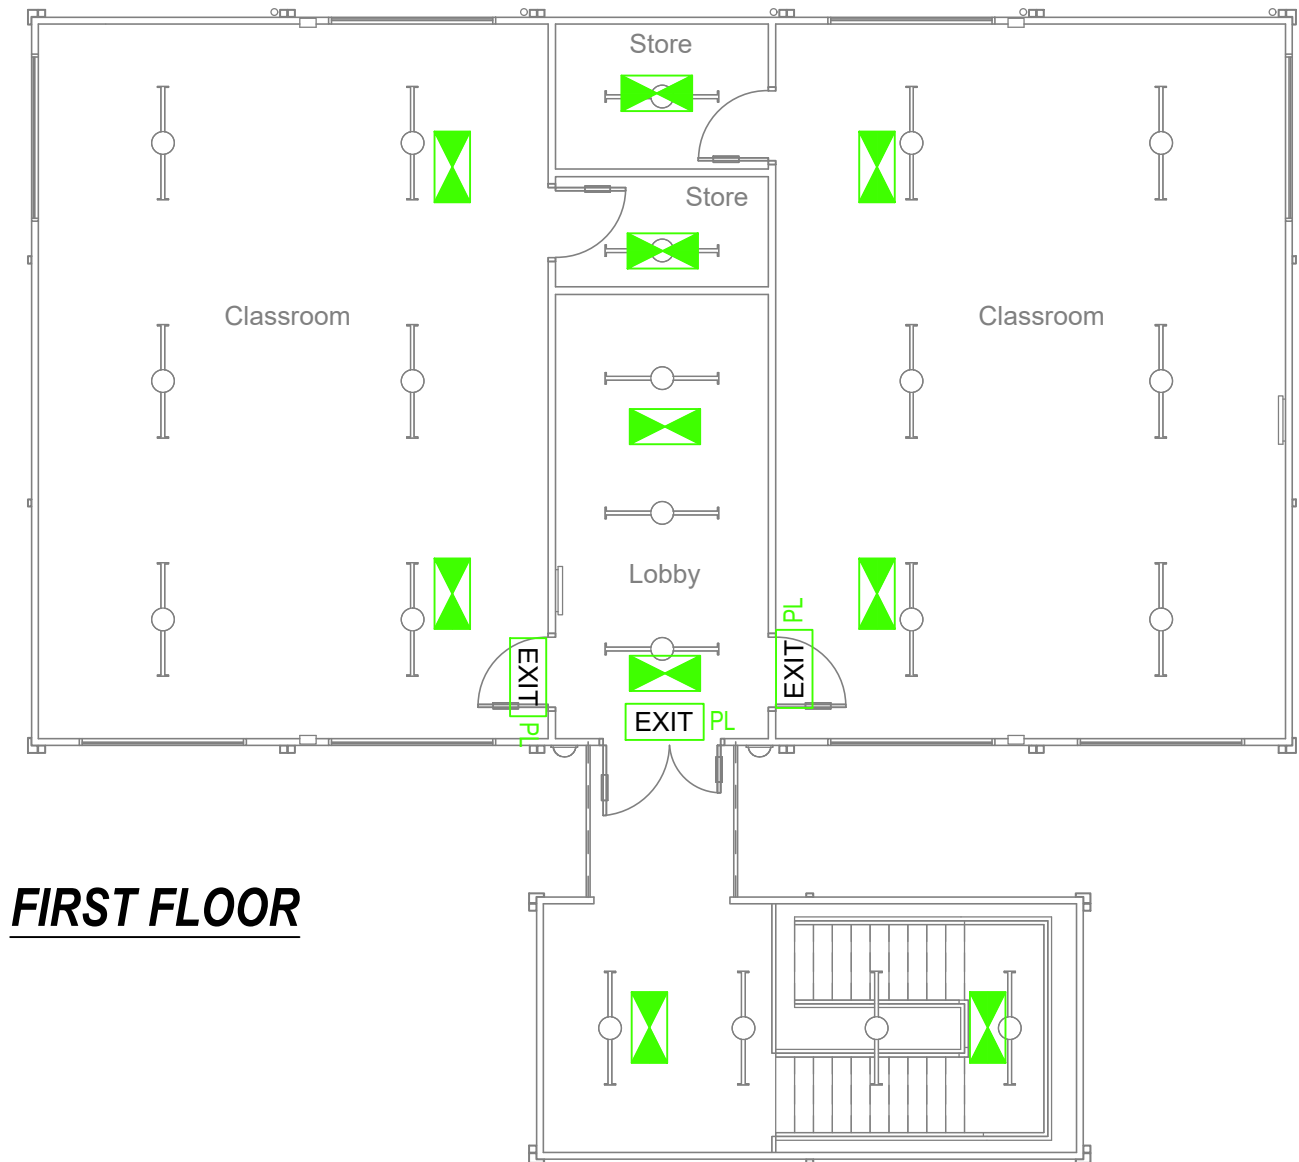


FIRST FLOOR

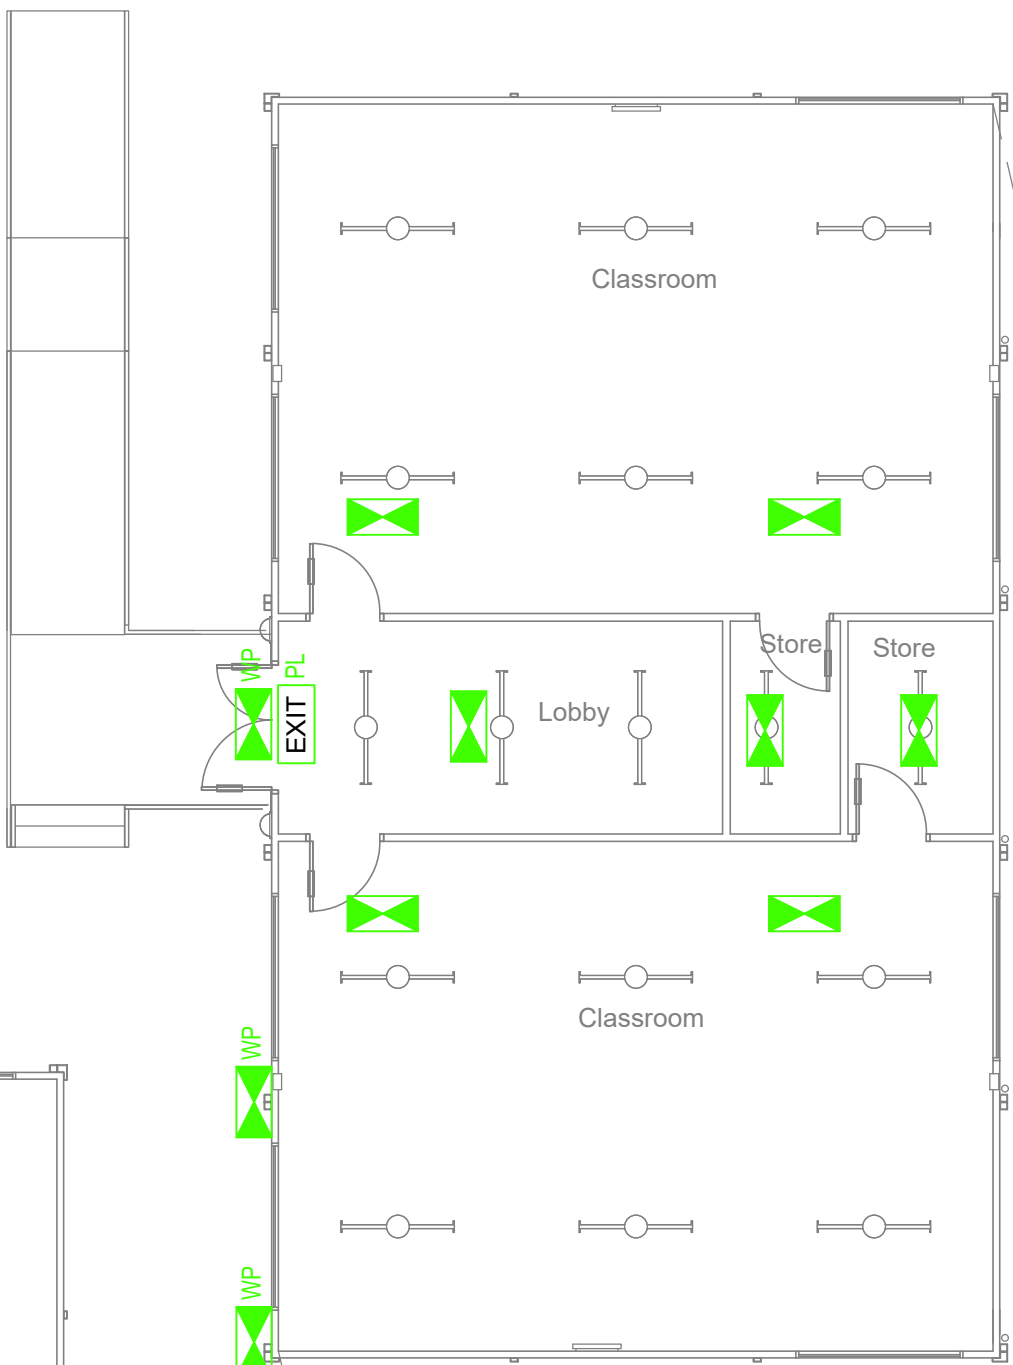


GROUND FLOOR

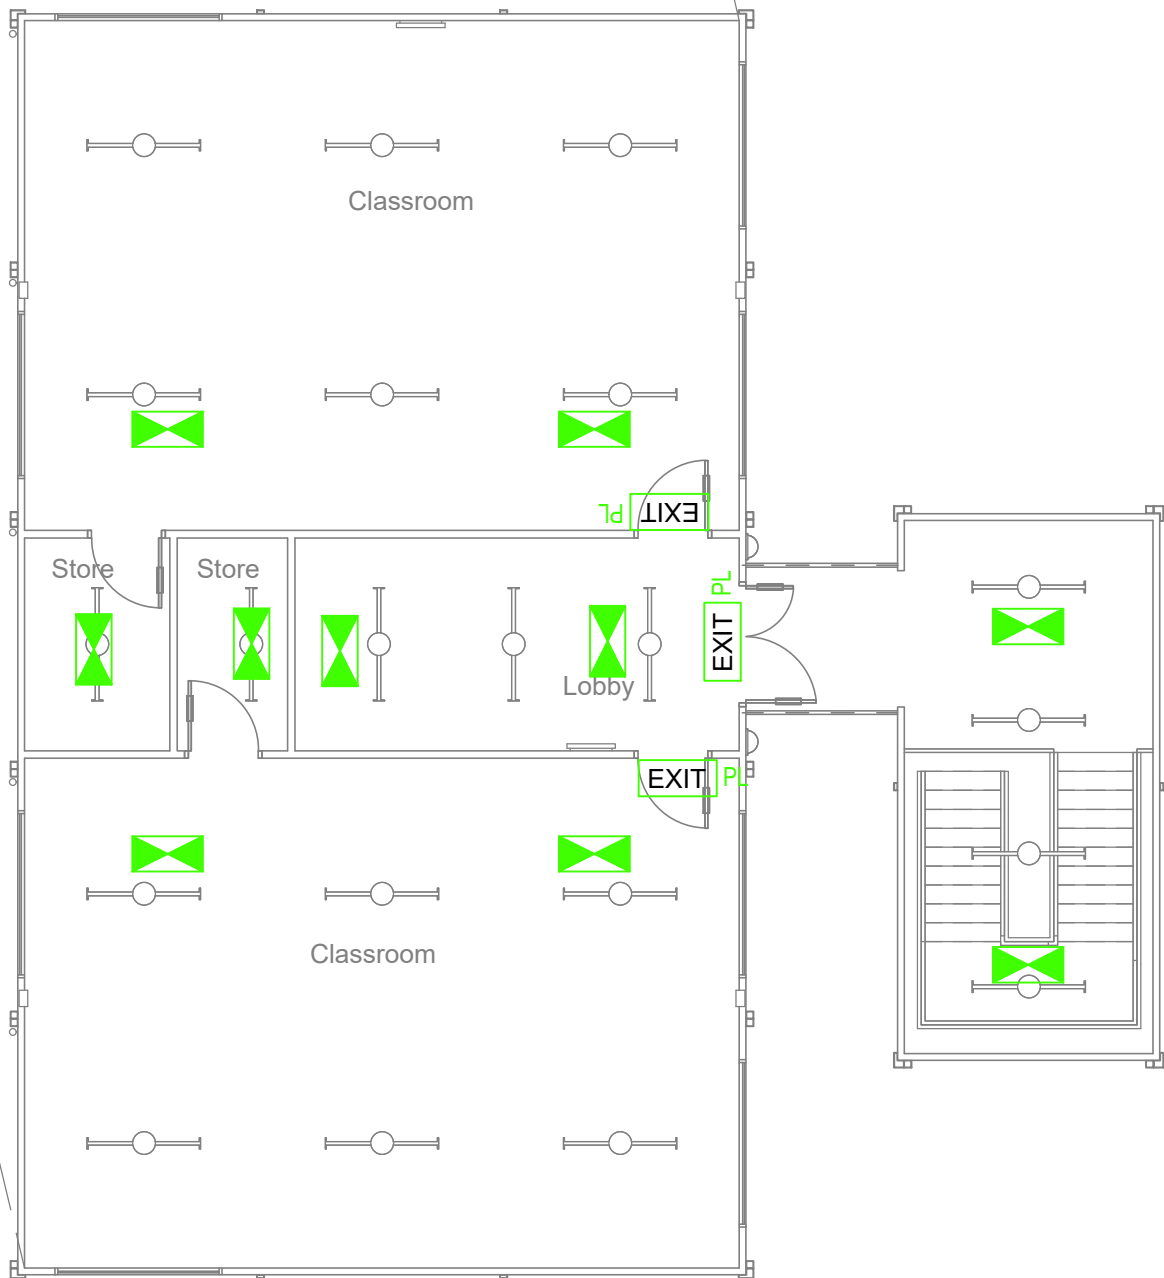


FIRST FLOOR

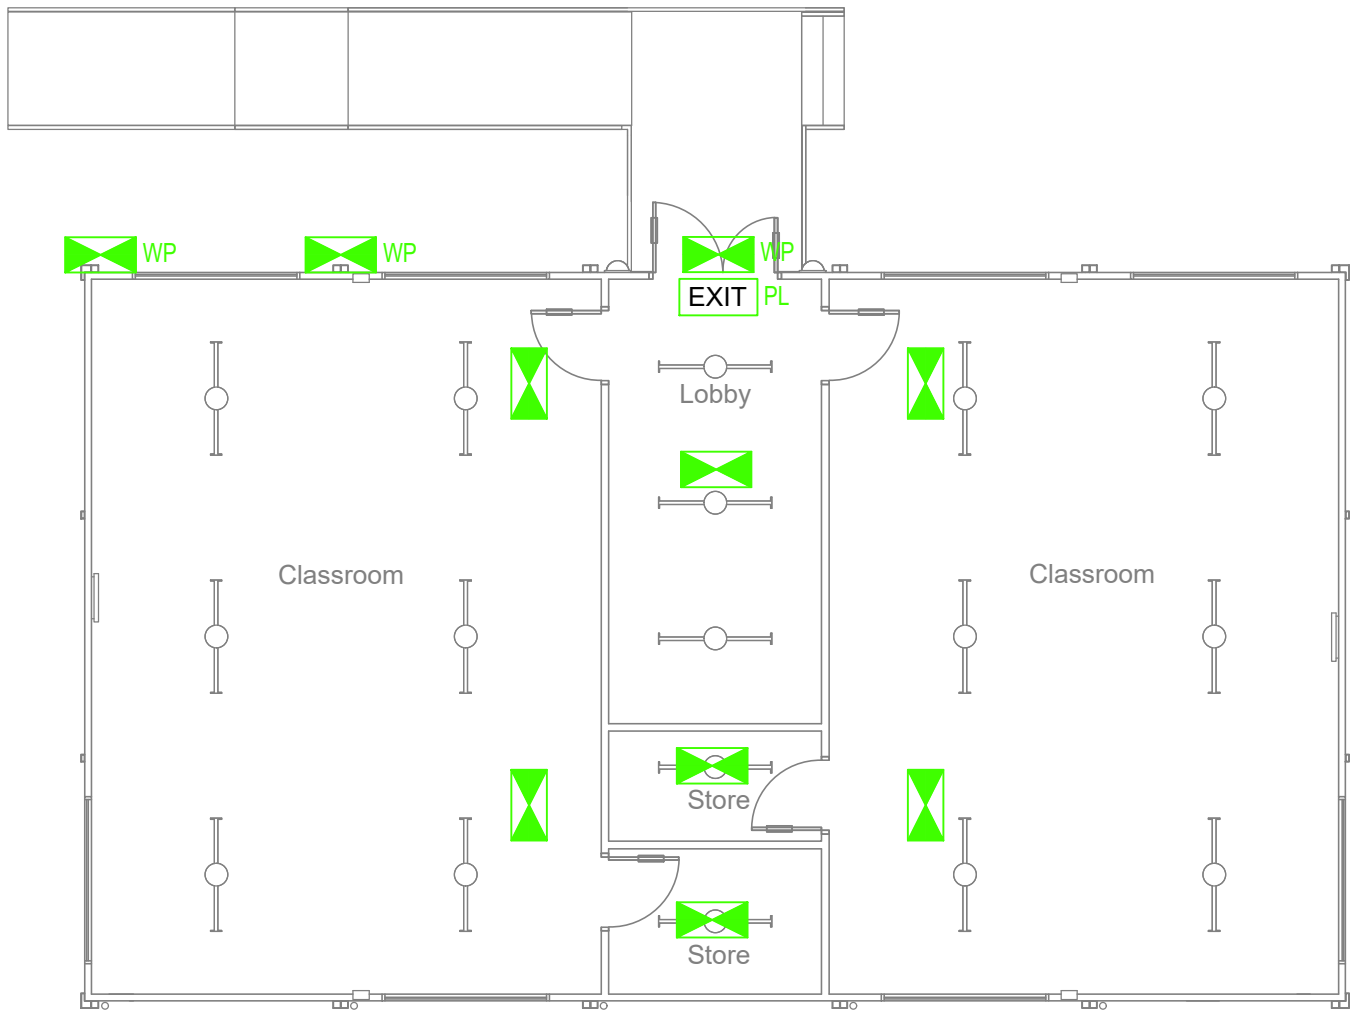

NEW DOUBLE CLASSROOM BLOCK

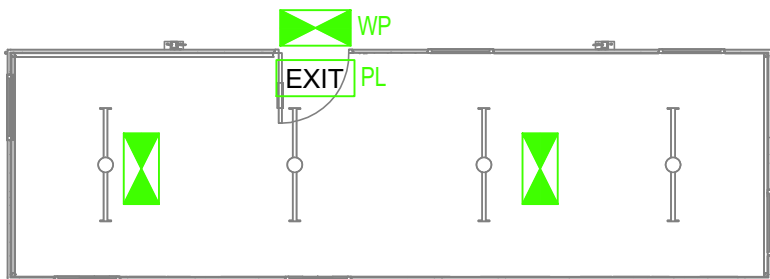

SOLUS SL102 - NEW UNIT

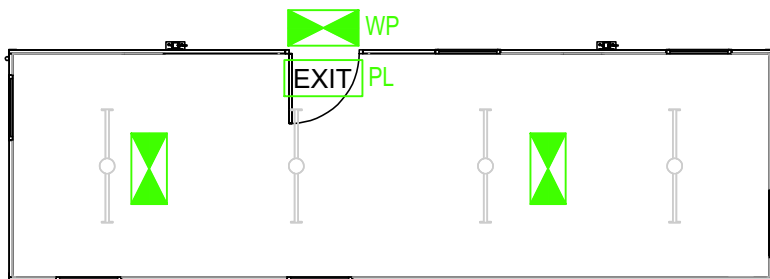

SOLUS SL102

EMERGENCY LIGHTING LAYOUT

B	20/05/2026	SL102 & Double classroom block added	JL
A	09/04/2025	First Floor units & Solus Unit added	JL
Rev	Date	Changes	Chd
			
Project: College of Richard Collyer			
Drawing Title: Portakabin Blocks Ground Floor Emergency Lighting Layout			
Scale: 1:100		Plot size: A1	
Date: 25/04/2024		Drn: IRC	Chd: JL
Job No: PK-CoRC01	Drawing No: PK-CoRC01-EML01		Rev: B