



FIRE ALARM LEGEND

FAP	FIRE ALARM CONTROL PANEL
FRP	FIRE ALARM REPEATER PANEL
FAI	FIRE ALARM INTERFACE PANEL
IUF	INTERFACE UNIT
M	MAGNETIC DOOR HOLDER
S	SMOKE DETECTOR
S<	SMOKE DETECTOR / SOUNDER BASE
S<B	SMOKE DETECTOR / SOUNDER / BEACON
H	HEAT DETECTOR
H<	HEAT DETECTOR / SOUNDER BASE
H<B	HEAT DETECTOR / SOUNDER / BEACON
S<B	SOUNDER
S<B	SOUNDER BEACON
S<B	BEACON
MC	MANUAL CALL POINT
FAS	FIRE ALARM SUPPLY (RED KEY SWITCH)


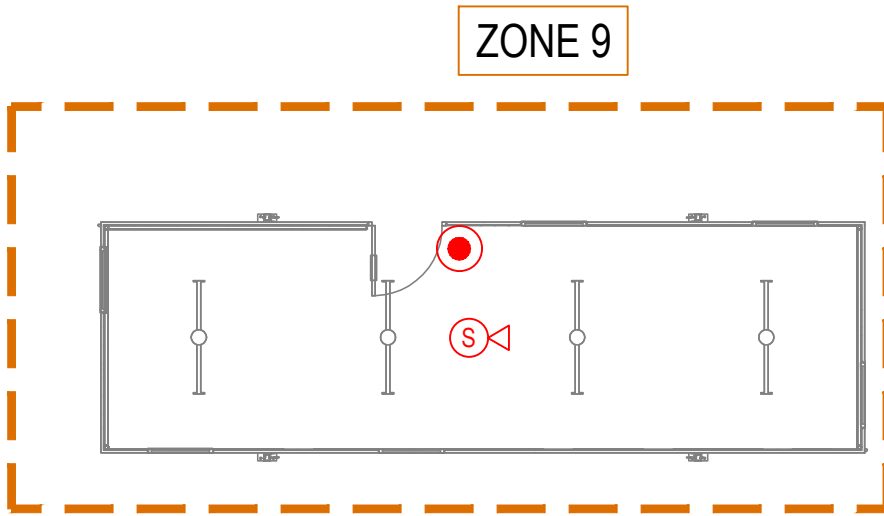


SOLUS SL102 - NEW UNIT


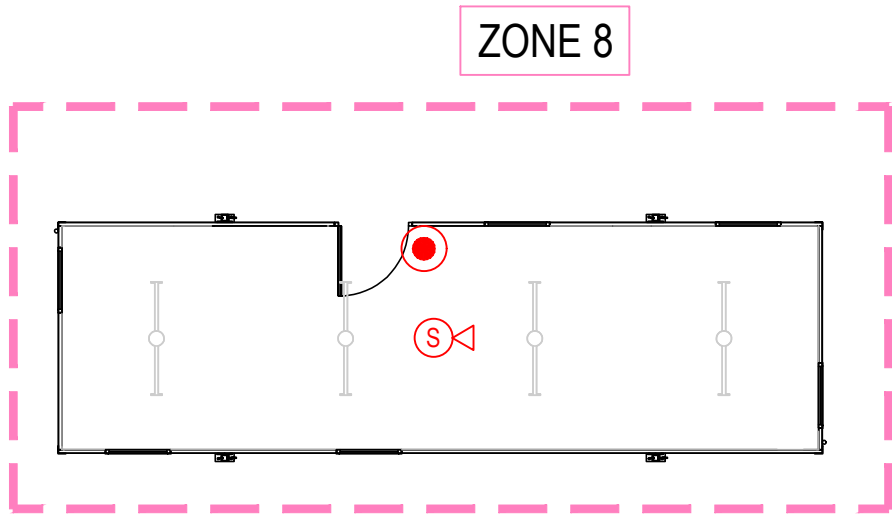


SOLUS SL102


GROUND FLOOR

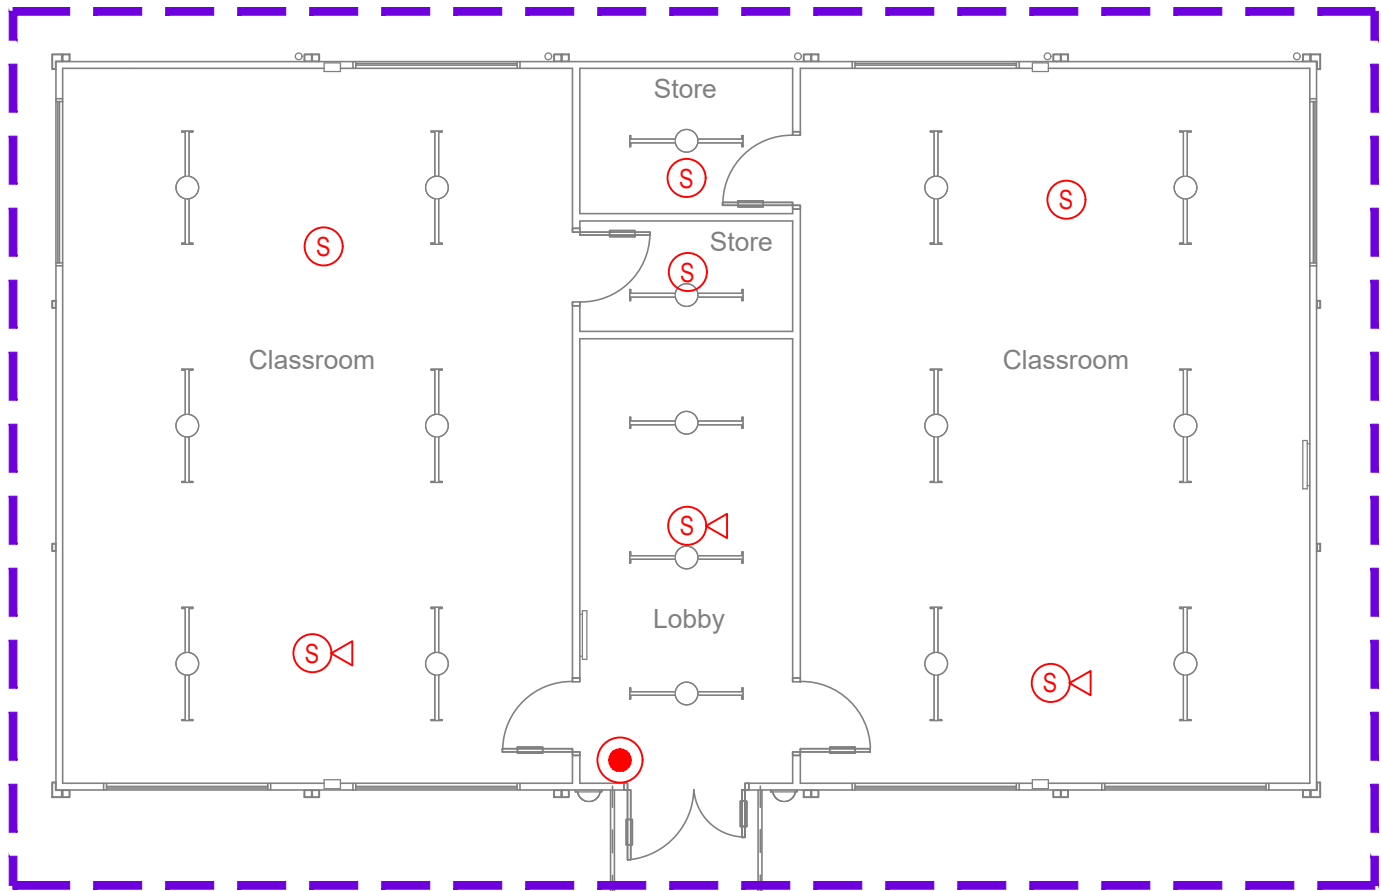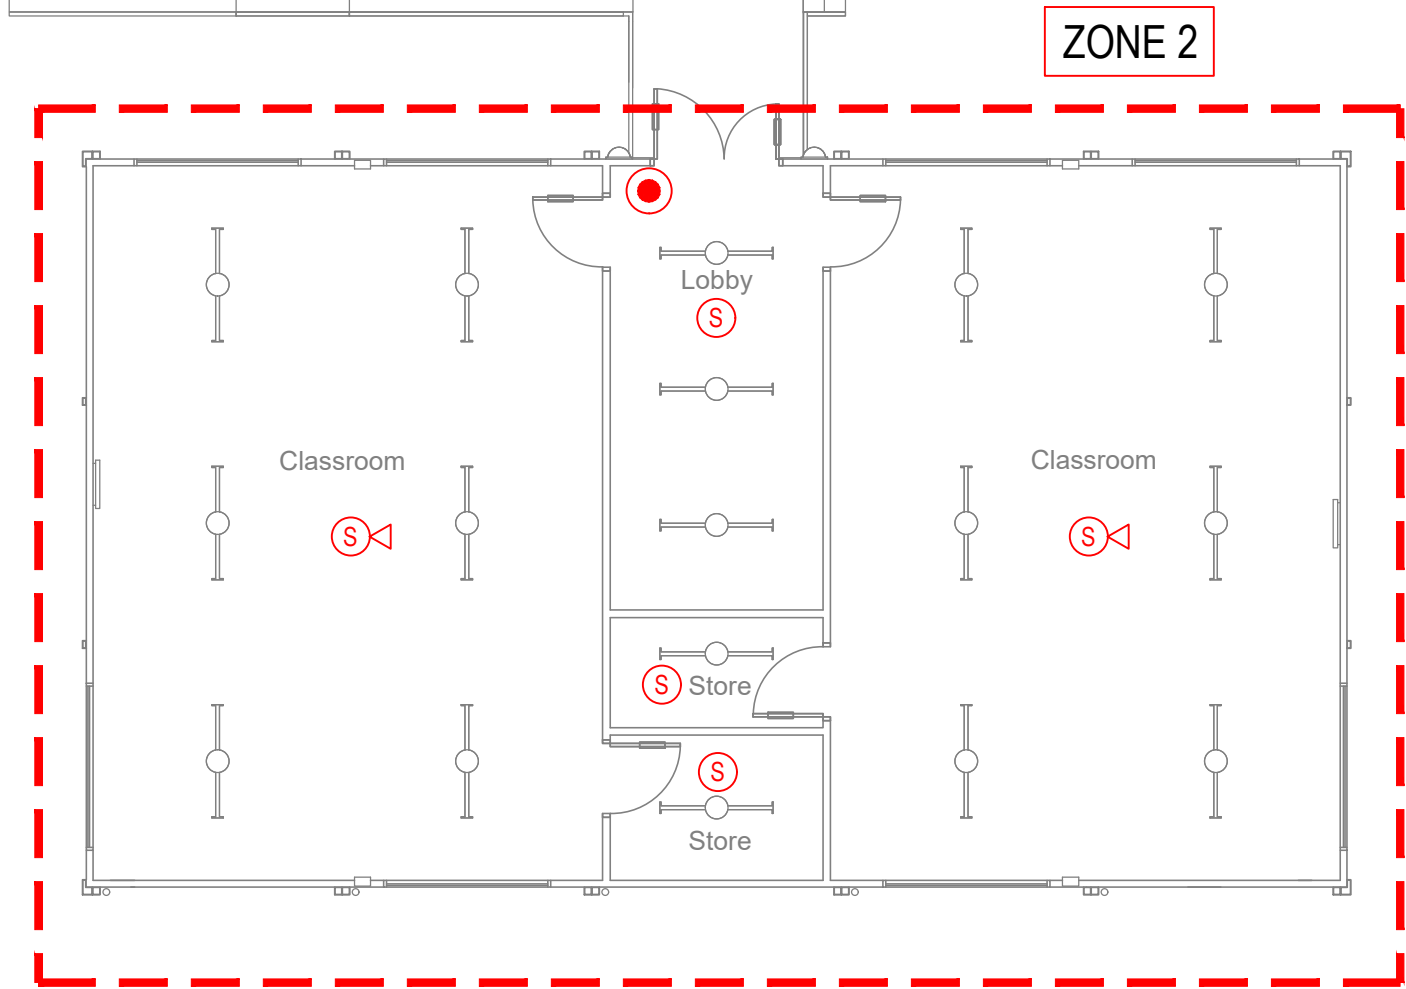


FIRST FLOOR

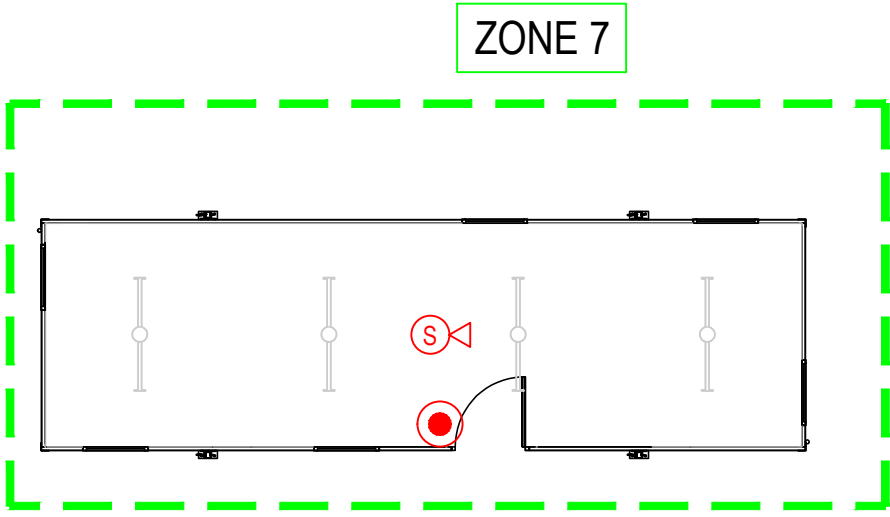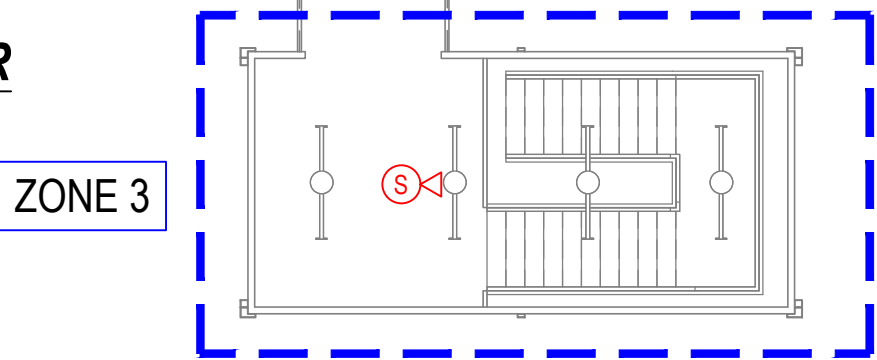



SOLUS SL102

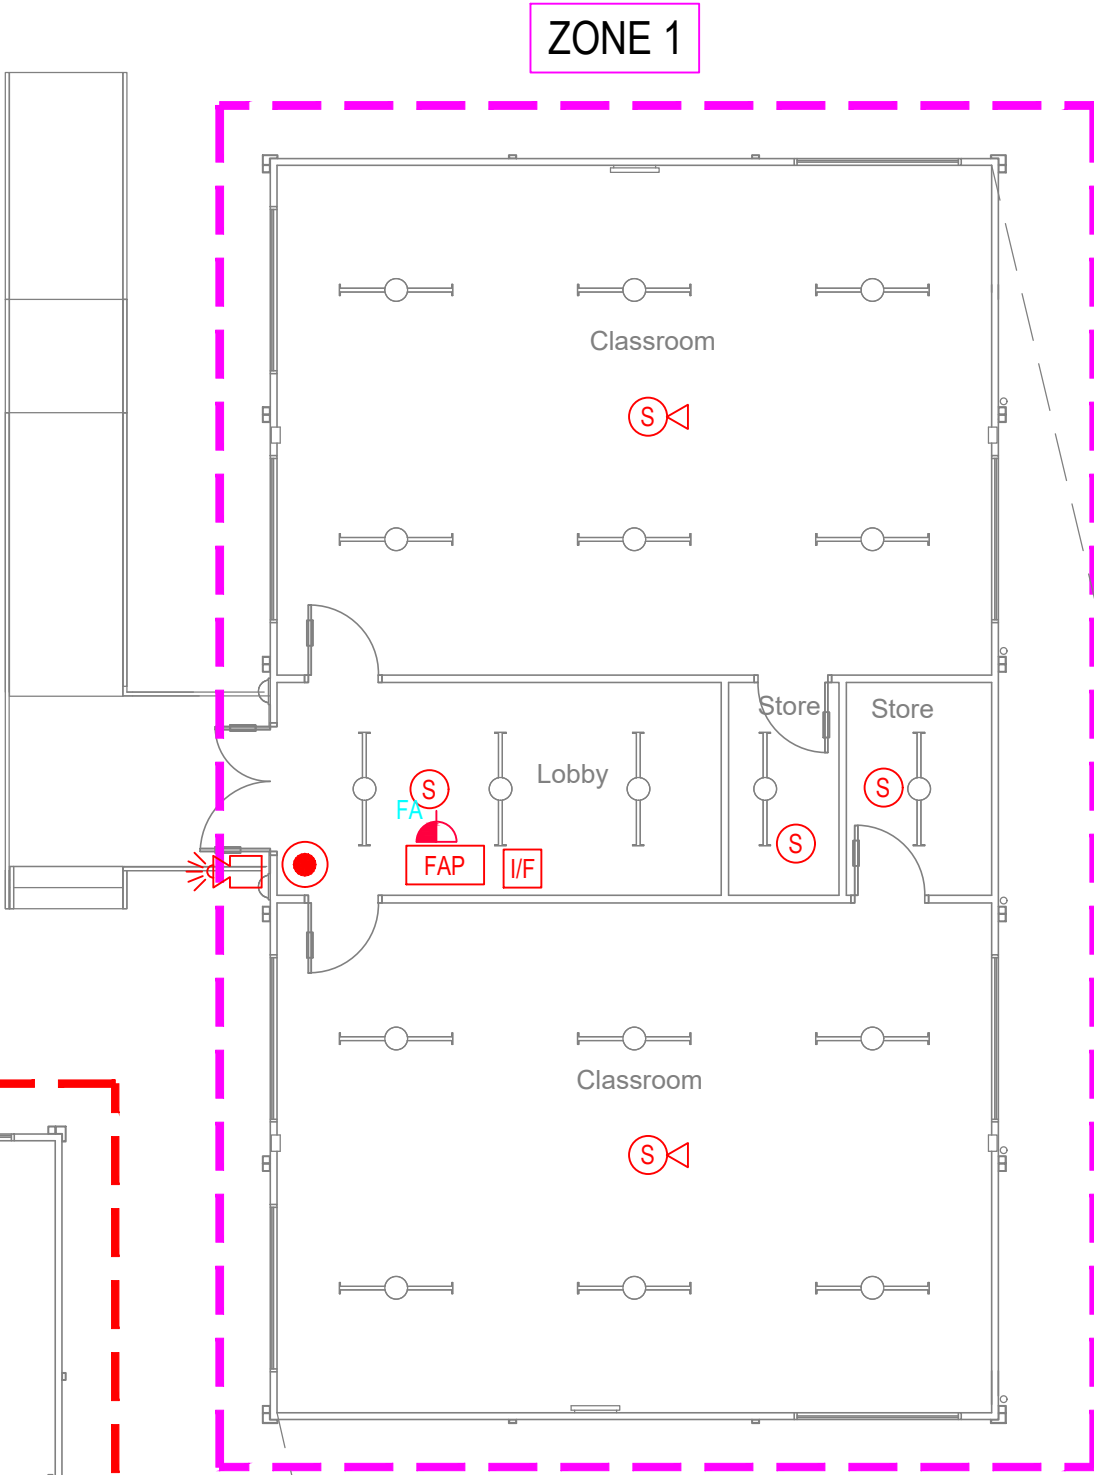

GROUND FLOOR

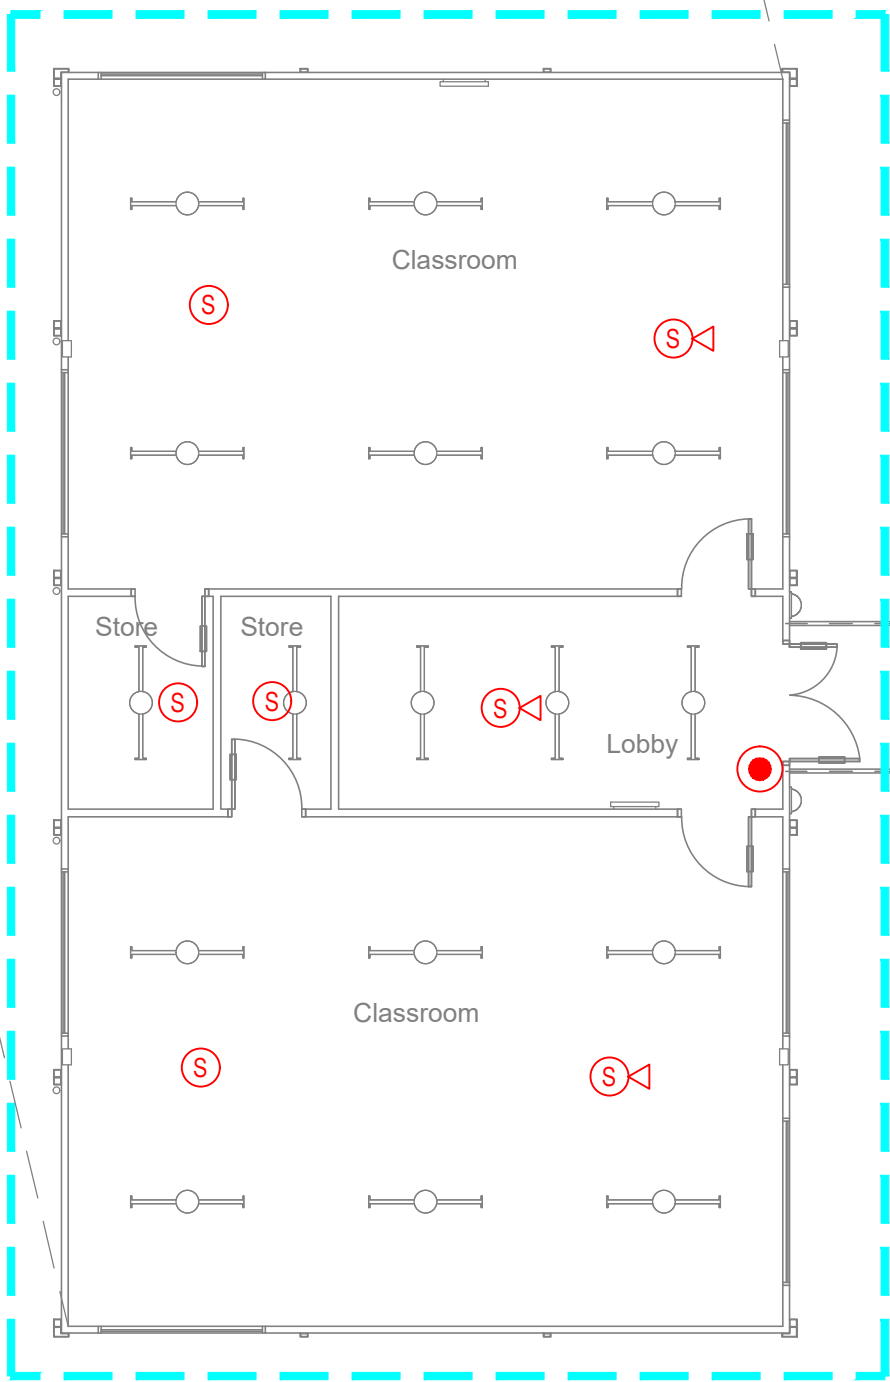

FIRST FLOOR

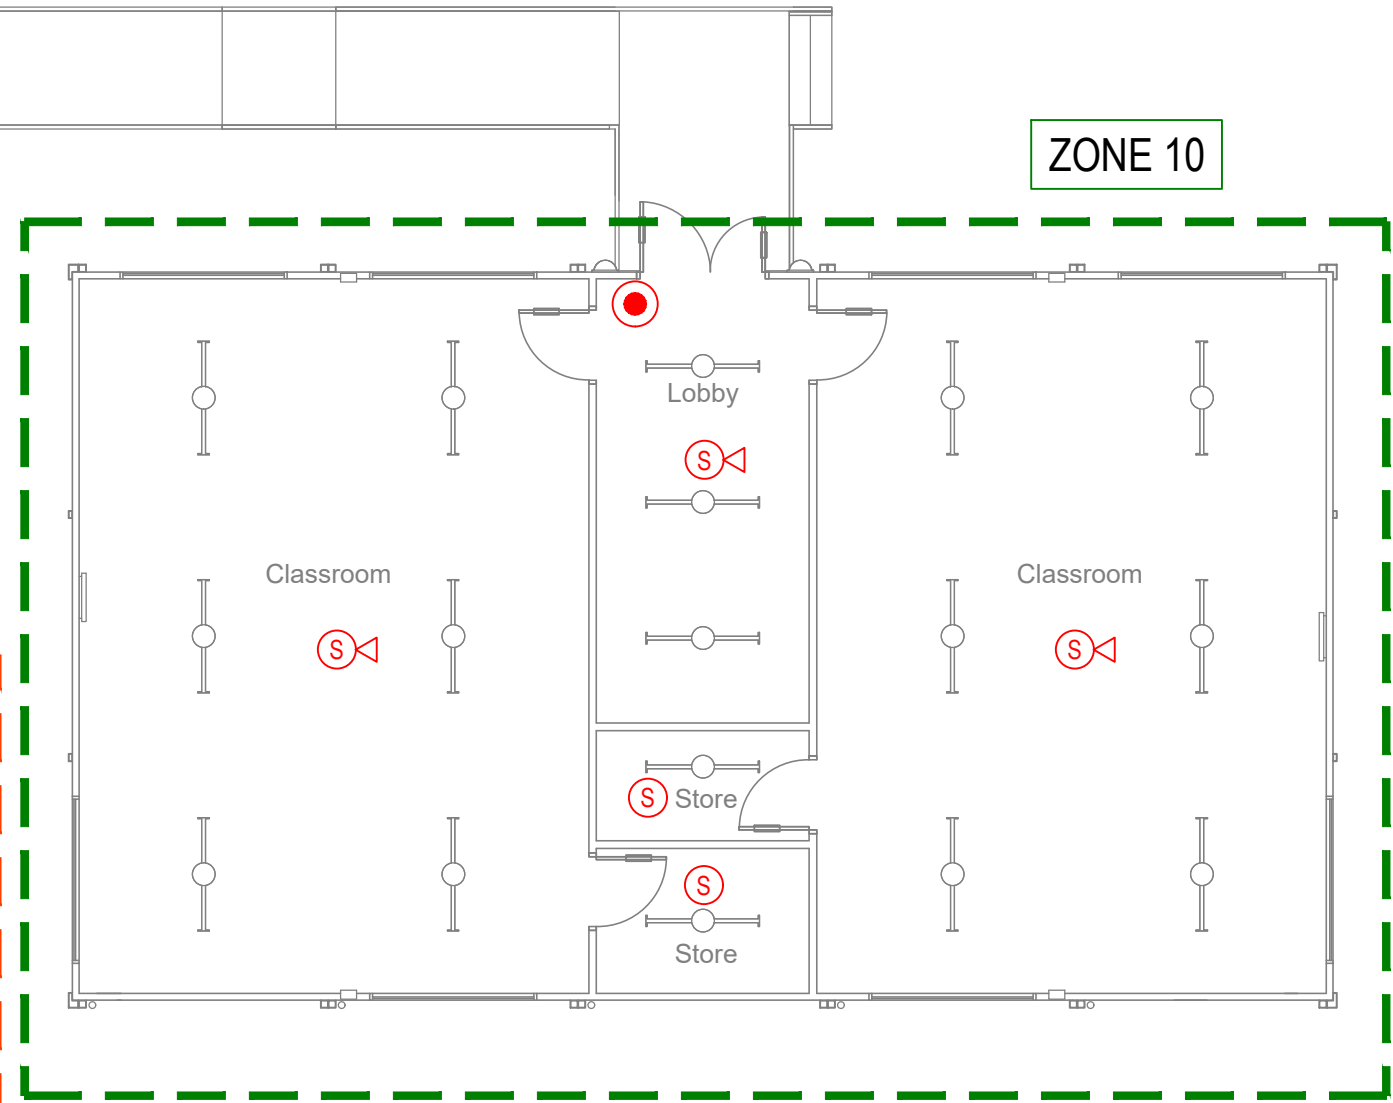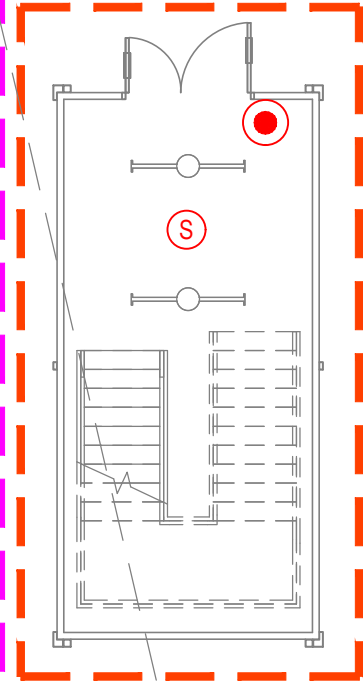

NEW DOUBLE CLASSROOM BLOCK

FIRE ALARM LAYOUT

B	20/05/2026	SL102 & Double classroom block added	JL
A	09/04/2025	First Floor units & Solus Unit added	JL
Rev	Date	Changes	Chd
Portakabin			
Project: College of Richard Collyer			
Drawing Title: Portakabin Blocks Ground Floor Fire Alarm Layout			
Scale: 1:100		Plot size: A1	
Date: 25/04/2024		Drn: IRC	Chd: JL
Job No: PK-CoRC01	Drawing No: PK-CoRC01-FA01		Rev: B