


Attenuation tanks to be installed with Aquacell Plus-R along the base layer for inspection access and Aquacell Core-R to be used for the remaining crates. Minimum depth to top of crates to be 1.1m to allow for Fire Tender Loading.

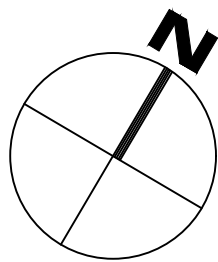

General Notes

LEGEND

Site Boundary

Existing Drainage

Existing Chamber to be retained

Private Drainage

Constructed Manhole

Pump Chamber with Pumped Main Outlet

Polypropylene Inspection Chamber (PPIC/DNIC)

Dry Detention Basin

PCC Ring Chamber with Catchpit 1200Ø

PCC Ring Flow Control Chamber 1200Ø

Attenuation Tank (min 95% Void Ratio)

Headwall

Yard Gully

Road Gully

Rodding Eye

RWP Downpipe

Bypass Separator

Channel Drain

Surface

Surface

Foul

Foul


Foul

Foul

Foul

Foul

Foul

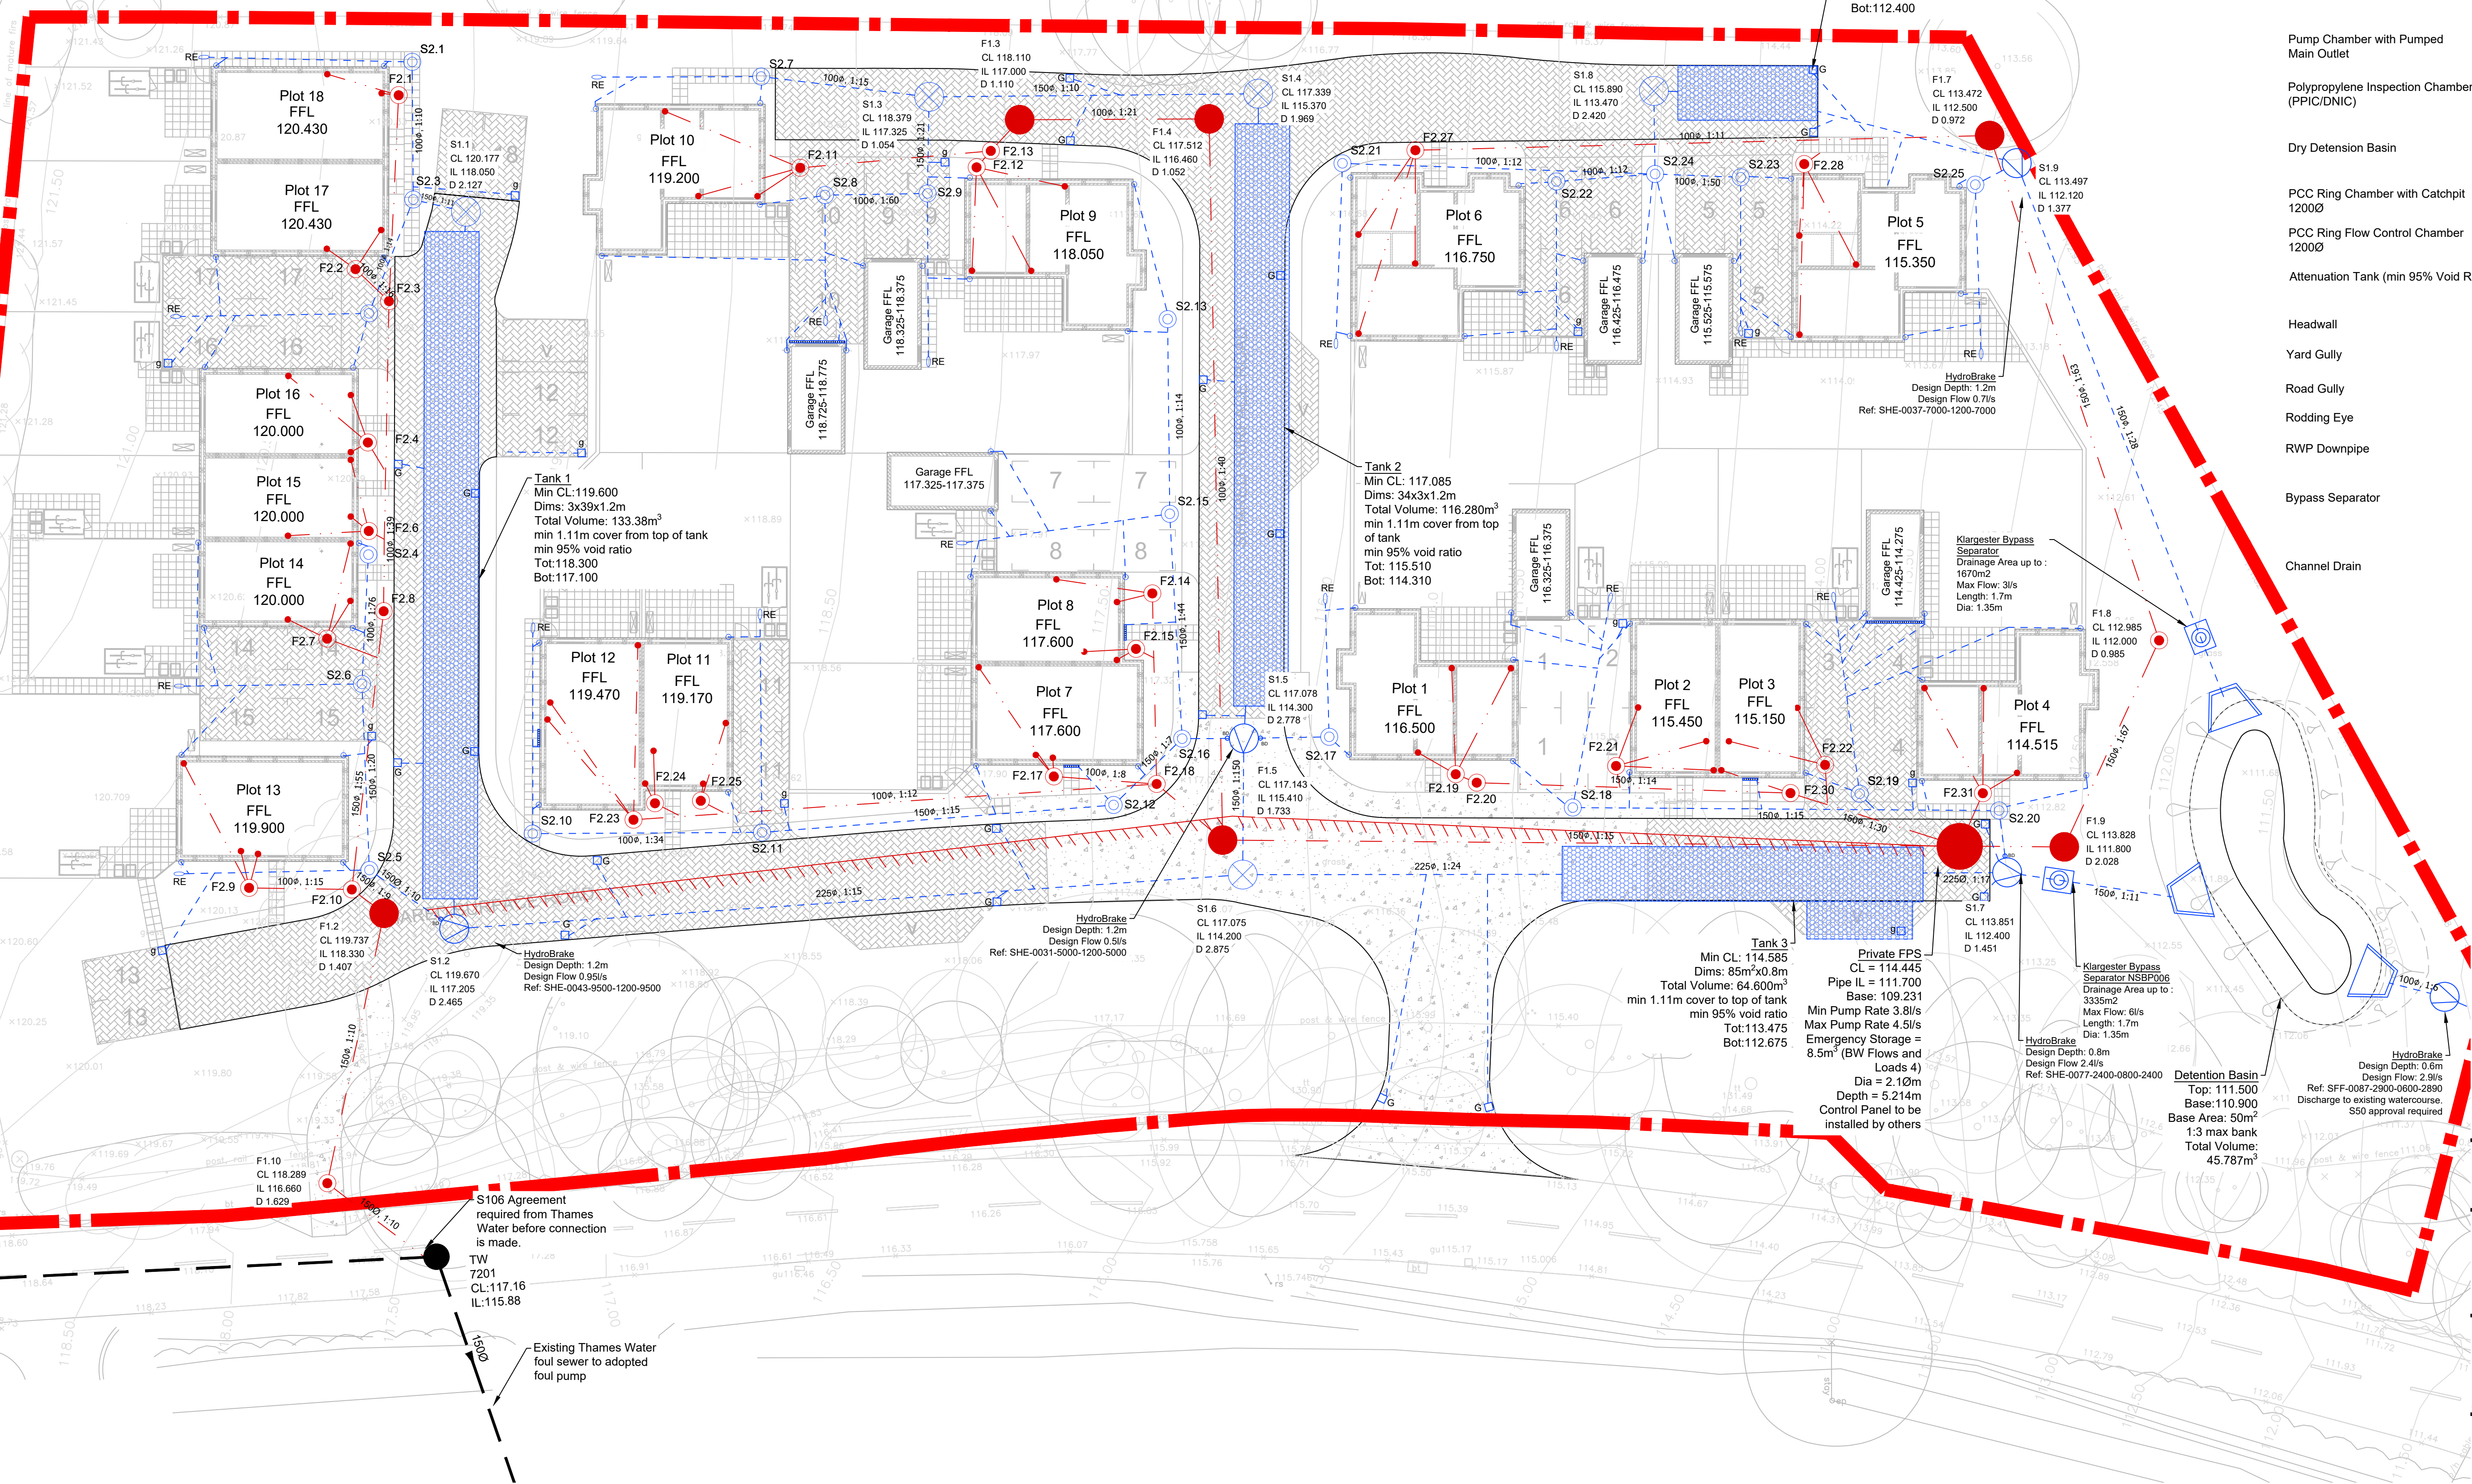

Rev	Date	Description	NC	AJP
P02	17/02/26	Permeable paving removed, channel drains added to garages, location of foul pump updated and bypass separators added.	NC	AJP
P01	05/02/26	Preliminary Issue	NC	AJP
By				
Ckd				
PRELIMINARY				S3

DEVINE HOMES PLC
builders of fine homes

Tullys

www.tullys.uk info@tullys.uk 01342 828000

East Street
Rusper

DRAWING TITLE
Proposed Drainage Layout

Originator No.	Scale	Revision
15546	1:200 @ A1	P02
PROJECT - ORIGINATOR - VOLUME - LEVEL - TYPE - ROLE - NUMBER		
15546-TUL-XX-XX-DR-C-51001		