

LOUVER SCHEDULE			
REFERENCE	SIZE	MAKE AND MODEL	ACCESSORIES
(L1D)	400x300	GILBERTS	BIRD GUARD, INSECT MESH AND PLENUM BOX
(L1D)	700x300	GILBERTS	BIRD GUARD, INSECT MESH AND PLENUM BOX


GRILLE SCHEDULE			
REFERENCE	SIZE	MAKE AND MODEL	ACCESSORIES
(G1D)	500x200	GILBERTS SERIES 1	PLENUM BOX
(G1D)	600x600	GILBERTS SERIES GC	PLENUM BOX
(G1D)	600x600	GILBERTS SERIES GECA	PLENUM BOX
(G1D)	Ø125	GILBERTS SERIES GX EXTRACT VALVE	N/A

Legend:

-  MVHR
-  SUPPLY DUCT
-  EXTRACT DUCT
-  FRESH AIR DUCT
-  EXHAUST AIR DUCT
-  SQUARE EXTRACT GRILLE
-  CIRCULAR EXTRACT GRILLE
-  SQUARE SUPPLY GRILLE
-  ATTENUATOR
-  CROSS TALK ATTENUATOR
-  LOUVER
-  VOLUME CONTROL DAMPER

Notes:

- DO NOT SCALE THIS DRAWING. ALL DIMENSIONS IN MILLIMETRES UNLESS OTHERWISE STATED.
- THIS DRAWING IS TO BE READ IN CONJUNCTION WITH ALL RELEVANT ARCHITECT'S STRUCTURAL ENGINEERS AND MBE DRAWINGS AND THE MBE SPECIFICATION, SAMPLES SHEET AND ROOM DATA SHEETS.
- ALL ITEM OF EQUIPMENT SHALL BE INSTALLED AS TO THE MANUFACTURER'S RECOMMENDATIONS.
- ALL INFORMATION AND LAYOUTS DETAILED ON THIS DRAWING ARE SUBJECT TO SITE DIMENSION CHECKS.

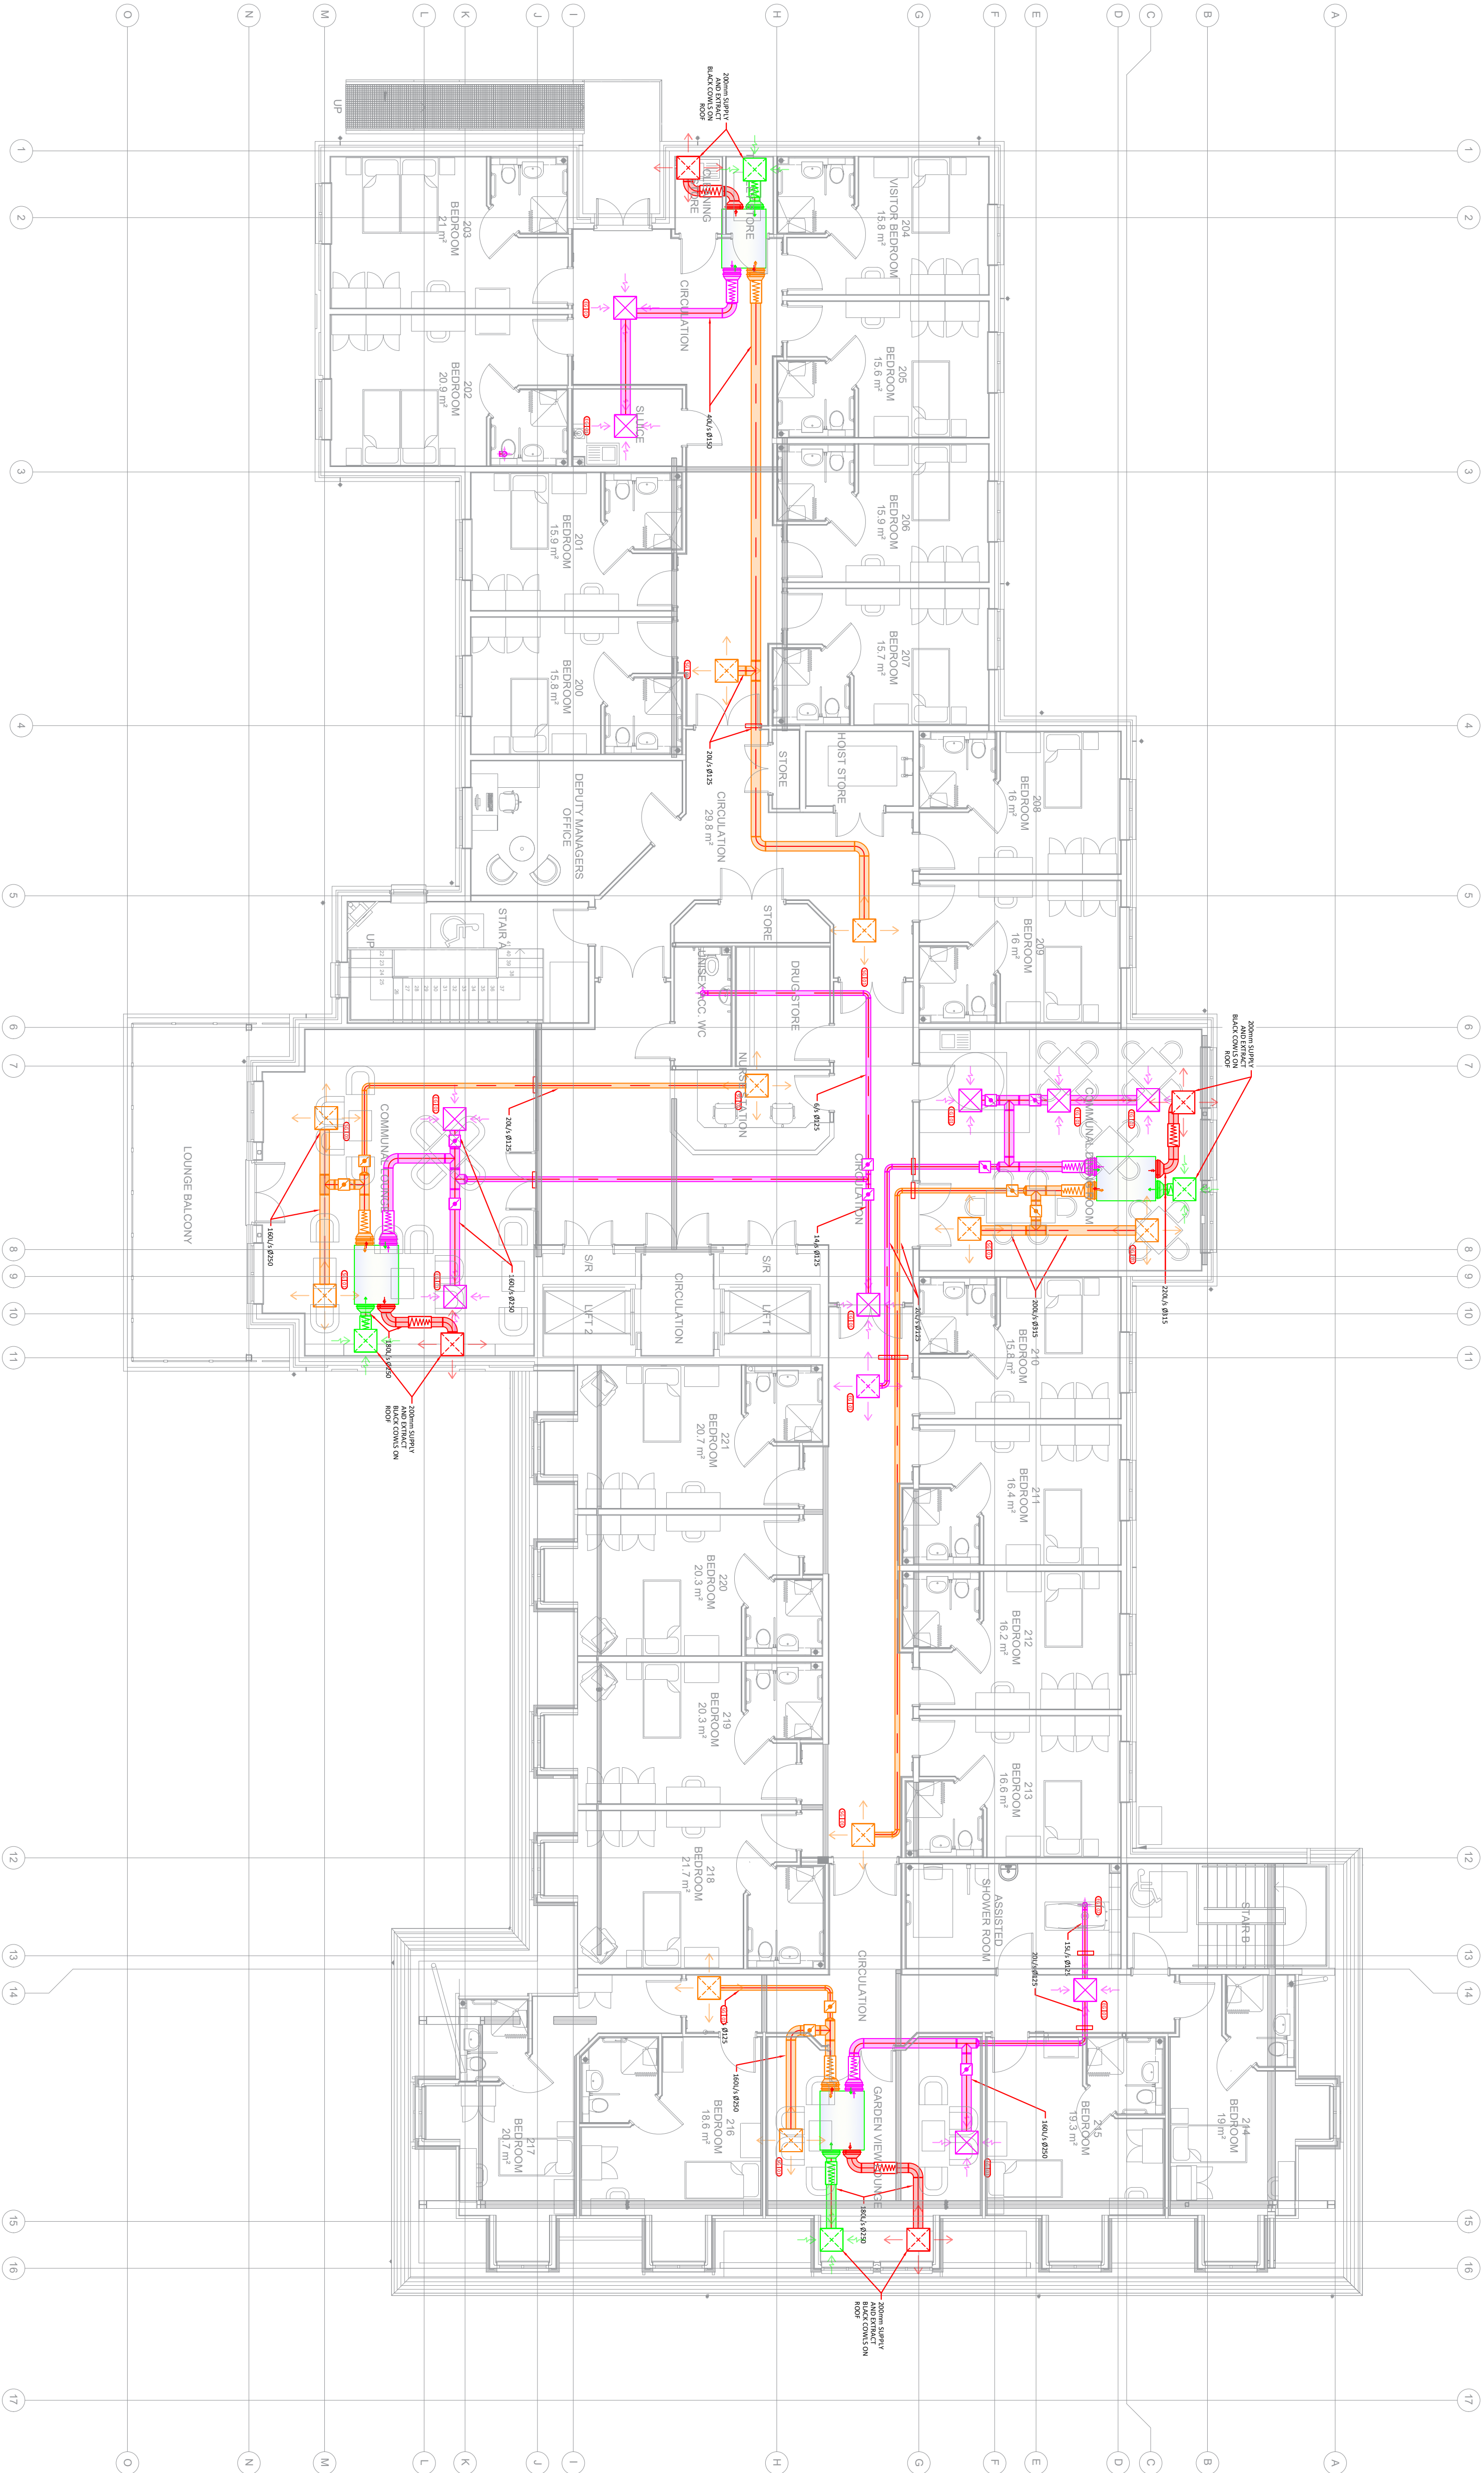

Please note: If scaling from pdf, measurements may be inaccurate due to pdf conversion from dwg.

REVISION	DATE	COMMENTS
P03	16.09.25	Revised layout
PROJECT		
Sussex Down Care home		
CLIENT		
		
 SUSTAINABLE ENGINEERING		
DRAWING TITLE		
Ventilation Layout Second Floor		
DRAWN BY:	APPROVED BY:	DATE
CRA	SPT	04.05.24
DRAWING NUMBER		SCALE - A1
043RSD U30 021		1:50
		REVISION
		P03