


This drawing shall not be
scanned.
Work from the dimensions shown
in the drawing or given in
the schedule.
This drawing is to be used as a
guide only, please refer to scope
of works for specific quantities
and details

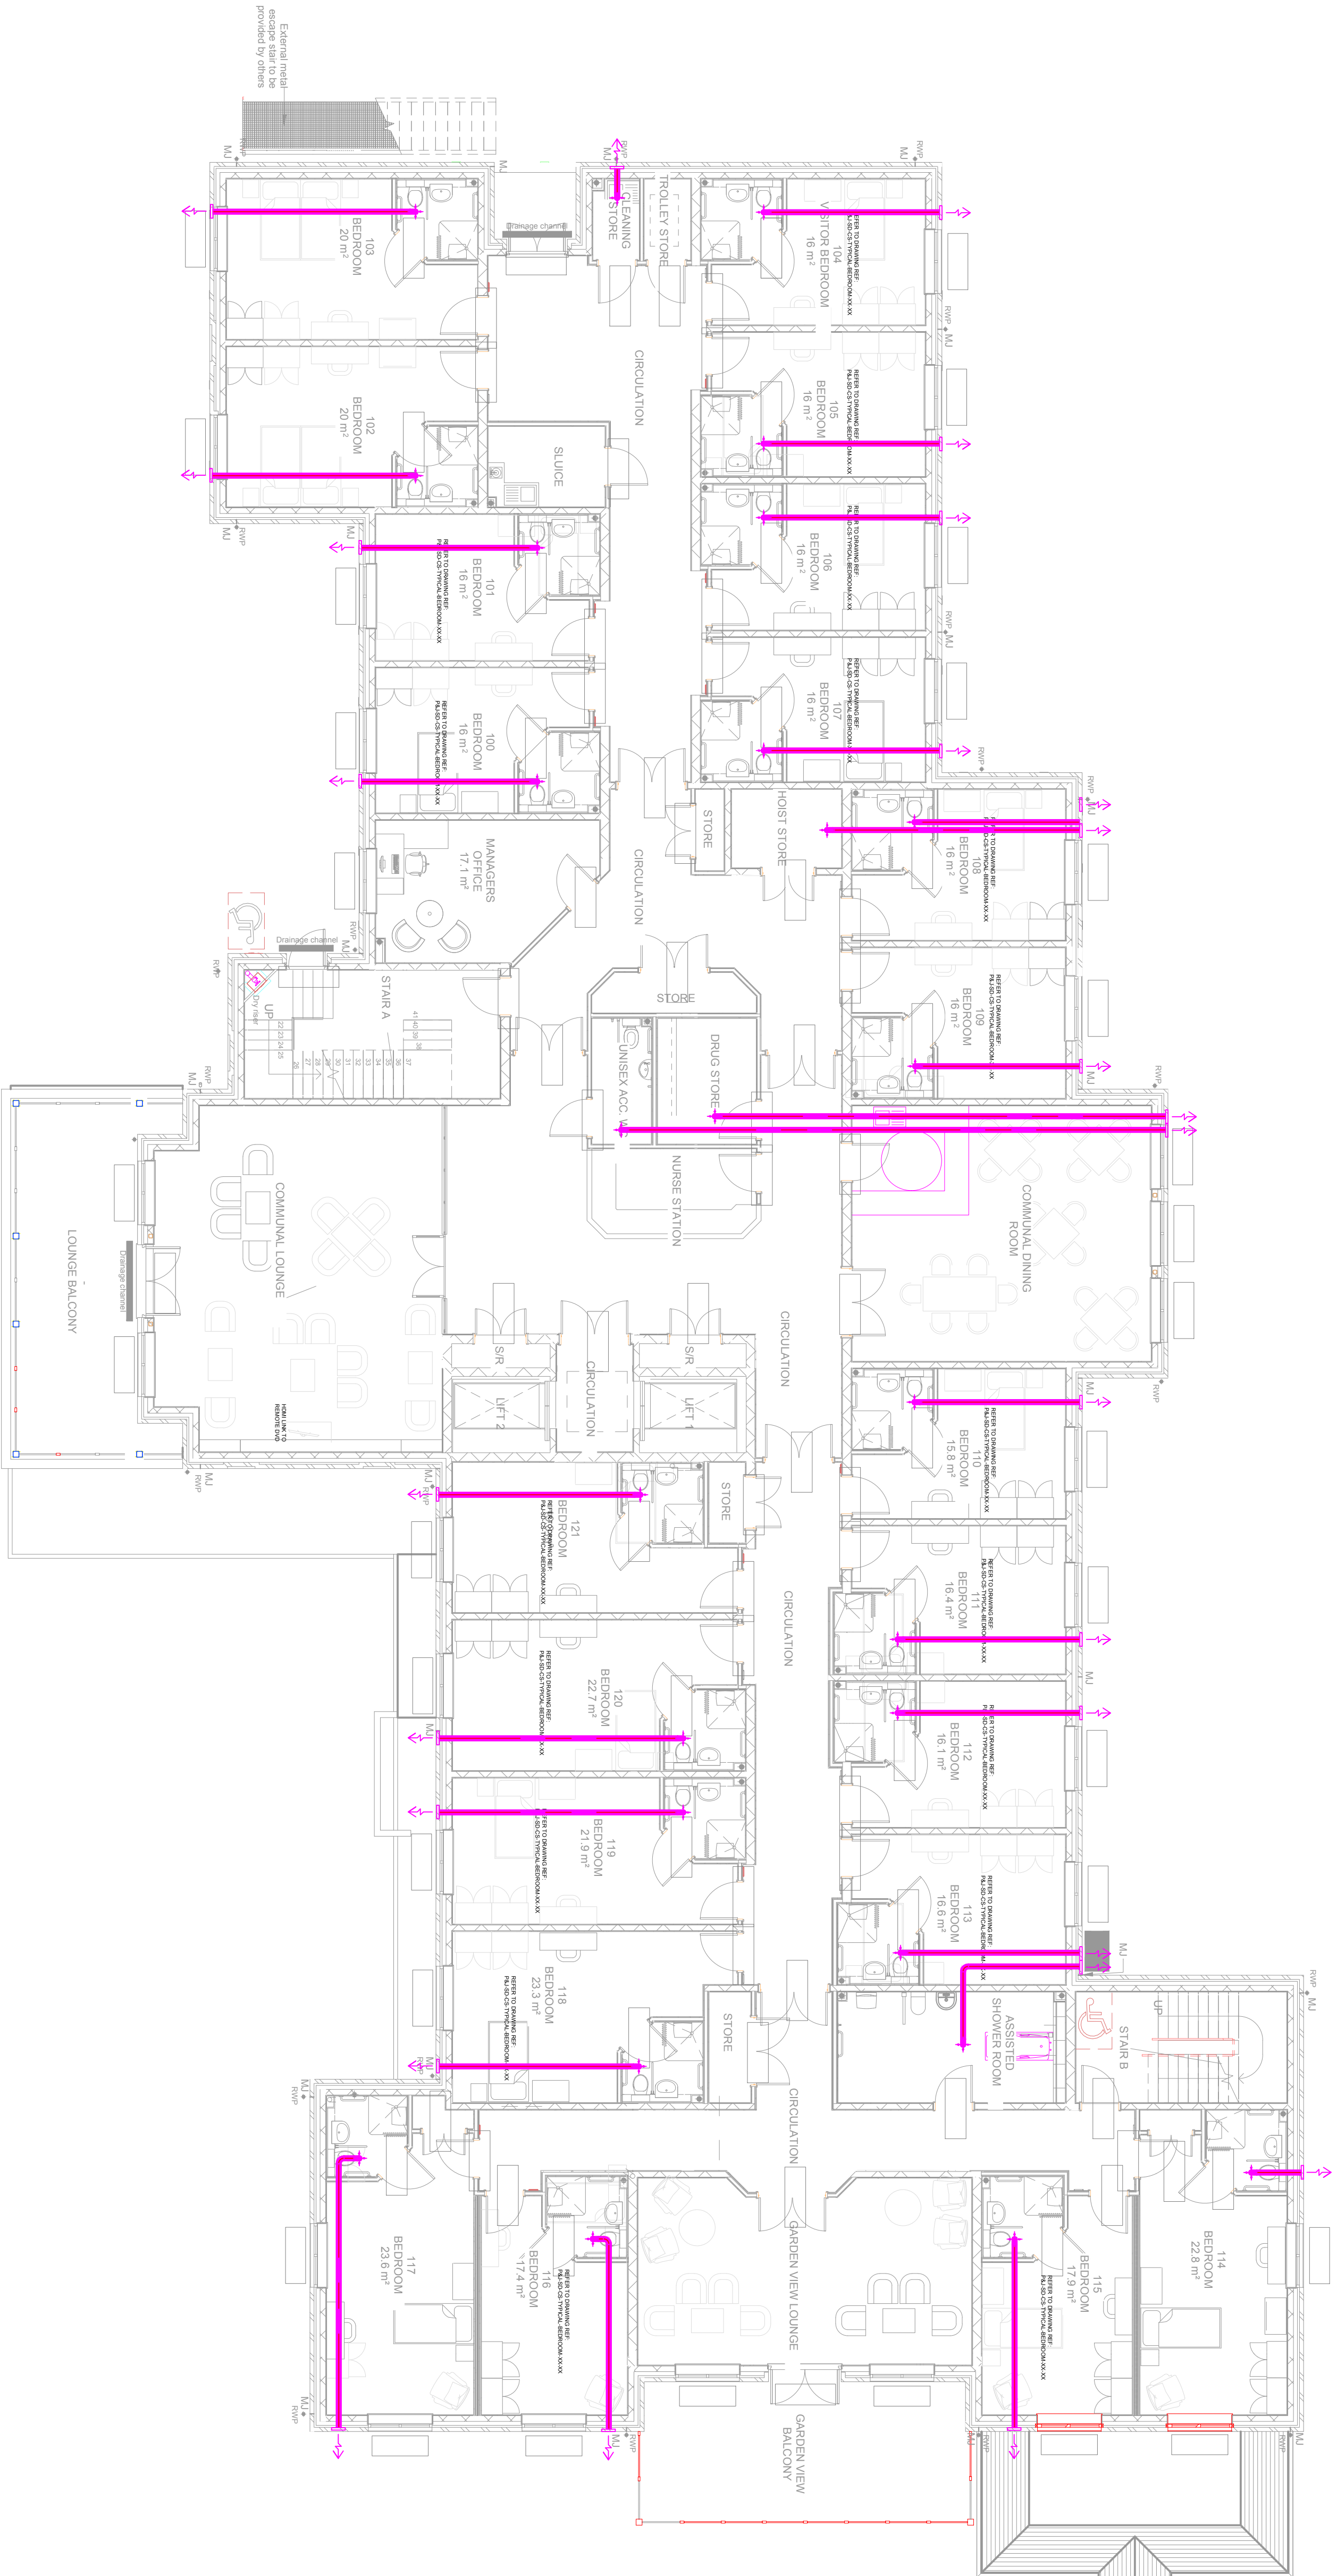

LEVEL 1

FIRST FLOOR

CDM Regulations:

In addition to any information included in this drawing or the model from which it is derived, refer also to the project CDM Risk Register for information on residual risks.

General Notes:

- The drawing does not necessarily show all the information needed to interpret the design intent or the construction details.
- The drawing contains information from more than one source and must be read in conjunction with all other drawings and specifications.
- Any apparent drafting errors and differences between other drawings and specifications shall be brought to our attention.

Project Notes:

- All terminations through external walls to be presented to air bricks; ducting must be installed with fire rated sleeve through external walls with fire wraps at either end of the opening.
- External intakes shall be installed in all fire walls must be fitted with fire wraps / collars.

NO	FOR SUBMITTAL	TA	RM	RM	NOV23
Index	Description	Designed	Reviewed	Issued	Date
REVISIONS:					

morelec (UK) Ltd
UNIT 4 BOURNEMOUTH BUSINESS PARK
BOURNEMOUTH
T. 01202 700000
WWW.MORELEC.NET

ARCHITECT:
CORSTORPHINE & WRIGHT

CLIENT:
PARSONS AND JOYCE

PROJECT TITLE:
SUSSEXDOWN CAREHOME

DRAWING TITLE:
FIRST FLOOR BATHROOM VENTILATION LAYOUT

FOR SUBMITTAL

PERSON RESPONSIBLE FOR:			
Design:	TA	Review:	RM
Authoring:	RM	Issued:	RM
Project No:	P&J-SD-24-11	Date:	24 NOV 2025
Scale:	Scale @ A1:	Scale:	1:100
Drawing Number:	P&J-SD-24-11-10-1ST-VENT-	Revision:	04