


Legend:

- DRAINAGE PIPEWORK
- HIGH LEVEL DRAINAGE
- ⊕ SVP DRAINAGE
- ⊕ S/S STUB STACK
- ⊕ DC DIRECT CONNECTION
- F/B FROM BELOW
- T/A TO ABOVE
- ⊕ SG SHOWER GULLEY
- ⊕ RODDING EYE DRAINAGE CONNECTION FOR:
 - DW - DISH WASHER
 - EW - ELECTRIC WATER HEATER
 - ZIP - ZIP HYDROBOL

Notes:

- DO NOT SCALE THIS DRAWING. ALL DIMENSIONS IN MILLIMETRES UNLESS OTHERWISE STATED.
- THIS DRAWING IS TO BE READ IN CONJUNCTION WITH ALL RELEVANT ARCHITECT'S STRUCTURAL ENGINEERS AND M&E DRAWINGS AND THE M&E SPECIFICATION, SAMPLES SHEET AND ROOM DATA SHEETS.
- ALL ITEM OF EQUIPMENT SHALL BE INSTALLED AS TO THE MANUFACTURER'S RECOMMENDATIONS.
- ALL INFORMATION AND LAYOUTS DETAILED ON THIS DRAWING ARE SUBJECT TO SITE DIMENSION CHECKS.

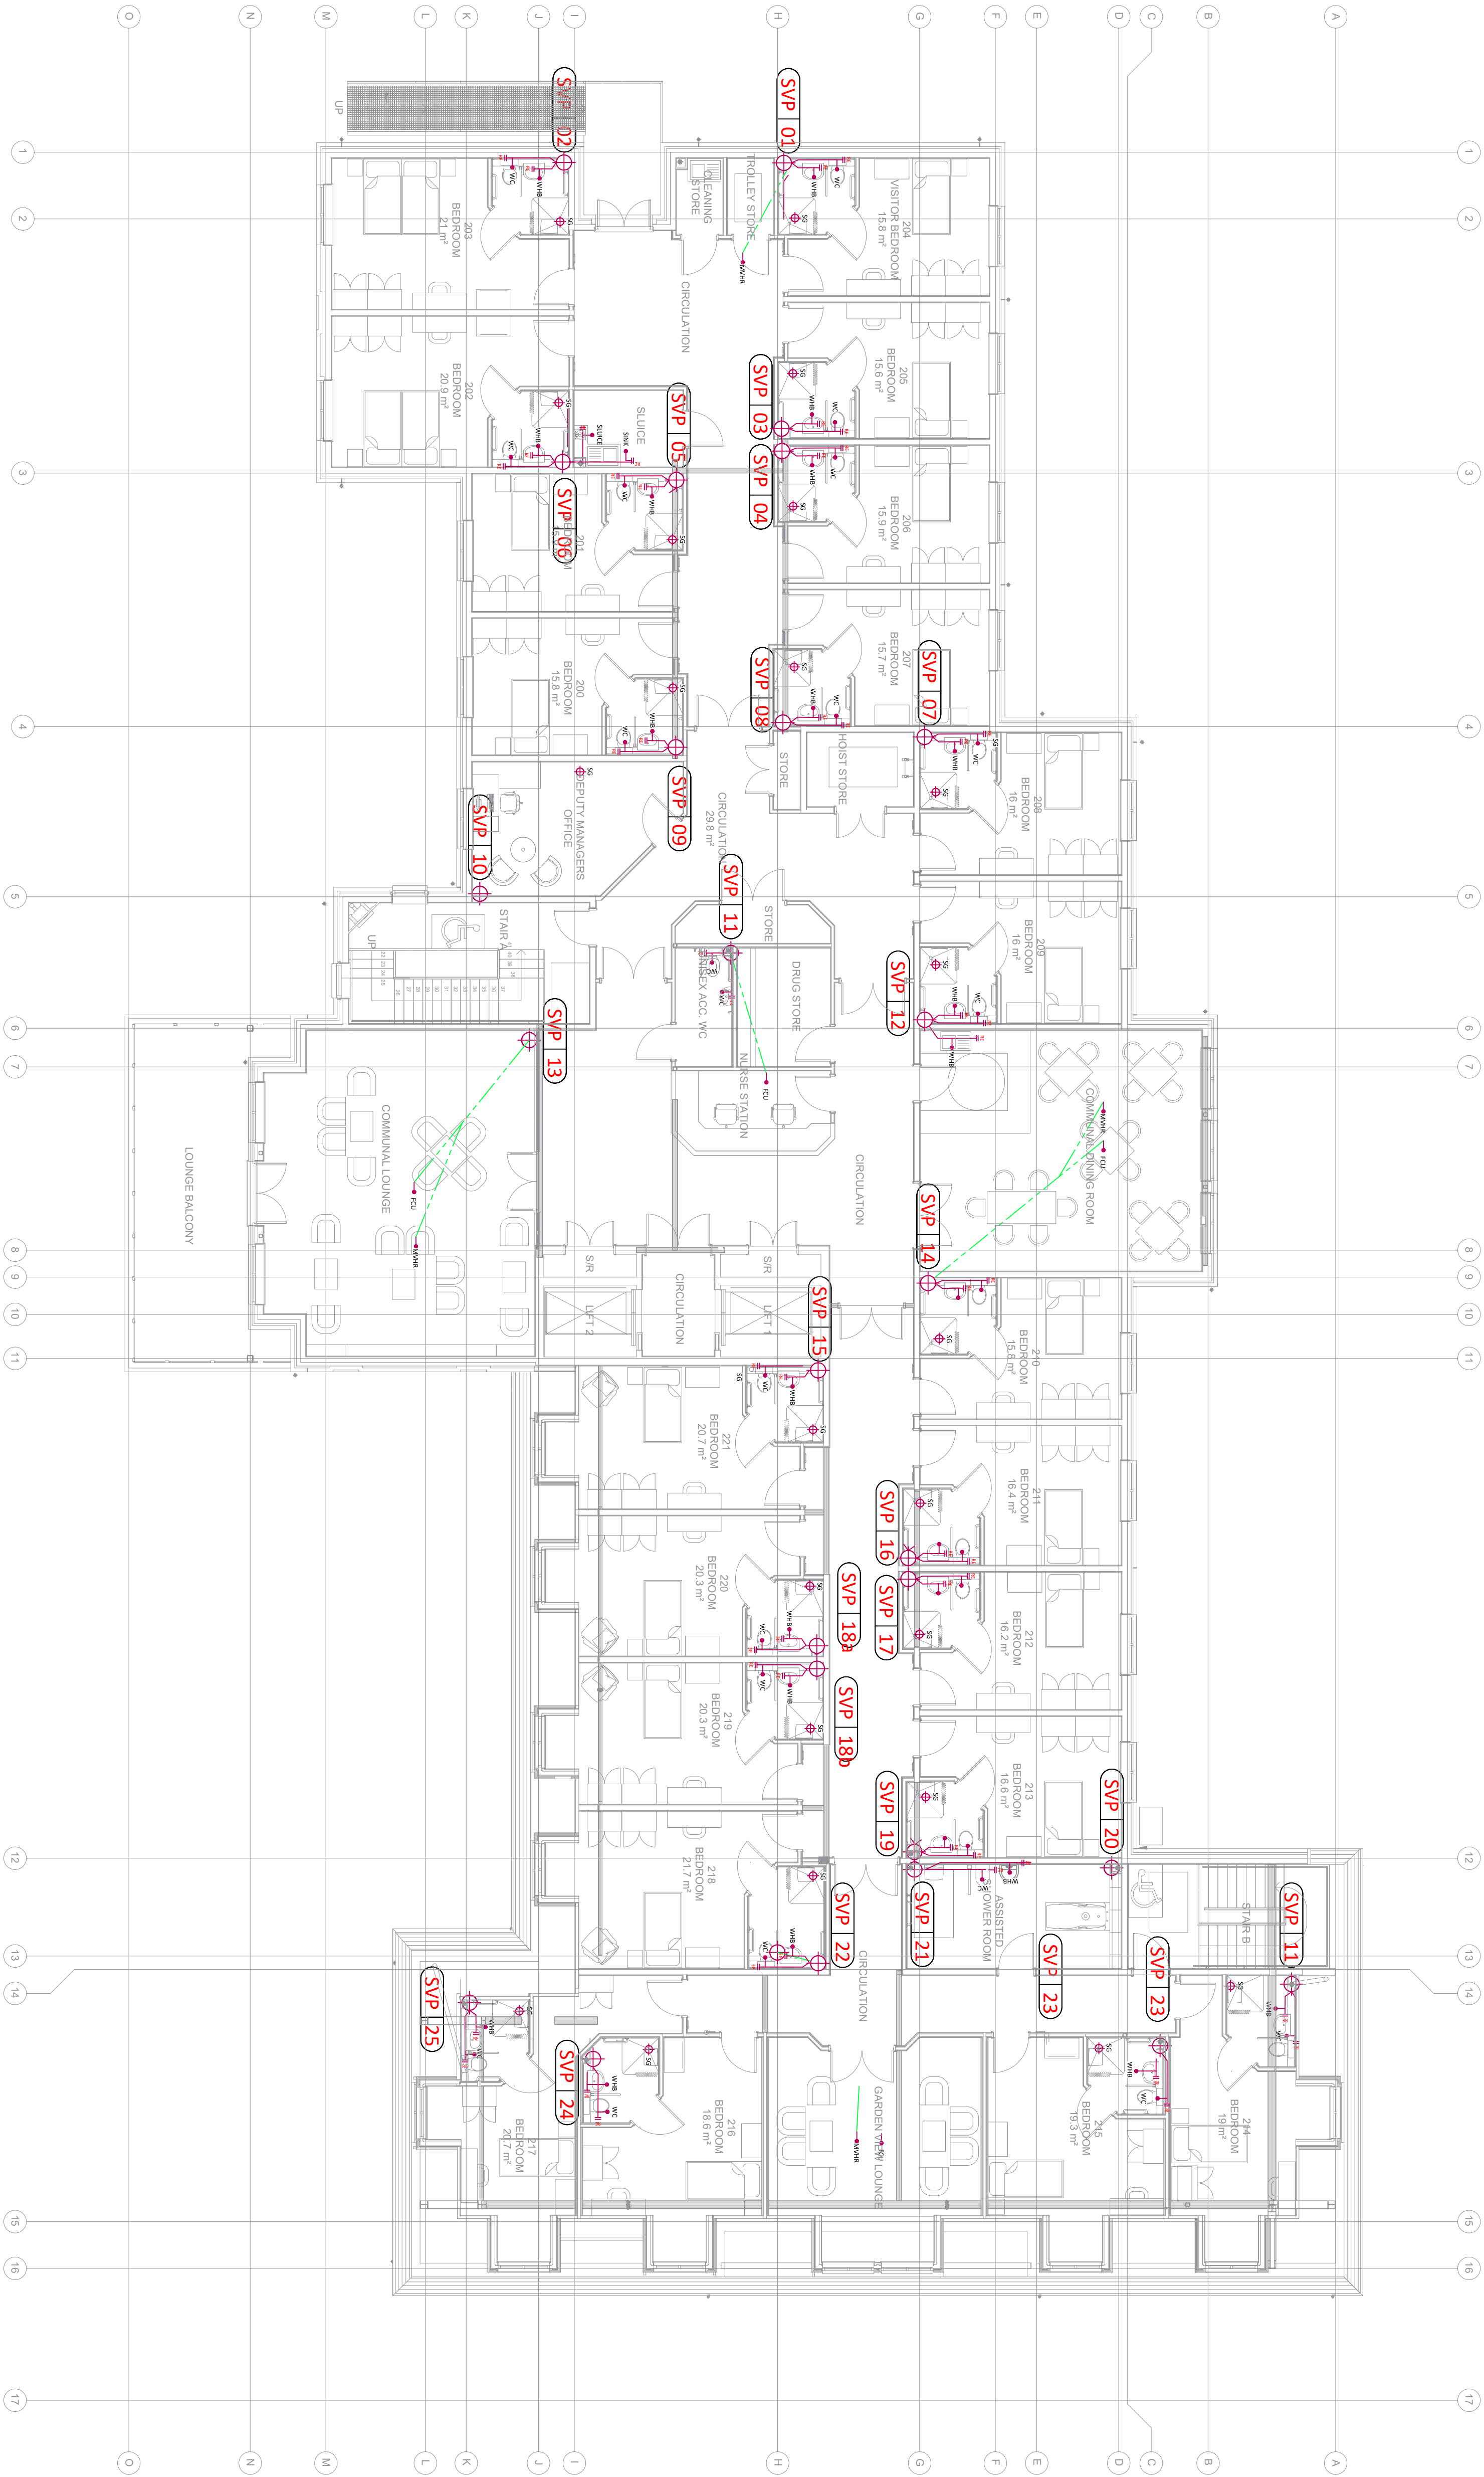

Please note: If scaling from pdf, measurements may be inaccurate due to pdf conversion from dwg.

REVISION	DATE	COMMENTS
P03	16.09.25	Revised layout
PROJECT		
Sussex Down Care home		
CLIENT		
		
		
DRAWING TITLE		
Drainage Layout Second Floor		
DRAWN BY:	APPROVED BY:	DATE
CRA	SPT	04.05.24
DRAWING NUMBER		REVISION
043RSD R10 021		P03