
 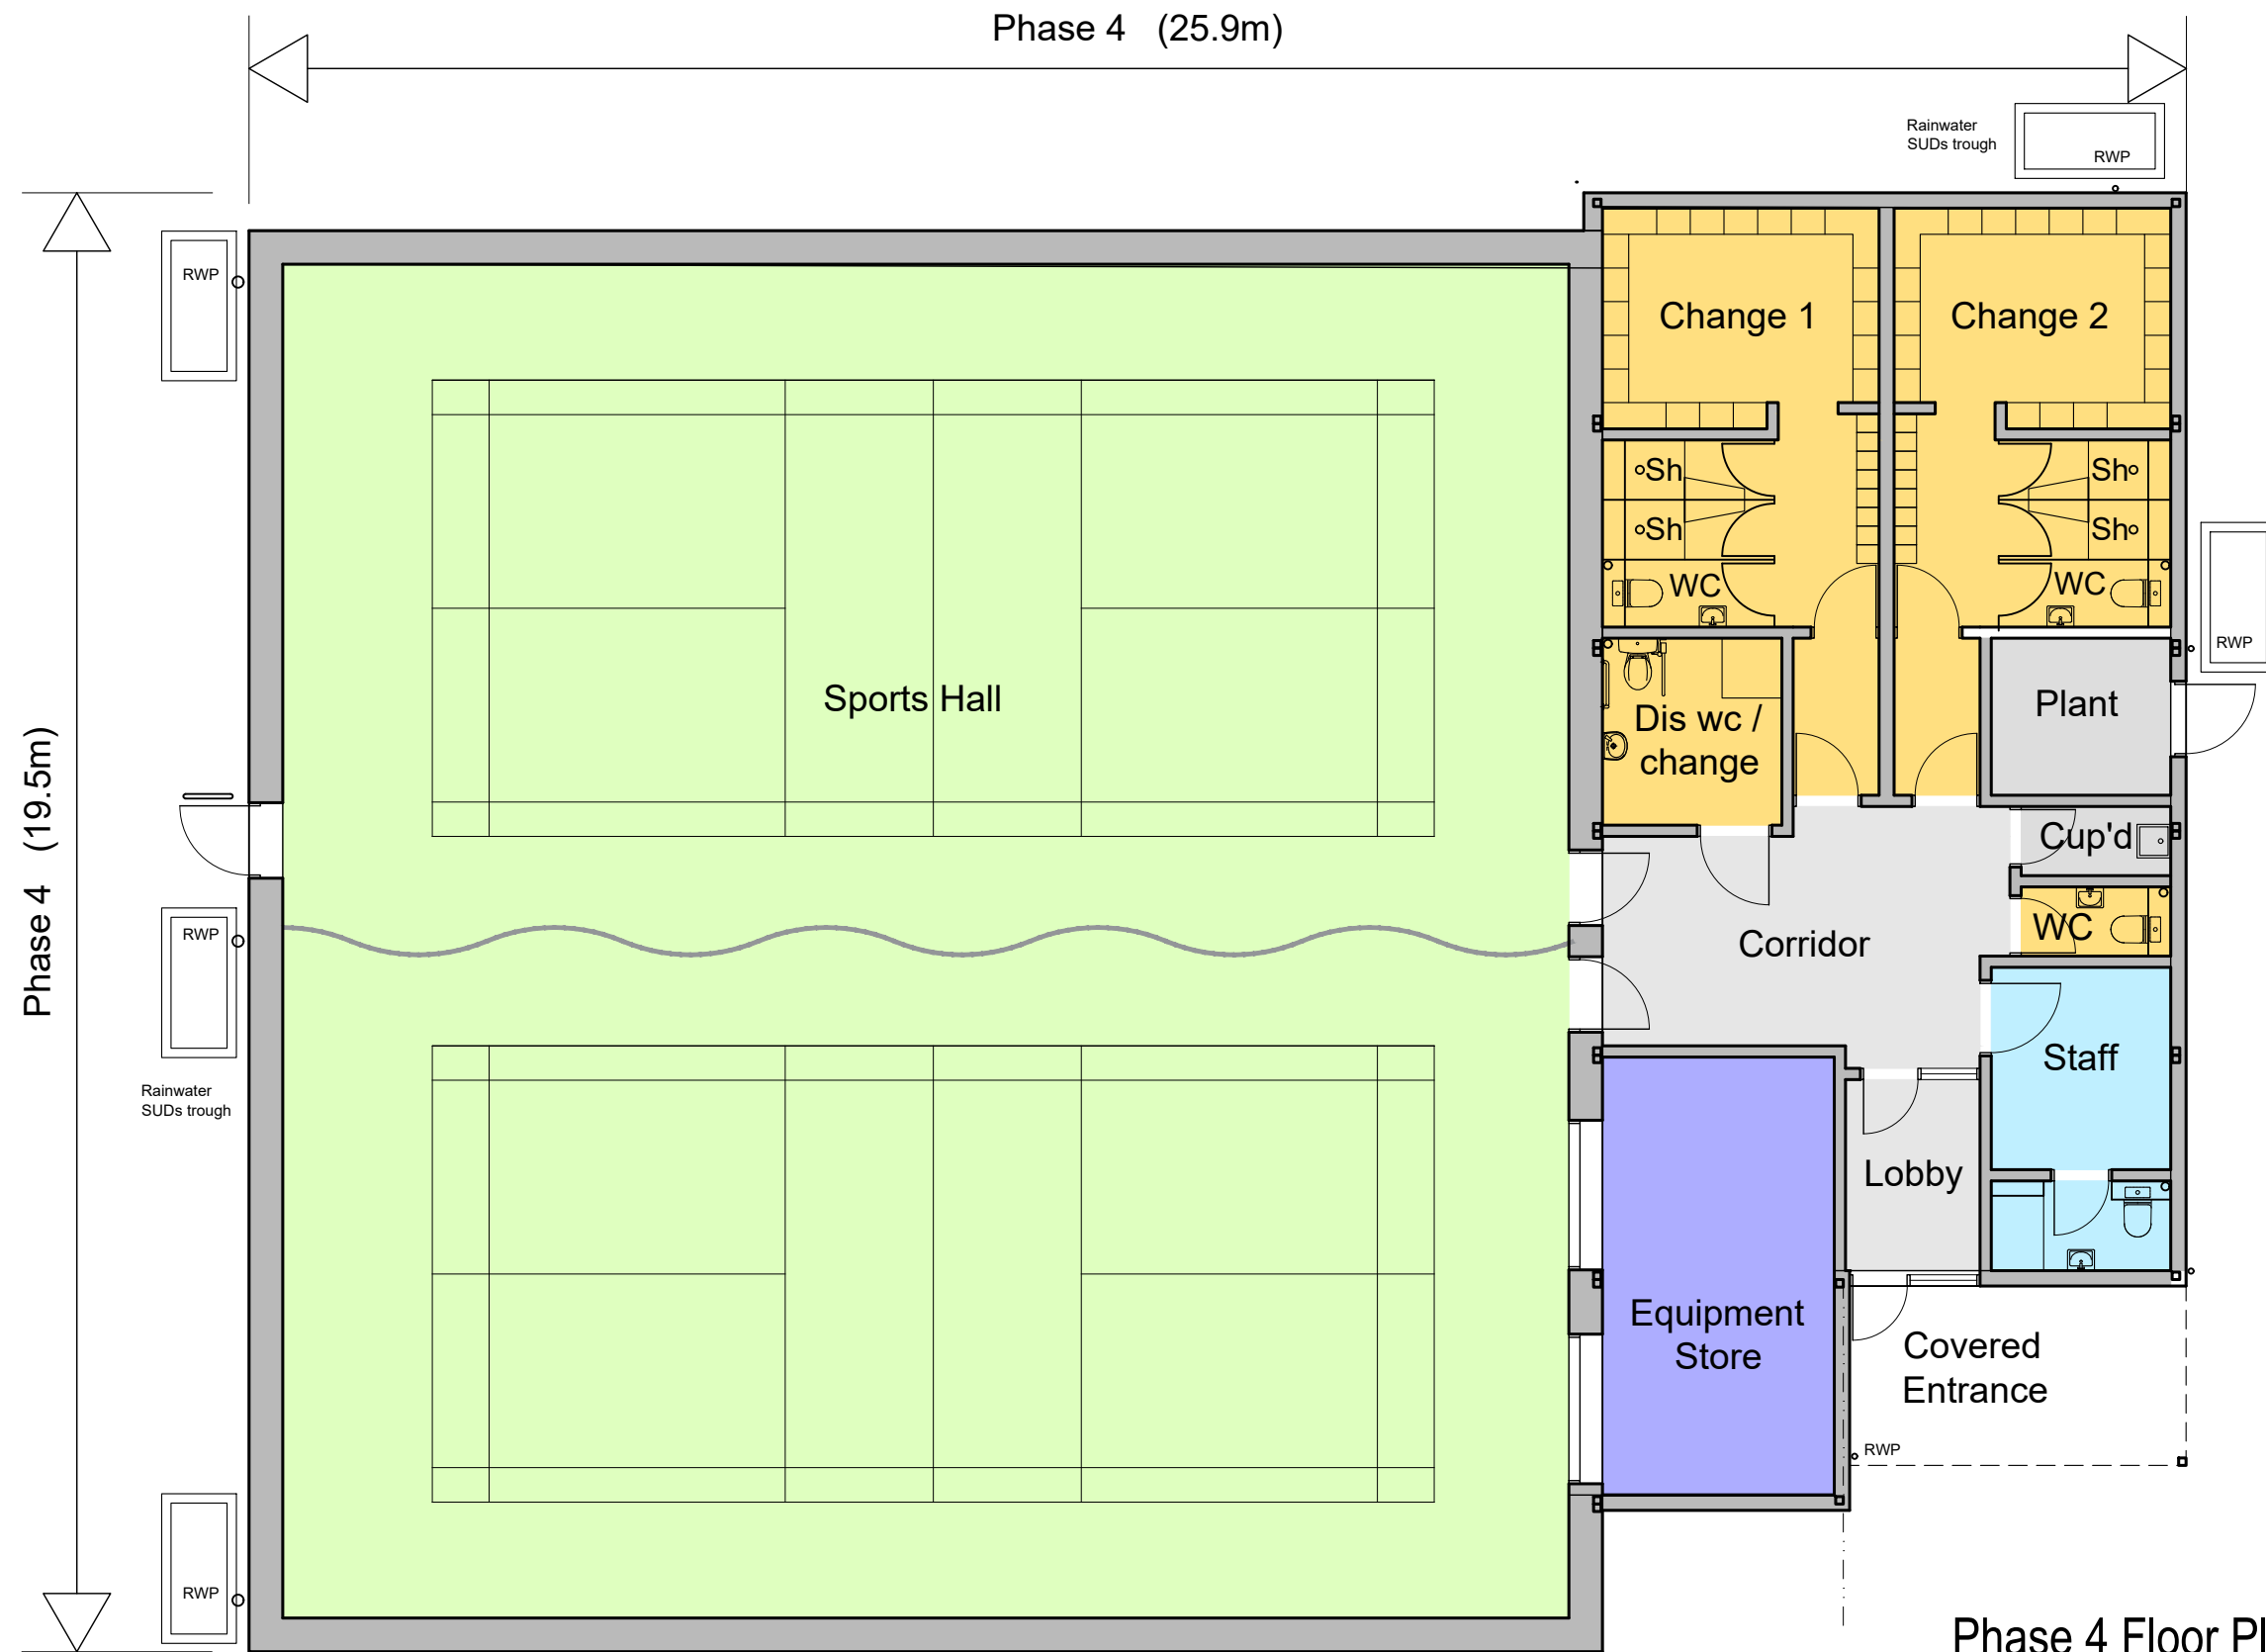


Phase 4 Floor Plan

Electrical Engineers, Fire and Acoustic eng and Structural and Civil engineers). These are to be developed during the detailed de stage to ensure full compliance.



Note: All levels and dimensions are to be checked on site. This drawing is to be read in conjunction with all relevant consultants' requirements, drawings and specifications. Any discrepancies between consultants' drawings to be reported to the Contract Administrator before any relevant work commences.

Copyright: 2023 Miller Bourne ©

Notes

- General Teaching
- Specialist Teaching
- Learning Resources / Therapy / Breakout
- Staff / Admin
- Sanitary / Changing Accommodation
- Storage
- Dining / Performance / Assembly / Sports
- Services / Plant / Kitchen
- Circulation

Rev	Date	Description	Drawn	Checked	Status
P02	09.25	First Issue	RM	RM	PLANNING APP
P02	2.10.25	Additional Detail Added and Minor Alterations	RM	RM	
P03	9.10.25	Updated with additional detail added.	RM	RM	
P04	4.11.25	Indicative furniture and fittings added. Indicative drainage points and rwps added.	JC	RM	
P05	11.03.26	Rain water troughs and dims added. Do not scale note omitted.	JC	RM	

Ingfield Woodview School

Proposed Floor Plan - Phase 4 Sports Hall

Scale: 1:100 @ A3

Drawing Reference: 4908-MBA-01-GF-D-A-1013

Rev: P05

MILLER BOURNE ARCHITECTS

332 Kingsway
Hove
East Sussex
BN3 4QW
T: 01273 411399
design@miller-bourne.co.uk
www.miller-bourne.co.uk