


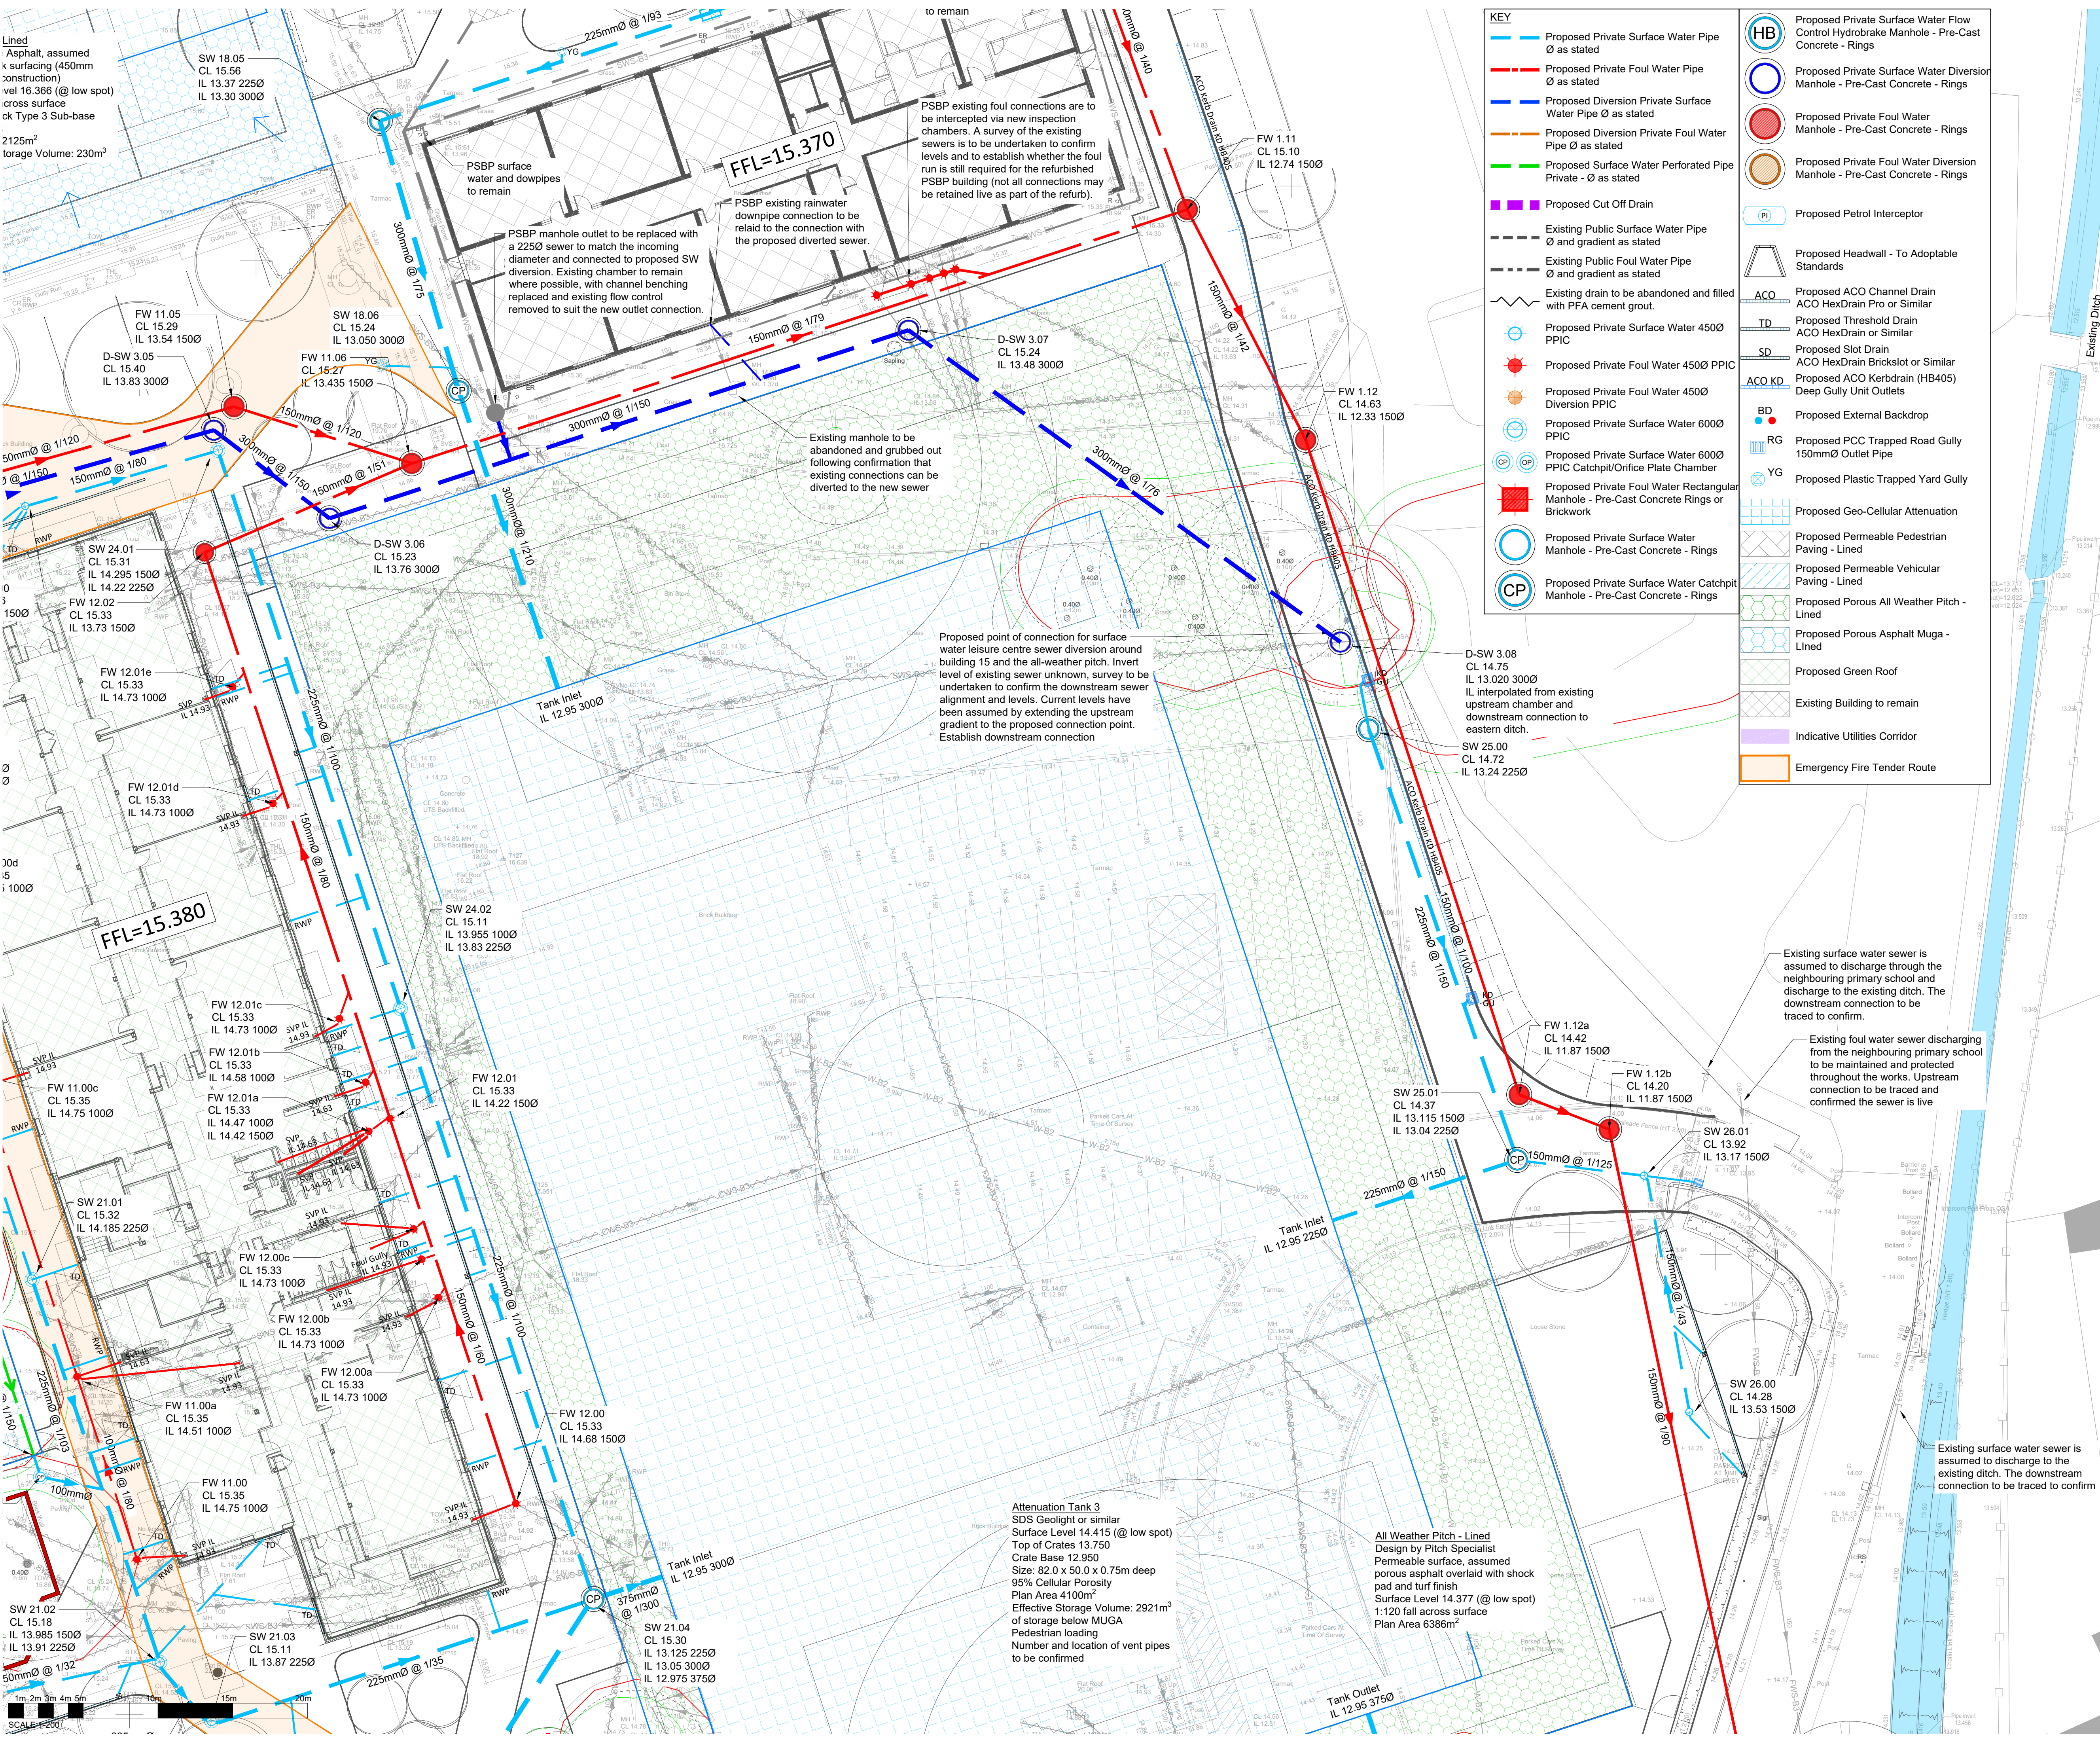

Notes:

- DO NOT SCALE THIS DRAWING. WORK TO FIGURED DIMENSIONS ONLY. ALL DIMENSIONS ARE IN MILLIMETRES (mm) UNLESS NOTED OTHERWISE.
- This drawing is to be read in conjunction with all relevant Architects, Engineer's and Specialist's drawings and their respective Specifications.
- All work to comply with the relevant British Standards, Codes of Practice and the Building Regulations.
- Any discrepancies between all working drawings, specifications and schedules of all disciplines to be immediately notified to CTP for clarification/correction prior to construction of relevant structure.
- For CDM residual risks and identified health and safety hazards, refer to Hazard Identification Drawing SRP1121-CTP-ZZ-00-D-C-1700.
- For additional notes refer to Site Wide Drainage Layout SRP1121-CTP-ZZ-00-D-C-1500

KEY PLAN

STAGE 4 ISSUE

C03 10.09.2026	SITE WIDE LANDSCAPING AND EXTERNAL SERVICES COORDINATION, FIREFIGHTING TANK AND BOREHOLE MANIFOLD LOCATIONS UPDATED	SP	NT
C02 21.08.2026	GENERAL LAYOUT UPDATES FOR EXTERNAL SERVICES COORDINATION	SP	LB
C01 07.05.2026	STAGE 4 ISSUE	AM	SP
P02 17.02.2026	UPDATED TO SUIT SITE LAYOUT CHANGES	SV	SP
P01 19.12.2025	STAGE 3 ISSUE	SV	SP
Rev	Date	Amendment	Dm Chk

Suffolk House 154 High Street
Sevenoaks, Kent TN13 1XE, UK
UK: +44 (0)1732 740195
www.ctp-llp.com

Project Title

STEYNING GRAMMAR SCHOOL

Drawing Title

DRAINAGE LAYOUT SHEET 3

CTP ref:	DEIR Ref:	Discipline:
B1641	165	CIVILS
drawn by:	date:	drawing scales:
SV	DEC-25	1:200 @A1 Unless Noted Otherwise
status:	status description:	
S5	Review & acceptance by the DfE	
revision status:		
CONTRACTORS PROPOSALS		
drawing reference:	project:	originator:
SRP1121-CTP-00-EX-D-C-1503-C03		