


PROPOSED

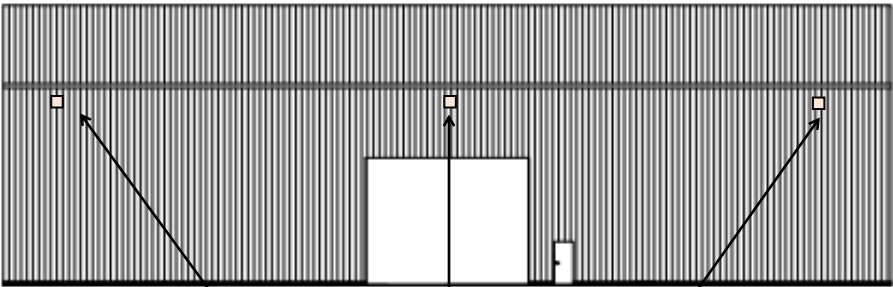

PROPOSED


Location of external
lighting

Vektor Wall Washer


Model#: UVK-30XXX Ratings: IP65 F CE IK08 ETL IDA

- The Vektor is a wedge-shaped, low-profile, wall-mounted luminaire designed specifically for downlight applications.
- Features high-powered LEDs and a selection of optics to meet a variety of lighting requirements.
- Available with Type II, III, IV, and V light distribution options, the Vektor enables wider fixture spacing and consistent illumination.
- With a Type II optic, spacings of up to 40 feet on center can be achieved while maintaining uniformity that complies with path of egress requirements—resulting in energy savings and reduced installation costs.
- The luminaire can also be configured with mixed beam optics, such as combining Type II and Type IV within the same fixture, to achieve custom light distribution.
- Integral electronic control gear is housed in a waterproof enclosure, and a mounting plate compatible with 3" and 4" octagonal junction boxes is included.

See supporting
specifications

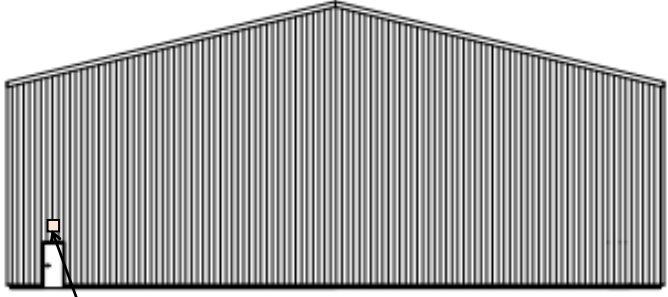

WEST ELEVATION

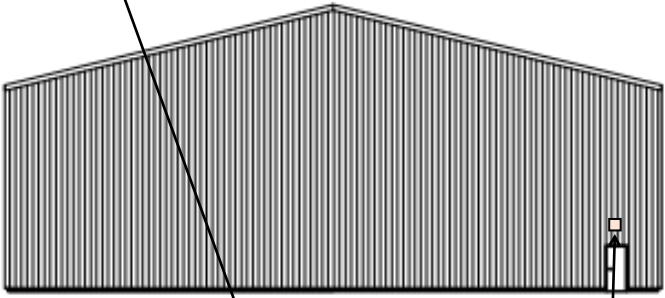

EAST ELEVATION

Opulence Small Wall Mount (OPS WM) Outdoor Wall Light



OVERVIEW	
Lumen Package (lm)	3,000 - 17,000
Wattage Range (W)	20 - 105
Efficacy Range (LPW)	134 - 177
Weight lbs (kg)	17 (7.7)
Control Options	IMSBT, ALBCS, 7-Pin



QUICK LINKS

- Ordering Guide
- Performance
- Photometrics
- Dimensions

See supporting
specifications

Disclaimer

This drawing is protected under the Copyright, Designs and Patents Act 1988. This drawing is protected by copyright.

Planning

This drawing is produced for PLANNING PURPOSES ONLY and is not to be used for construction.

This drawing illustrates a planning proposal only and as such subject to detailed site investigation, including ground conditions/contaminates and drainage design. The layout may be based upon an enlargement of an O.S. sheet or other small scale plans and its accuracy needs to be verified by survey. CDM Regulations remain the responsibility of the principal contractor.

Project: The Business Park
Maydwell Avenue
Sinfold
Horsham
RH13 0AS

Title: Lighting Plan

Status: Planning

Scale: NTS

Drawing no LP/01 Rev A

Date: 13/05/2026

File: C:\Clients\Richmond, Ben\Maydew Avenue\Drawing\Proposed Office EXAMING.dwg

