 
 


 
Legend:

MVAH

SUPPLY DUCT

EXTRACT DUCT

 
FRESH AIR DUCT

EXHAUST AIR DUCT

 
SQUARE EXTRACT GRILLE

CIRCULAR EXTRACT GRILLE

SQUARE SUPPLY GRILLE

ATTENUATOR

CROSS TALK ATTENUATOR

LOUVRE


MOTORISED VOLUME CONTROL DAMPER LINKED TO NIBE UNIT

- Notes:
1. DO NOT SCALE THIS DRAWING. ALL DIMENSIONS IN MILLIMETRES UNLESS OTHERWISE STATED.

2. THIS DRAWING IS TO BE READ IN CONJUNCTION WITH ALL RELEVANT ARCHITECT'S STRUCTURAL ENGINEERS AND MEP DRAWINGS AND THE MBE SPECIFICATION, SAMPLES SHEET AND ROOM DATA SHEETS.

3. ALL ITEM OF EQUIPMENT SHALL BE INSTALLED AS TO THE MANUFACTURER'S RECOMMENDATIONS.

4. ALL INFORMATION AND LAYOUTS DETAILED ON THIS DRAWING ARE SUBJECT TO SITE DIMENSION CHECKS.

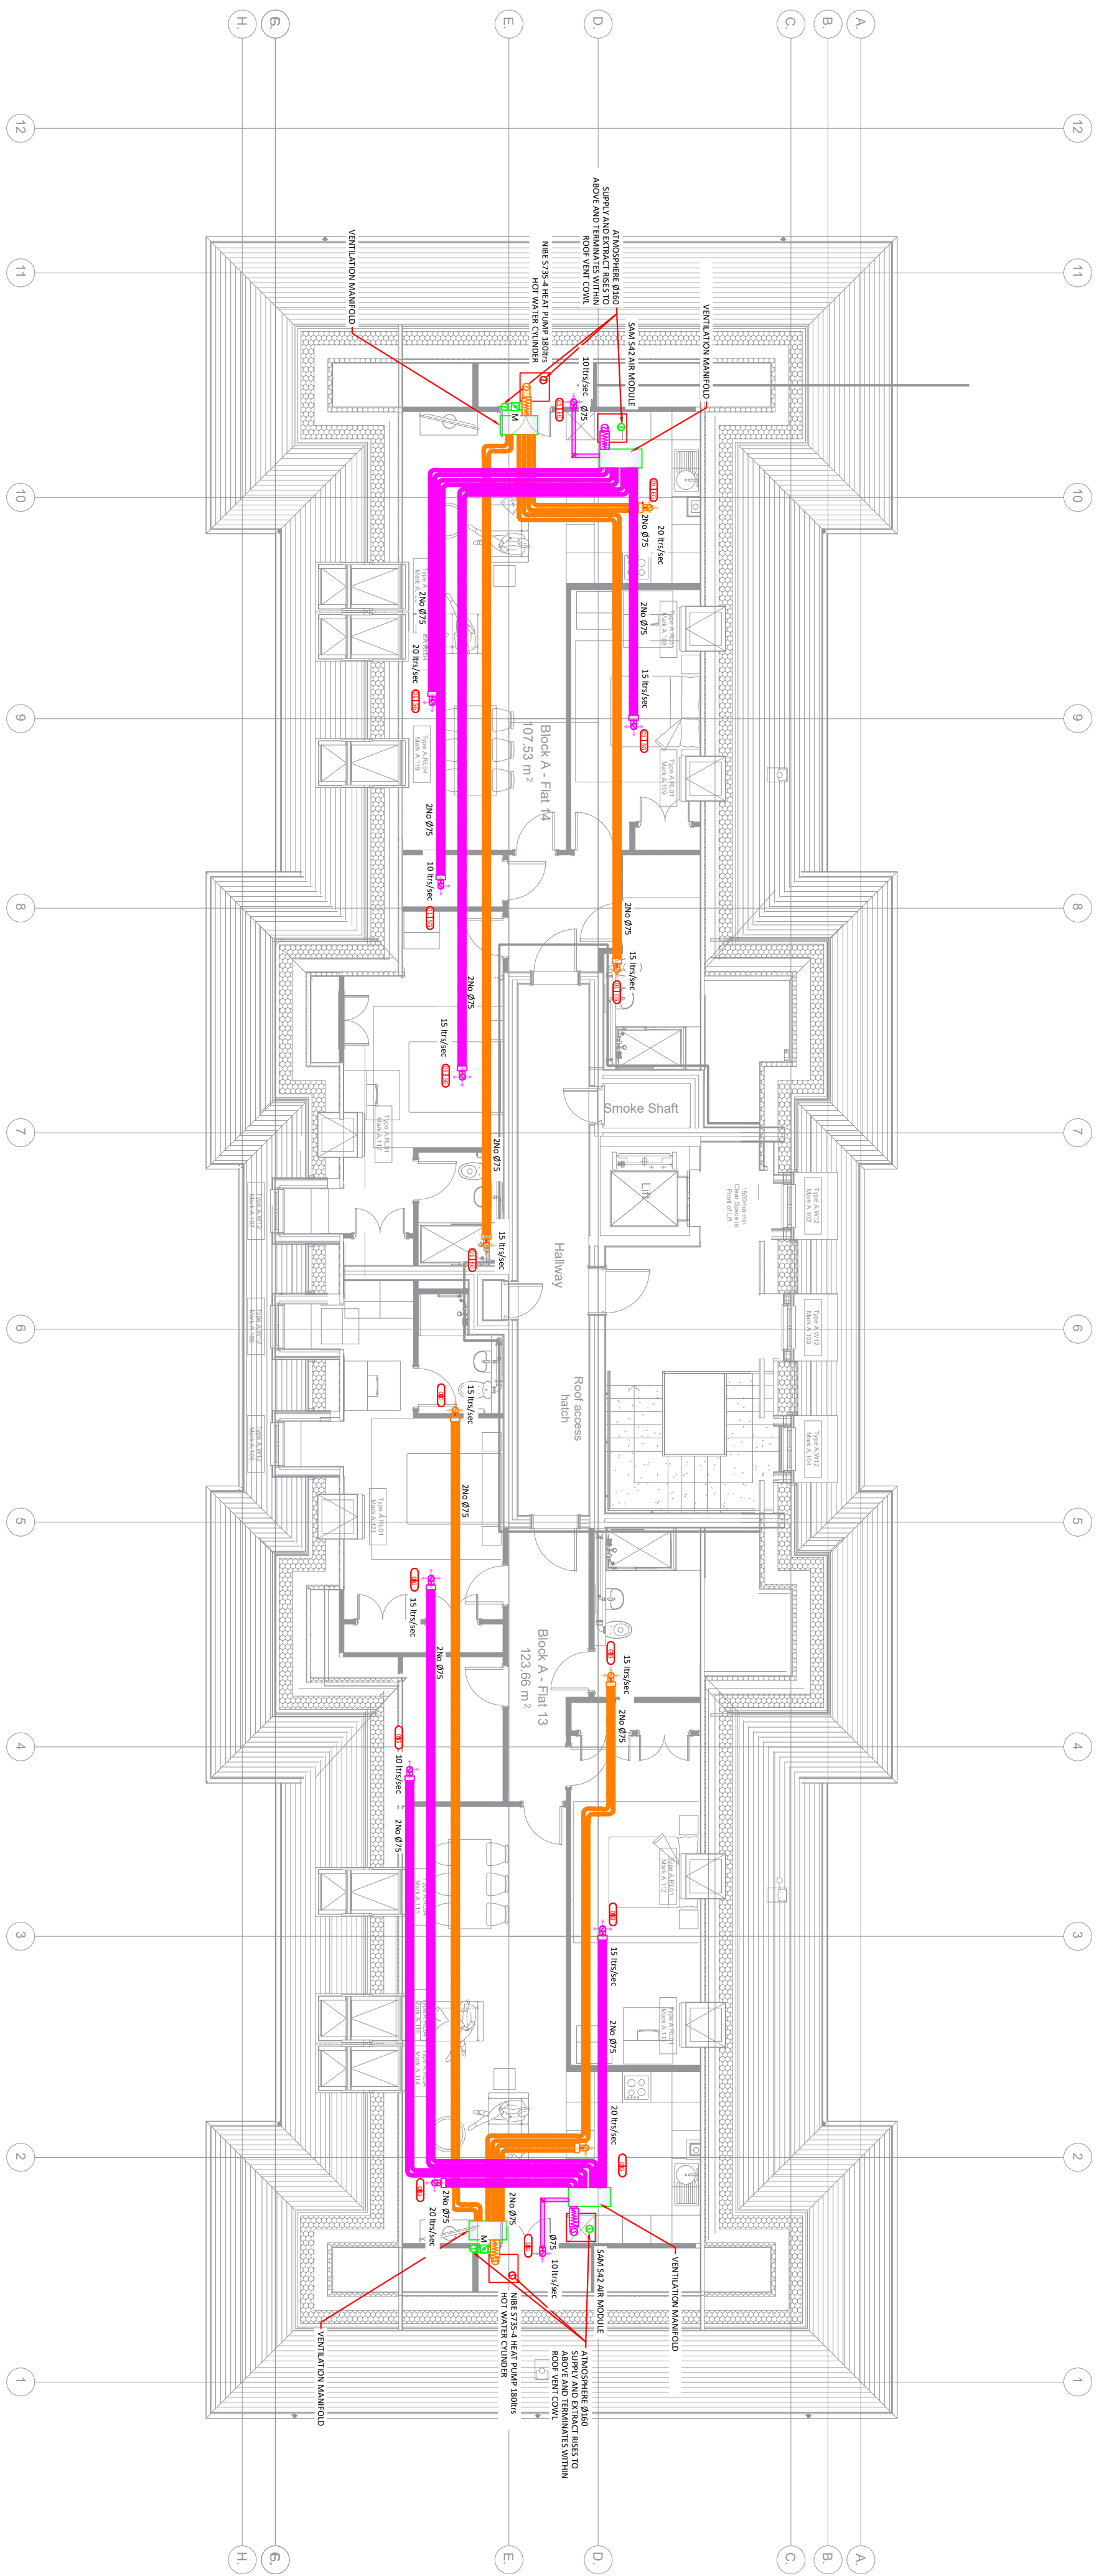

REVISION	DATE	COMMENTS
-	-	-
PROJECT		
Sussex Down Block A		
CLIENT		
		
		
DRAWING TITLE		
Ventilation Layout Second Floor		
DRAWN BY:	APPROVED BY:	DATE
CRA	SPT	22.09.25
DRAWING NUMBER	REVISION	
043RSD U30 021	P01	