


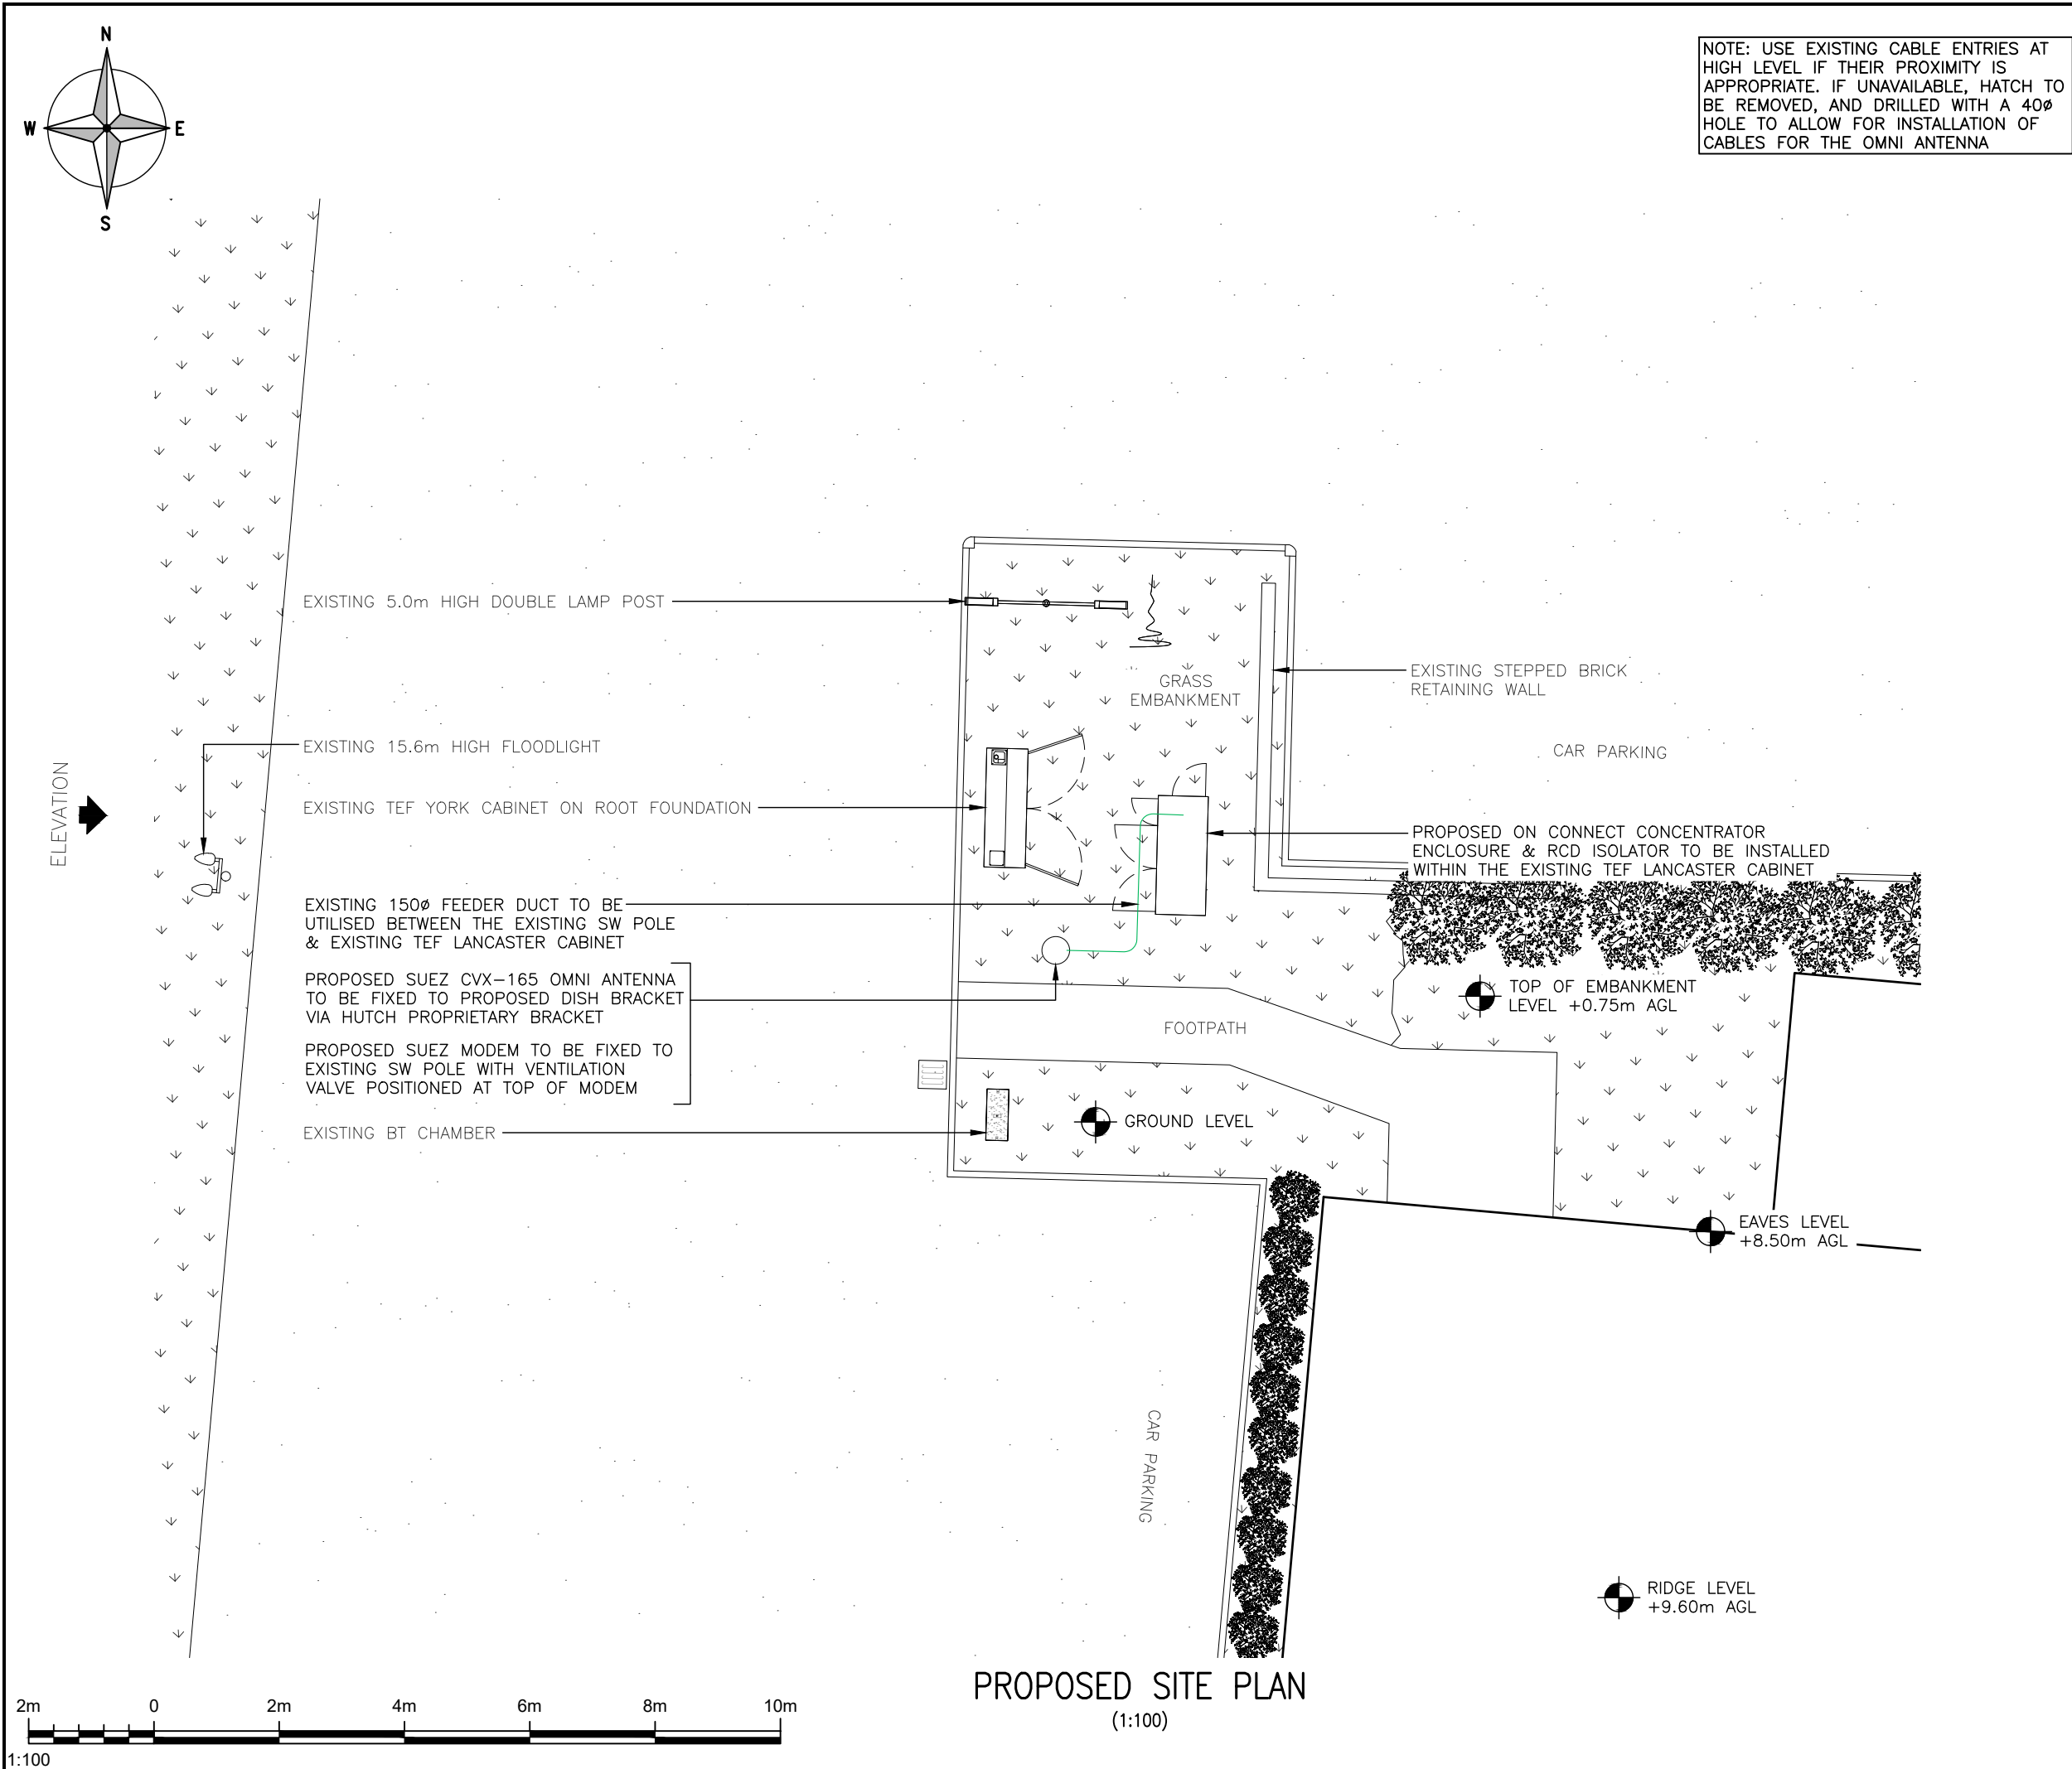

ALL DIMENSIONS ARE IN mm UNLESS NOTED OTHERWISE

N.G.R

E: 508131

N: 114608

DUCT KEY

EXISTING 100mm POWER

EXISTING 100mm COMMS

EXISTING 150mm FEEDER

EXISTING 100mm INCOMING*

PROPOSED 100mm POWER

PROPOSED 100mm COMMS

PROPOSED 150mm FEEDER

PROPOSED 100mm POKE-OUT*

PROPOSED 150mm FIBRE

*INCOMING AND POKE-OUT DUCTS TO BE COLOURED BY DUCT TYPE (POWER/COMMS/FEEDER).

TX DUCTS TO BE TERMINATED 1m FROM EDGE OF CABINET

NOTE: TEMPORARY SOLUTION TO BE INSTALLED IN LIEU OF PERMANENT SOLUTION WHICH IS TO BE COMPLETED BY TELENT. ALL DEPENDENCIES TO BE COMPLETE BY TELENT TO CONFIRM PERMANENT SOLUTIONS VIABILITY. UI HAVE NOT ATTENDED SITE TO VERIFY EXISTING INFRASTRUCTURE

NOTE: UNISTRUT TO BE CUT TO APPROPRIATE LENGTHS AND CAPS TO BE UTILISED TO ENSURE NO UNPROTECTED EDGES

1A	CONSTRUCTION ISSUE	UI	UI	17/03/26
REV	MODIFICATION	BY	CH	DATE

united infrastructure

United Infrastructure

4 Clearwater, Lingley Mere Business Park, Lingley Green Avenue, Great Sankey, Warrington, WA5 3UZ

t. 44 (0)151 420 4128

www.unitedinfrastructure.com

cornerstone

Cell Name				Opt.
IMPULSE LEISURE CENTRE				A
Cell ID No				
CSID	VF	TEF		
234680	—	79182		
Project No.	TM Cell ID	N/A		
23468024	—	—		
Site Address / Contact Details				
LAND AT CAR PARK AT RECREATION GROUND SPIERBRIDGE ROAD STARRINGTON WEST SUSSEX RH20 4BG				
Drawing Title: PROPOSED SITE PLAN				
Purpose of issue: CONSTRUCTION				Dwg Rev:
Drawing Number: 201				1A
Surveyed By: CA		Original Sheet Size: A3		Pack Issue:
Drawn: UI	Date: 17/03/26	Checked: UI	Date: 17/03/26	1A

SDNT0005 Version 3.2