


BUILDING SURVEY - LEGEND			
WINDOW DETAIL HEIGHTS		SUSPENDED CEILING	S/C
FLOOR TO CELL HEIGHT	C	FALSE CEILING	F/C
CELL TO HEAD OF WINDOW	CH	CEILING	CL
CELL TO SPRING	C/S	SKYLIGHT	SL
		UNDERSEDE	US
ARCH DETAIL HEIGHTS		OVERHEAD	OH
FLOOR TO SPRING	S	FLOOR TO FLOOR HEIGHT	FL-FL
FLOOR TO HEAD	H	FLOOR LEVEL	FL
		THRESHOLD LEVEL	TL
DRAINAGE		BEAM LEVEL	BLM
INSPECTION COVER	IC	SOFFIT LEVEL	S/L
COVER LEVEL	CL	EAVES LEVEL	EL
INVERT LEVEL	IL	RODGE LEVEL	RL
GULLY	G	FINISHED FLOOR LEVEL	PFL
RAIN WATER PIPE	RWP	SLOPE UP	SUp
SOIL VENT PIPE	SVP	UP ARROW	UP
VENT PIPE	VP	FLOOR TO CEILING HEIGHT	(1234)

TOPOGRAPHICAL SURVEY - LEGEND			
BWF	Barbed Wire Fence	ELEC	Electricity
CBF	Close Boarded Fence	EP	Electricity Pole
CIF	Corrugated Iron Fence	ER	Earth Rod
CLF	Chain Link Fence	F/B	Flower Bed
ILF	Interwoven Fence	FH	Fire Hydrant
LIF	Larch Lap Fence	G	Gully
MRF	Metal Railings	GV	Gas Valve
OSF	Open Board Fence	HA	Height
PALF	Paling Fence	IC	Inspection Cover
PRF	Post & Rail Fence	KO	Kerb Outlet
RWP	Post & Wire Fence	LB	Litter Bin
RW	Retaining Wall	LP	Lamp Post
WMF	Wire Mesh Fence	MH	Manhole
		Mbr	Marker
BL	Bed Level	NP	Name Plate
CL	Cover Level	OH	Overhead
EL	Eaves Level	P	Post
FL	Floor Level	PE	Pipe
IL	Invert Level	RE	Rodding Eye
RL	Ridge Level	RS	Road Sign
RFL	Road Level	RWP	Rainwater Pipe
ToW/TdF	Top of Wall/Fence Level	SC	Stop Cock
WL	Water Level	SV	Stop Valve
		TS	Telegraph Pole
		UTL	Unable To Lift
BT	British Telecom	WM	Water Meter
CATV	Cable Television	WO	Wash Out
CT	Cabinet		
DP	Down Pipe		

Notes:
All Levels are related to TBM Value: 20.00m
Situatued on floor level of main entrance hall as shown on Ground Floor plan.

North Point is indicative only.

All dimensions to be verified on site prior to construction.
No dimensions to be scaled from this drawing.

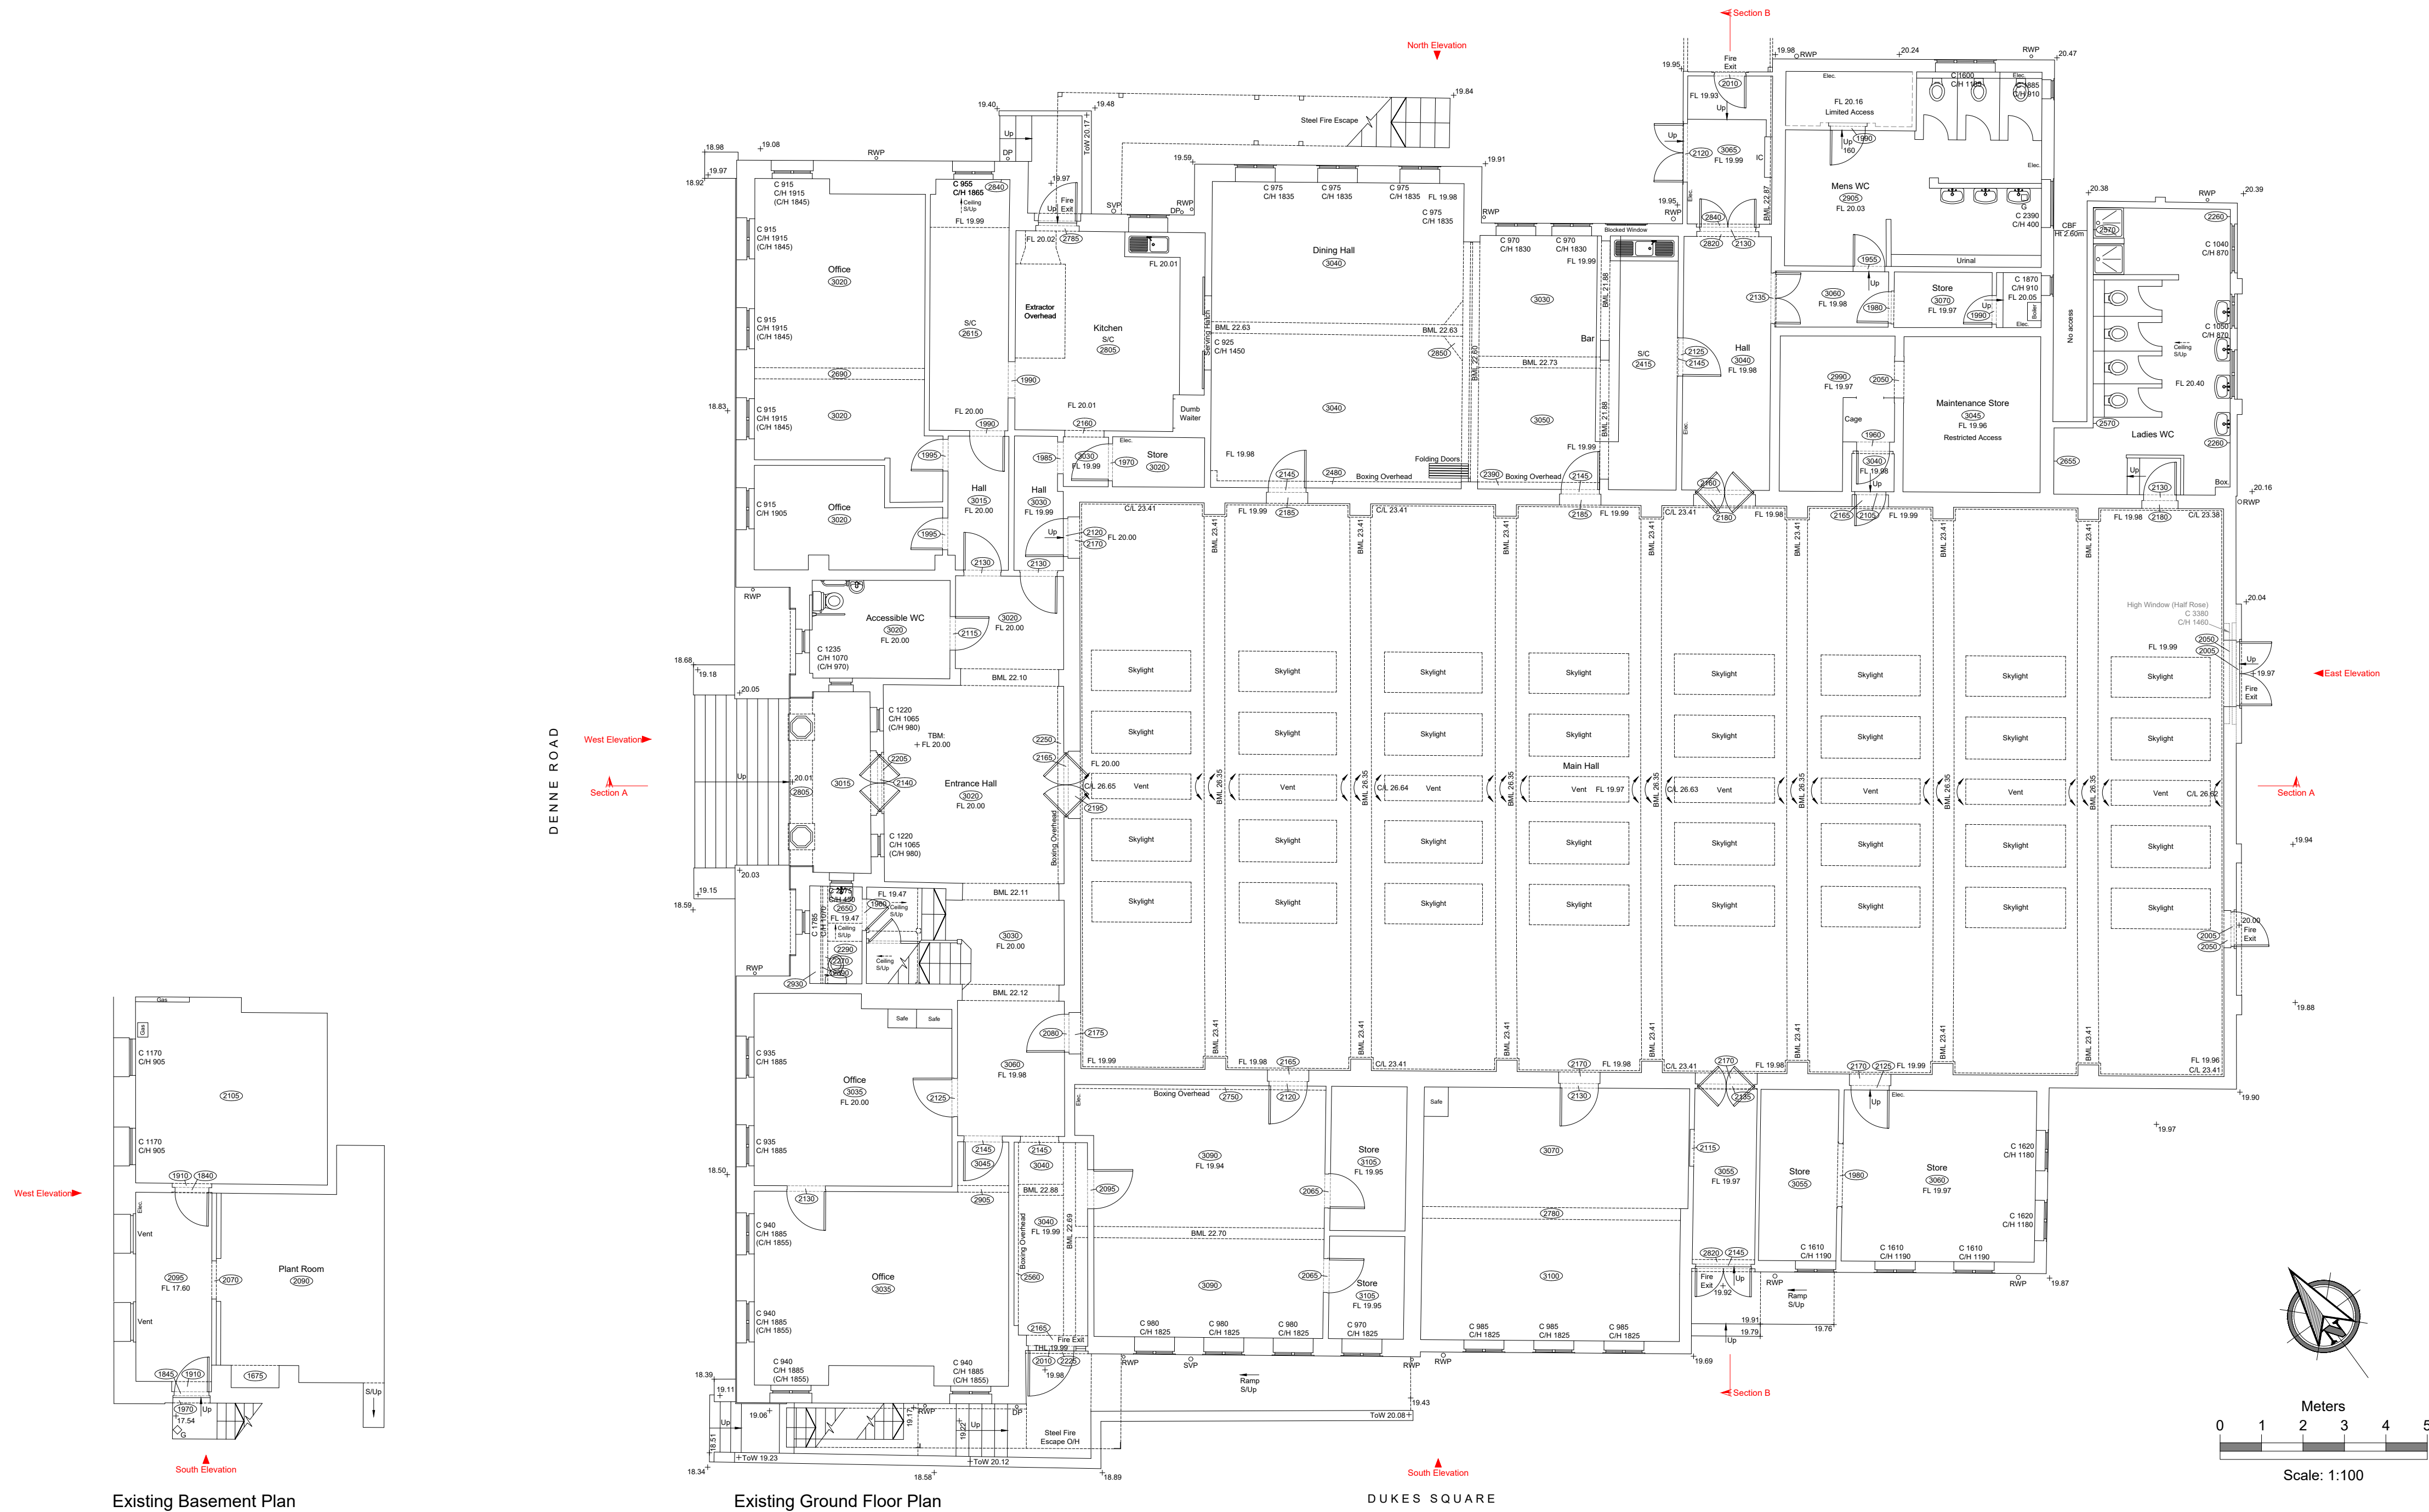

Contact us:
mob: +44 (0) 7786 952804
mob: +44 (0) 7880 984831
email: info@perceptumdesign.co.uk
website: www.perceptumdesign.co.uk

Project:
Drill Hall
Denne Road, Horsham
Existing Basement/Ground Plan

Client:
Lifespring
Jubilee House, Worthing Road
Southwater
RH13 9JB

Date: Sept 2023	Drawn: CP	Checked: SB
Scale: 1:100 @ A1		
Project No: PD/755/SW	Drawing No: PD/755/SW/01	Revision: