



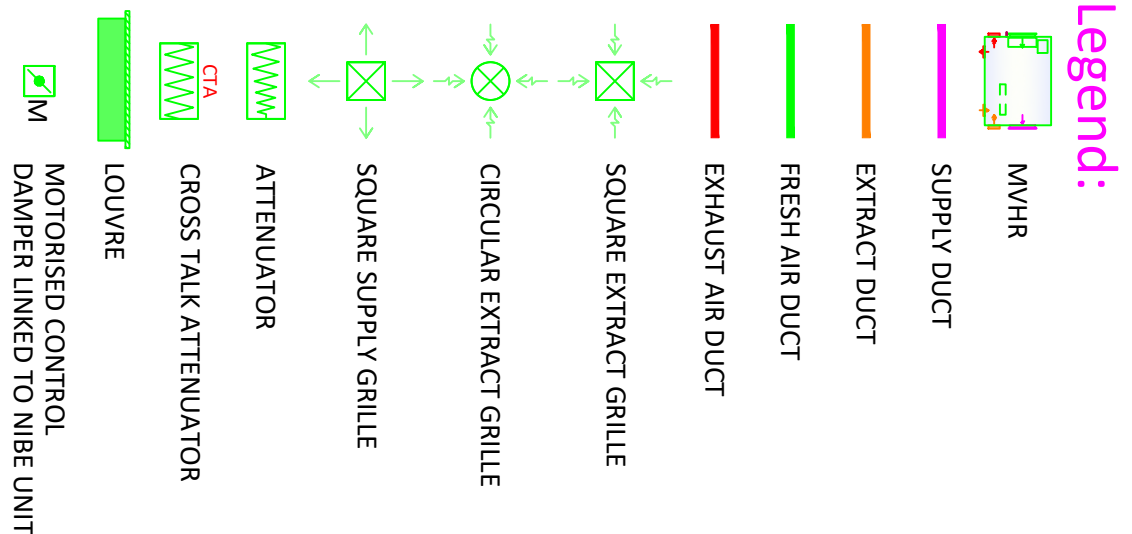

- Notes:**
- DO NOT SCALE THIS DRAWING. ALL DIMENSIONS IN MILLIMETRES UNLESS OTHERWISE STATED.
 - THIS DRAWING IS TO BE READ IN CONJUNCTION WITH ALL RELEVANT ARCHITECT'S STRUCTURAL ENGINEERS AND MBE DRAWINGS AND THE MBE SPECIFICATION, SAMPLES SHEET AND ROOM DATA SHEETS.
 - ALL ITEM OF EQUIPMENT SHALL BE INSTALLED AS TO THE MANUFACTURER'S RECOMMENDATIONS.
 - ALL INFORMATION AND LAYOUTS DETAILED ON THIS DRAWING ARE SUBJECT TO SITE DIMENSION CHECKS.

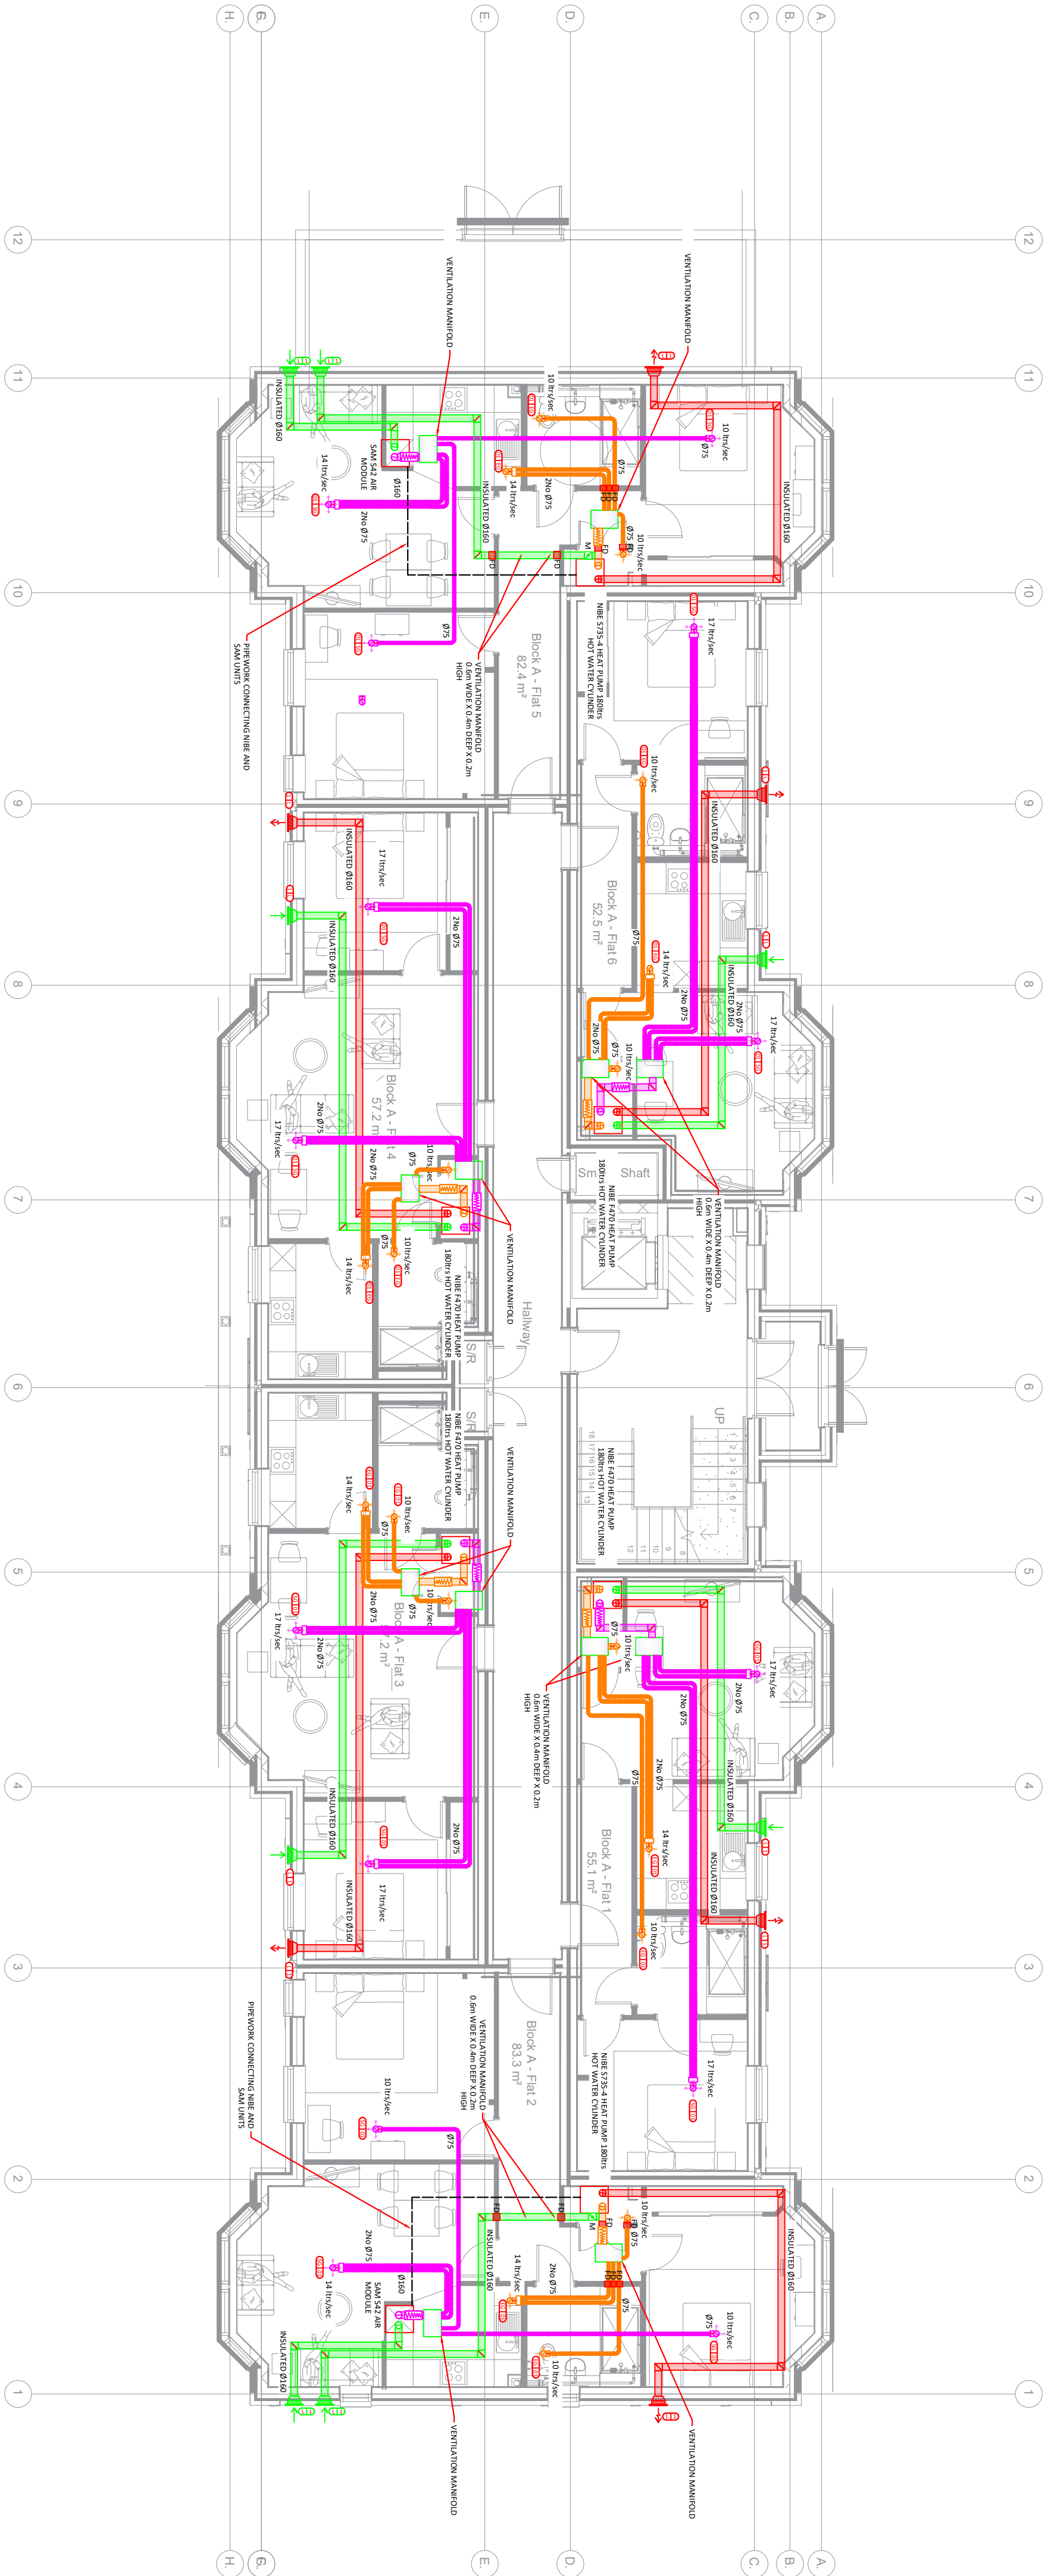

Please note: If scaling from pdf, measurements may be inaccurate due to pdf conversion from dwg.

REVISION		DATE	COMMENTS
-			
PROJECT			
Sussex Down Block A			
CLIENT			
			
 SPT Consulting SUSTAINABLE ENGINEERING			
DRAWING TITLE			
Ventilation Layout Ground Floor			
DRAWN BY:	APPROVED BY:	DATE	SCALE - A1
CRA	SPT	22.09.25	1:100
DRAWING NUMBER			REVISION
043RSD U30 001			P01