 


 
Legend:

MVAR

SUPPLY DUCT

EXTRACT DUCT

 
FRESH AIR DUCT

EXHAUST AIR DUCT

SQUARE EXTRACT GRILLE

CIRCULAR EXTRACT GRILLE

SQUARE SUPPLY GRILLE

ATTENUATOR

CROSS TALK ATTENUATOR

LOUVRE


VOLUME CONTROL DAMPER

- Notes:
1. DO NOT SCALE THIS DRAWING. ALL DIMENSIONS IN MILLIMETRES UNLESS OTHERWISE STATED.

2. THIS DRAWING IS TO BE READ IN CONJUNCTION WITH ALL RELEVANT ARCHITECT'S STRUCTURAL ENGINEERS AND MBE DRAWINGS AND THE MBE SPECIFICATION, SAMPLES SHEET AND ROOM DATA SHEETS.

3. ALL ITEM OF EQUIPMENT SHALL BE INSTALLED AS TO THE MANUFACTURER'S RECOMMENDATIONS.

4. ALL INFORMATION AND LAYOUTS DETAILED ON THIS DRAWING ARE SUBJECT TO SITE DIMENSION CHECKS.

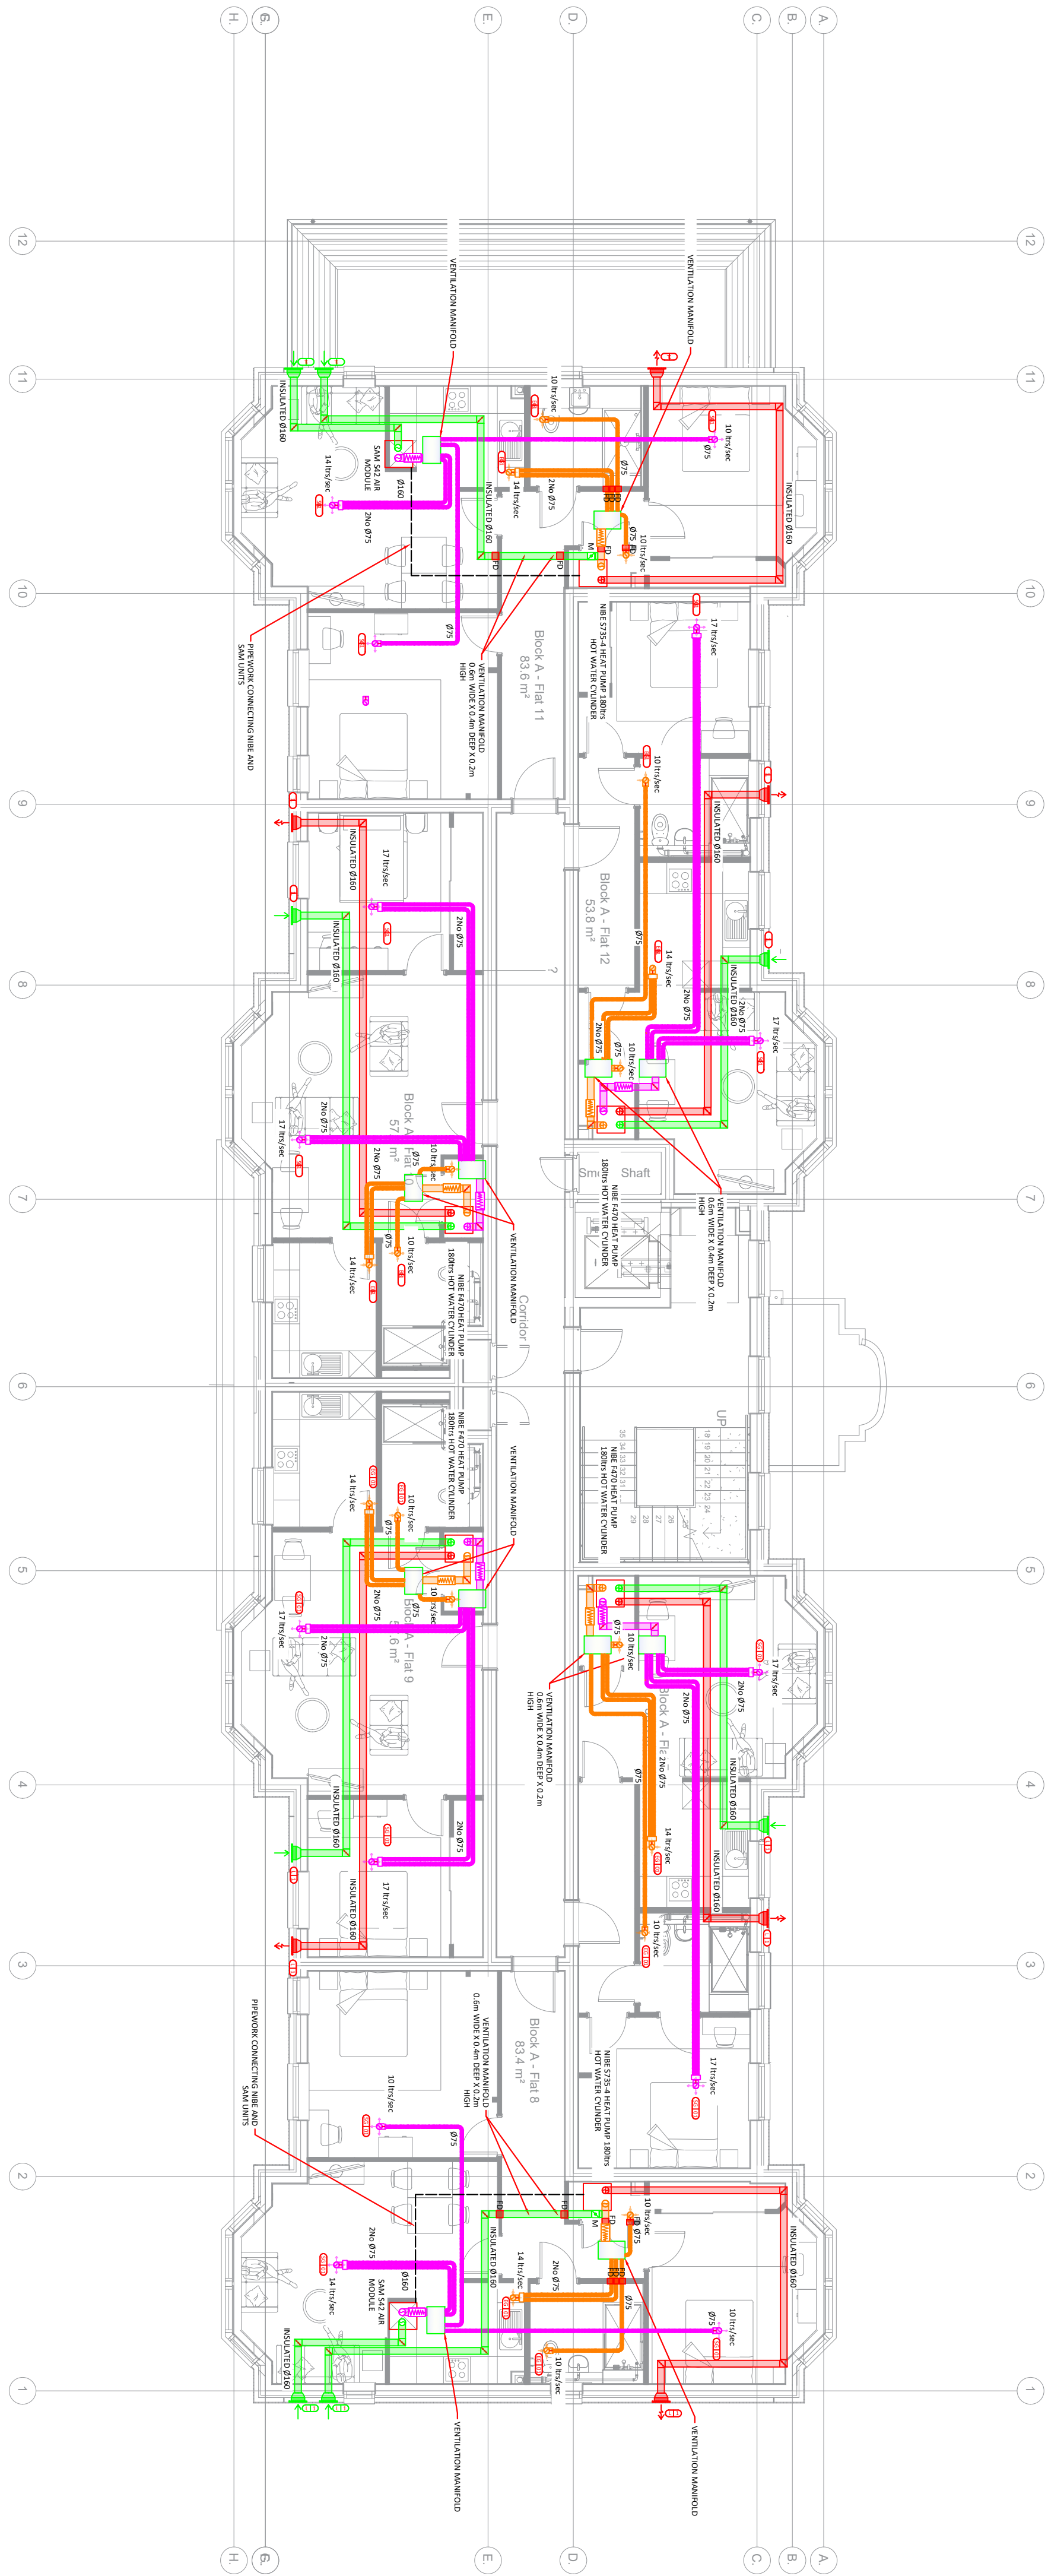

REVISION

DATE

COMMENTS

-

-

-

PROJECT

Sussex Down
Block A

CLIENT



DRAWING TITLE

Ventilation Layout
First Floor

DRAWN BY: CRA

APPROVED BY: SPT

DATE: 22.09.25

SCALE: A1

DRAWING NUMBER

043RSD U30 011

REVISION

P01