


This drawing shall not be
scaded.
Work from the dimensions shown
in the drawing or given in
the schedule shall prevail.
This drawing is to be used as a
guide only, please refer to scope
of works for specific quantities
and details

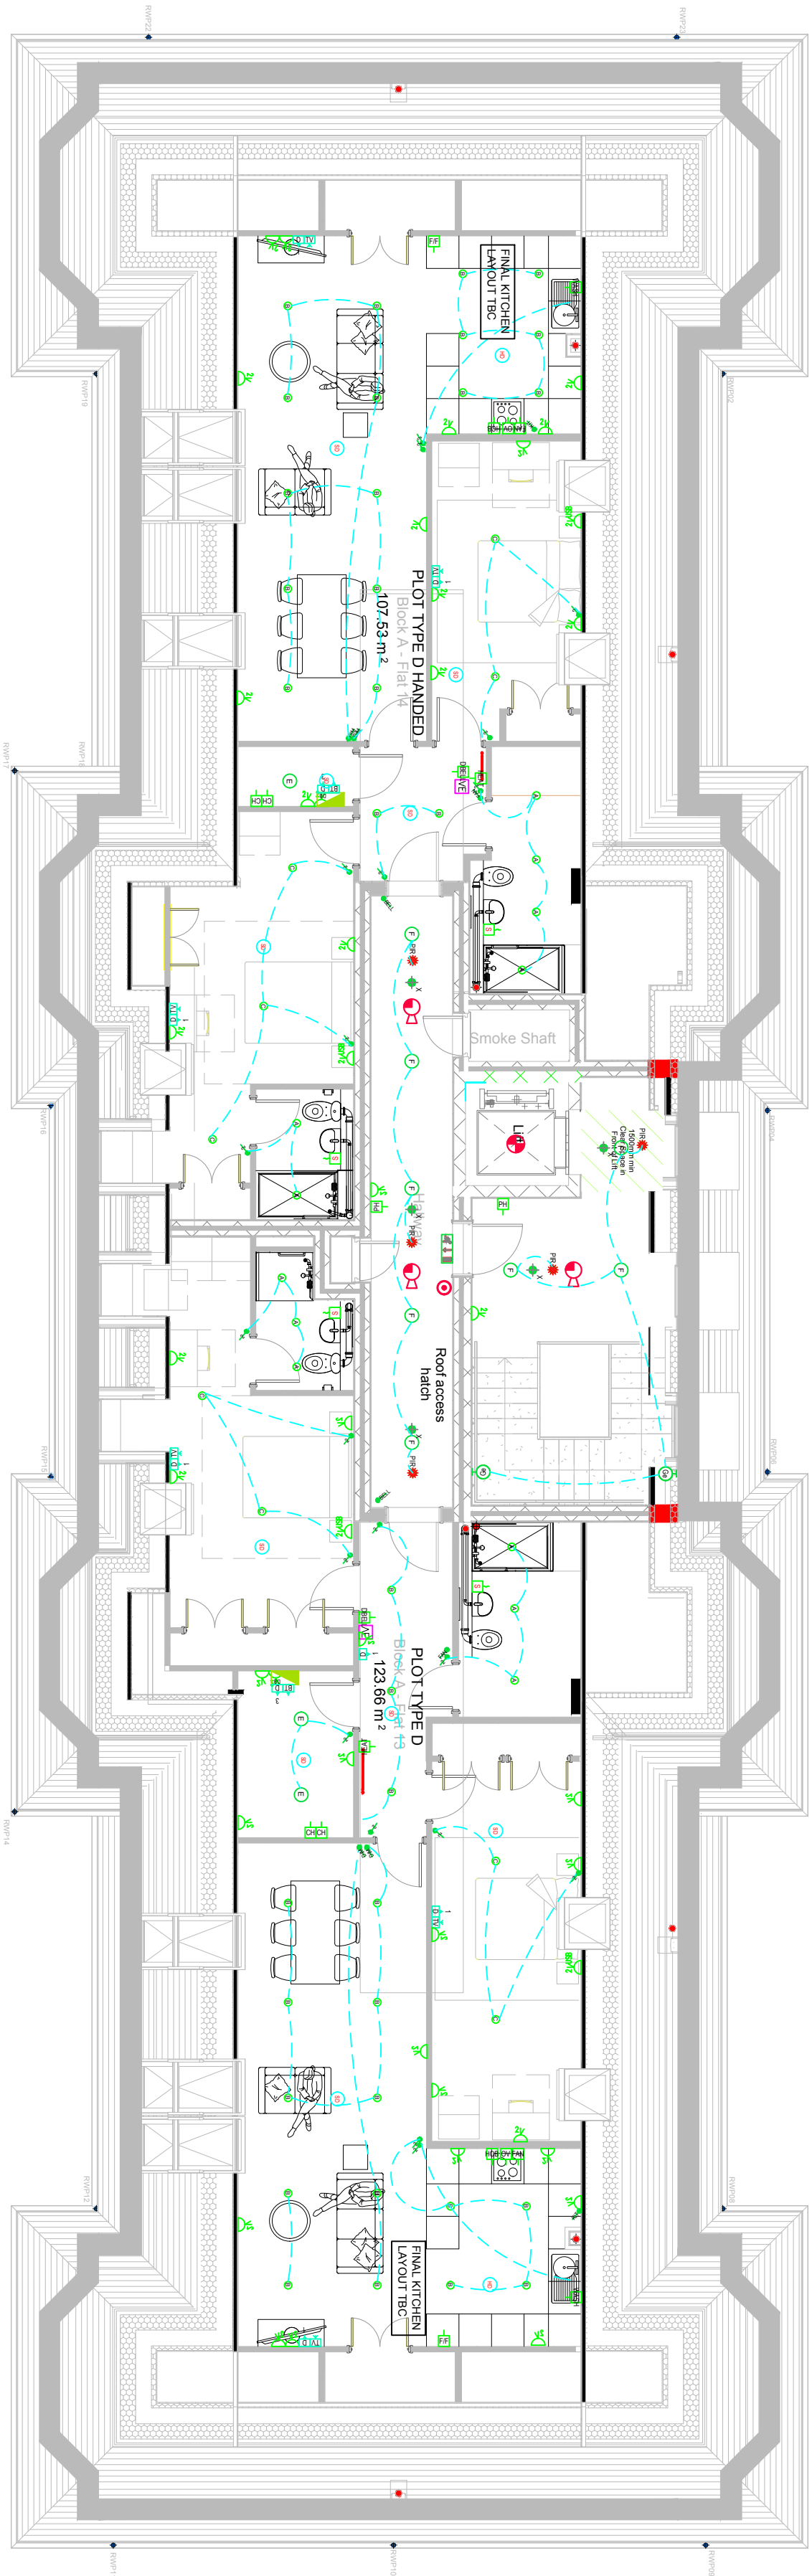

CDM Regulations:
In addition to any information included in this drawing or the model from which it is derived, refer also to the project CDM Risk Register for information on residual risks

General Notes:
· This drawing does not necessarily show all the information needed to interpret the design intent or the construction details.
· The drawing contains information from more than one source and must be read in conjunction with all other drawings and specifications.
· Any apparent drafting errors and differences between other drawings and specifications shall be brought to our attention.

Project Notes:

DENOTES

- NC = NURSE CALL
- OS = OUTSIDE
- CV = CEILING VOID OR MOUNTED
- HT = HOT TROLLY
- SD = SMOKE DAMPER
- FA = FIRE ALARM
- AC = AIR CONDITIONING
- HM = HEATING MANIFOLD
- TH = TRACE HEATING
- AH = AIR HANDLING UNIT
- WP = WATER PUMP
- SP = SPRINKLER PUMP
- HOB = KITCHEN HOB
- EXT = KITCHEN EXTRACT
- OVE = KITCHEN OVEN
- DBELL = DOOR BELL CHIME
- F/F = FRIDGE FREEZER
- DISH = DISHWASHER
- WASH = WASHING MACHINE
- FAN = EXTRACT FAN
- CH = CENTRAL HEATING SYSTEM
- PH = FUTURE PANEL HEATER POSITION

NO	FOR SUBMITTAL	TA	RM	RM	NOV25
Issue	Description	Designed	Reviewed	Issued	Date

REVISIONS:



morelec (UK) Ltd
UNIT 4 BOURNEGROVE BUSINESS PARK,
BOURNEGROVE
T. 01235 330000
WWW.MORELEC.NET

ARCHITECT:
CORSTORPHINE & WRIGHT

CLIENT:
PARSONS AND JOYCE

PROJECT TITLE:
SUSSEXDOWN BLOCK A

DRAWING TITLE:
SECOND FLOOR SMALL POWER
AND LIGHTING LAYOUT

FOR SUBMITTAL

PERSON RESPONSIBLE FOR:			
Design:	TA	Review:	RM
Authoring:	RM	Issued:	RM
Project No:	P&J-SD-B&J-24-11		
Date:	24 NOV 2025	Scale:	© A1:
DRAWING NUMBER:	P&J-SD-B&J-24-11-2-2ND-SP-LT-		
Revision:	04		

LUMINAIRES

SMALL POWER

P rated gu10 fitting e - denotes em, m - denoted microwave, D - denotes dimmable

gu10 fitting e - denotes em, m - denoted microwave, D - denotes dimmable

Pendant e - denotes em, m - denoted microwave, D - denotes dimmable

Surface mounted wall / ceiling light e - denotes em, m - denoted microwave, D - denotes dimmable

Surface mounted wall / ceiling light 2d style fitting e - denotes em, m - denoted microwave, D - denotes dimmable

Recessed mounted ceiling light fitting e - denotes em, m - denoted microwave, D - denotes dimmable

Surface mounted wall / ceiling light fitting e - denotes em, m - denoted microwave, D - denotes dimmable

Surface mounted running main exit box

Flush mounted emergency light fitting

Flush mounted fire detector

Flush mounted fire detector

FIRE ALARM

Sounder

Smoke / Heat Detector Sounder

Smoke / Heat Detector Sounder

SECURITY

CCTV Camera

Smoke / Heat Detector Sounder

Smoke / Heat Detector Sounder

