
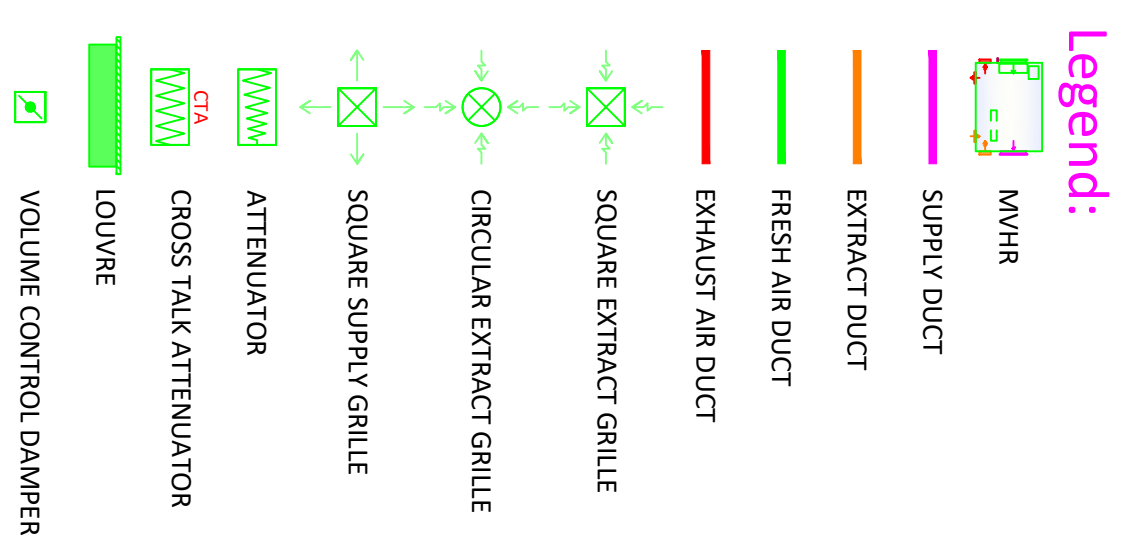


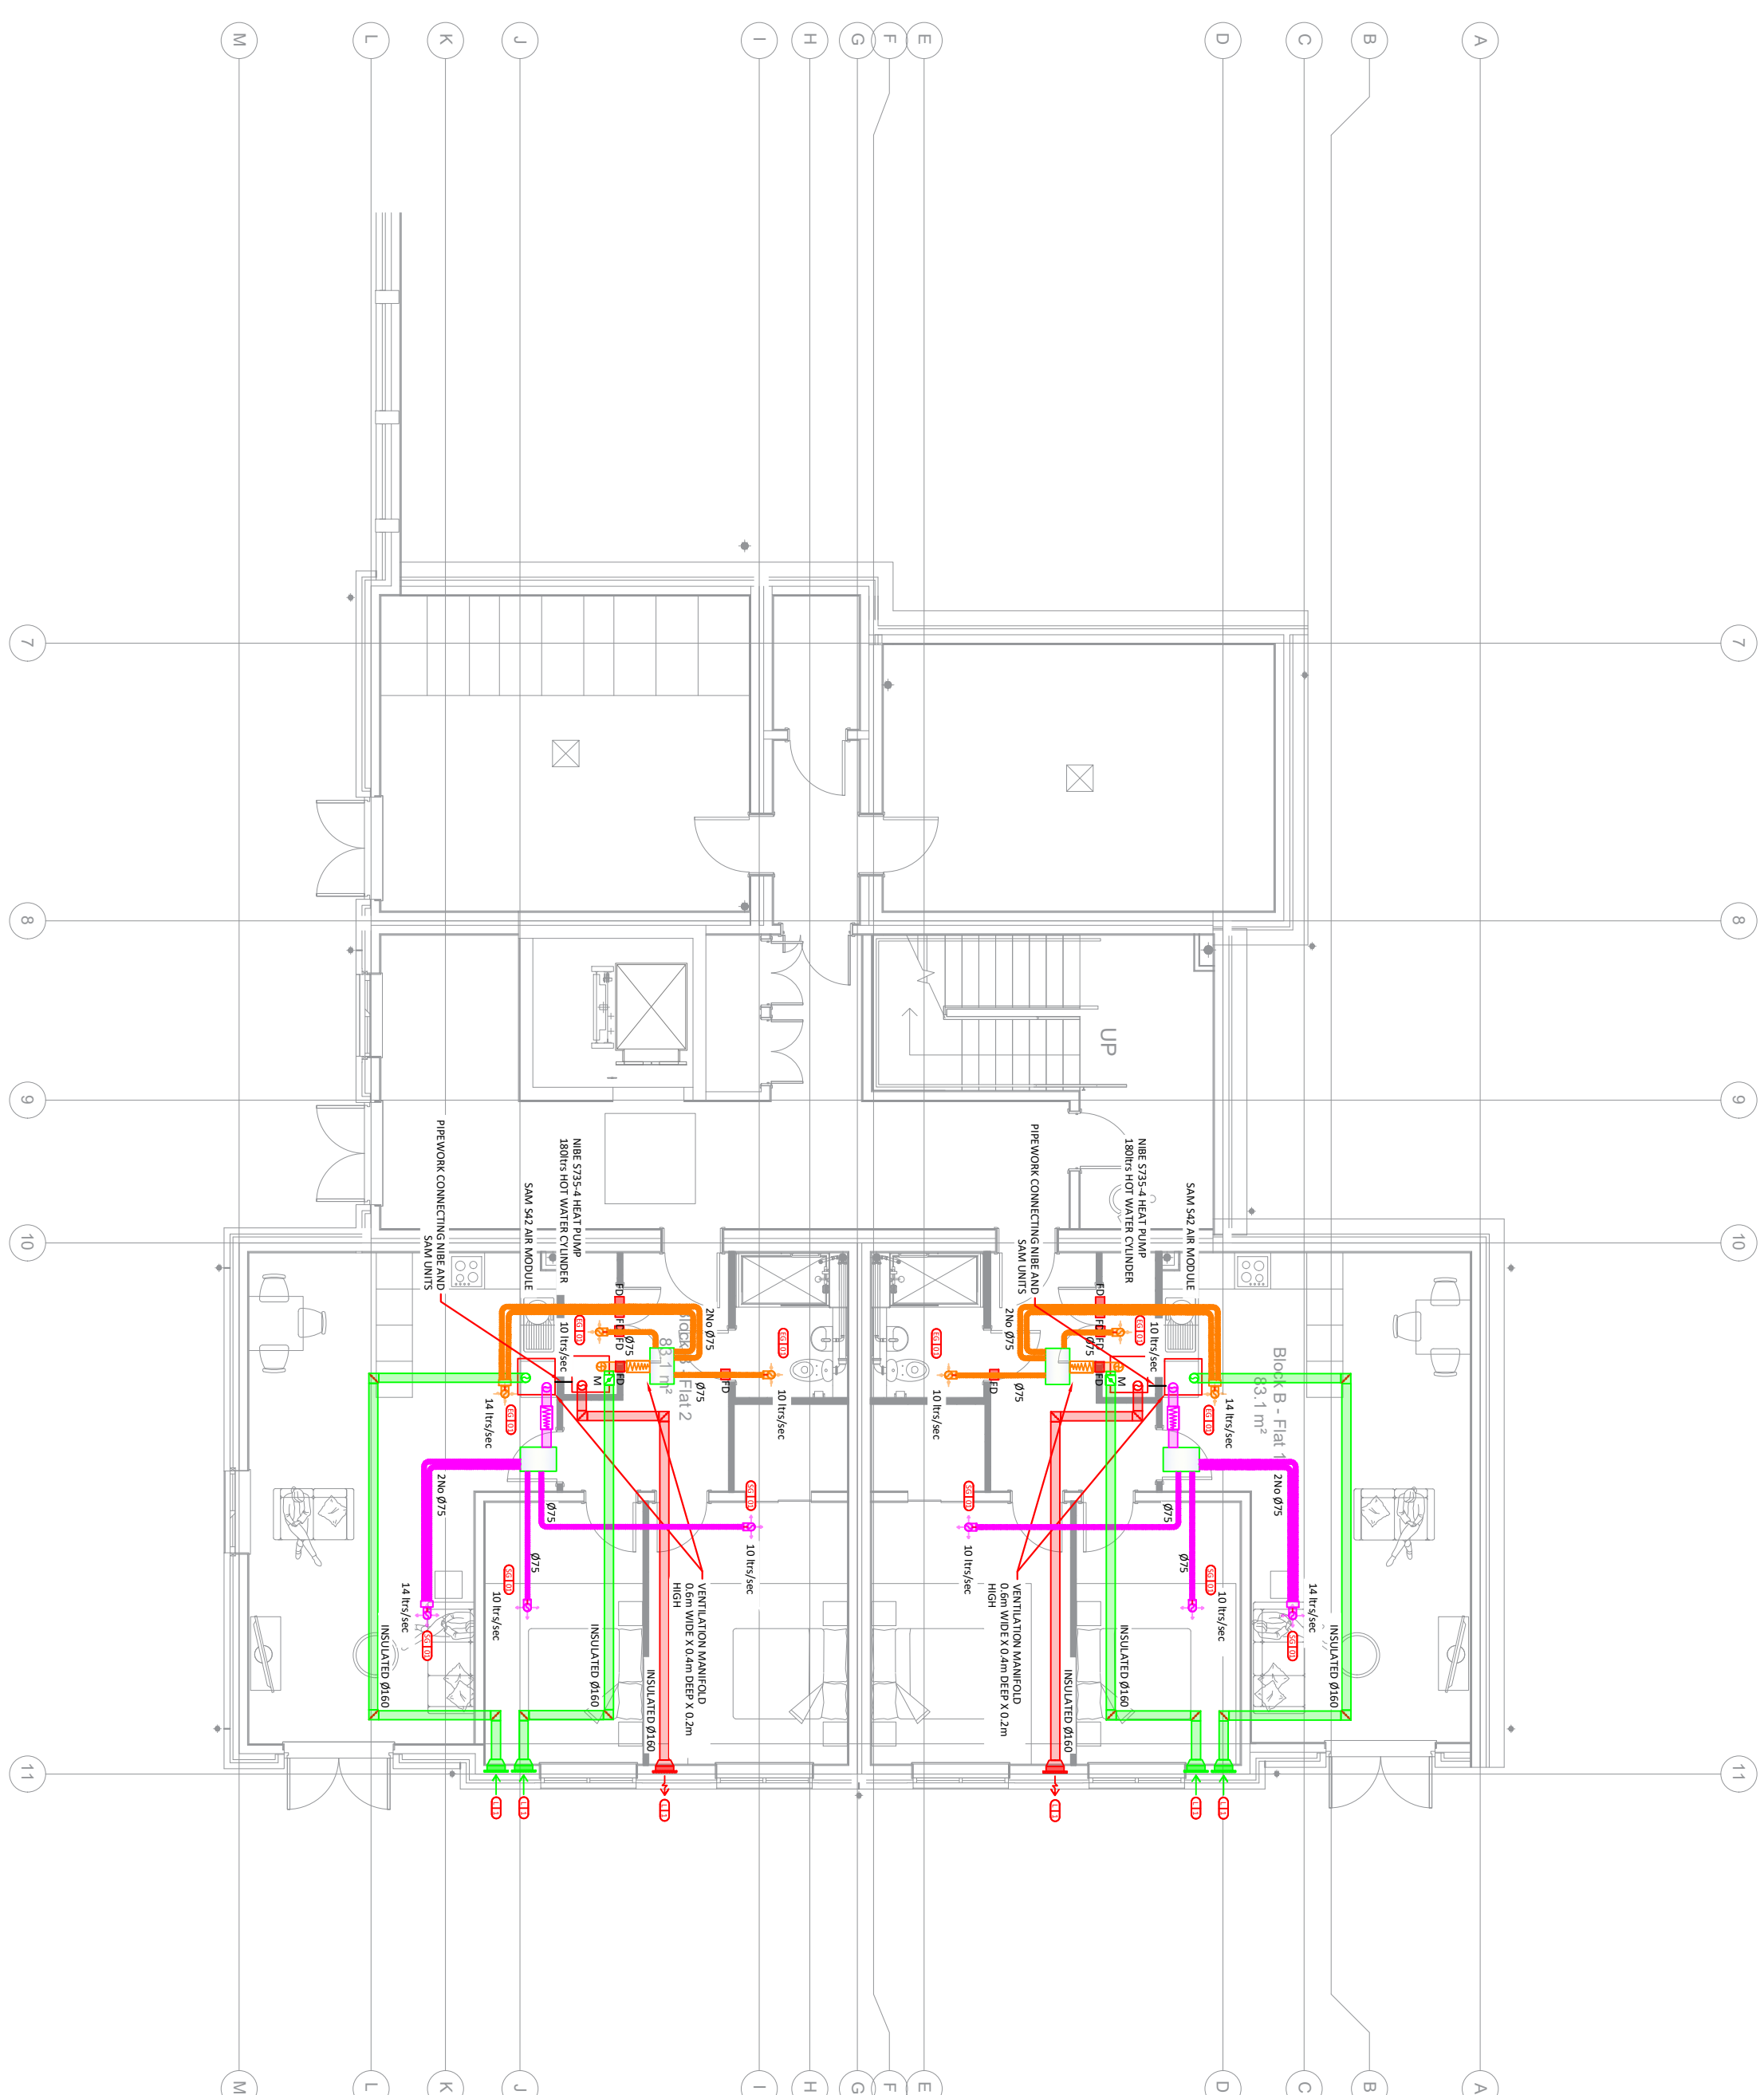

Notes:

1. DO NOT SCALE THIS DRAWING. ALL DIMENSIONS IN MILLIMETERS UNLESS OTHERWISE STATED.
2. THIS DRAWING IS TO BE READ IN CONJUNCTION WITH ALL RELEVANT ARCHITECT'S STRUCTURAL ENGINEERS AND M&E DRAWINGS AND THE M&E SPECIFICATION, SAMPLES SHEET 1 AND ROOM DATA SHEETS.
3. ALL ITEM OF EQUIPMENT SHALL BE INSTALLED AS TO THE MANUFACTURER'S RECOMMENDATIONS.
4. ALL INFORMATION AND LAYOUTS DETAILED ON THIS DRAWING ARE SUBJECT TO SITE DIMENSION CHECKS.

REVISION	DATE	COMMENTS
PROJECT		
Sussex Down Block B		
CLIENT		
		
		
DRAWING TITLE		
Ventilation Layout		
Basement		
DRAWN BY:	APPROVED BY:	DATE
CRA	SPT	22.09.25
DRAWING NUMBER		SCALE - A1
043MSD U30 000		1:100
		REVISION
		P01