



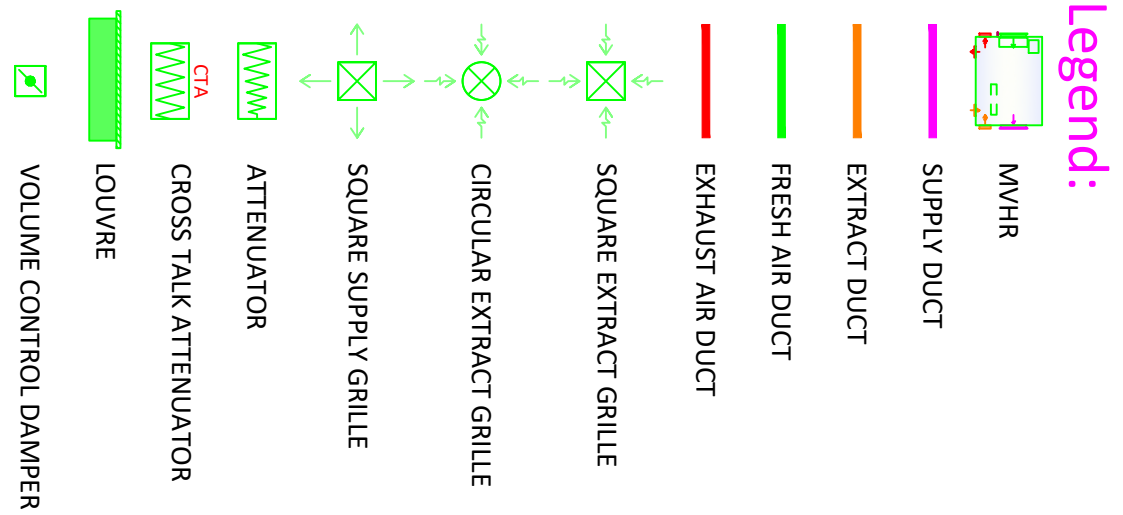

- Notes:**
- DO NOT SCALE THIS DRAWING. ALL DIMENSIONS IN MILLIMETRES UNLESS OTHERWISE STATED.
 - THIS DRAWING IS TO BE READ IN CONJUNCTION WITH ALL RELEVANT ARCHITECT'S STRUCTURAL ENGINEERS AND WEIR DRAWINGS AND THE WEIR SPECIFICATION, SAMPLES SHEET AND ROOM DATA SHEETS.
 - ALL ITEM OF EQUIPMENT SHALL BE INSTALLED AS TO THE MANUFACTURER'S RECOMMENDATIONS.
 - ALL INFORMATION AND LAYOUTS DETAILED ON THIS DRAWING ARE SUBJECT TO SITE DIMENSION CHECKS.

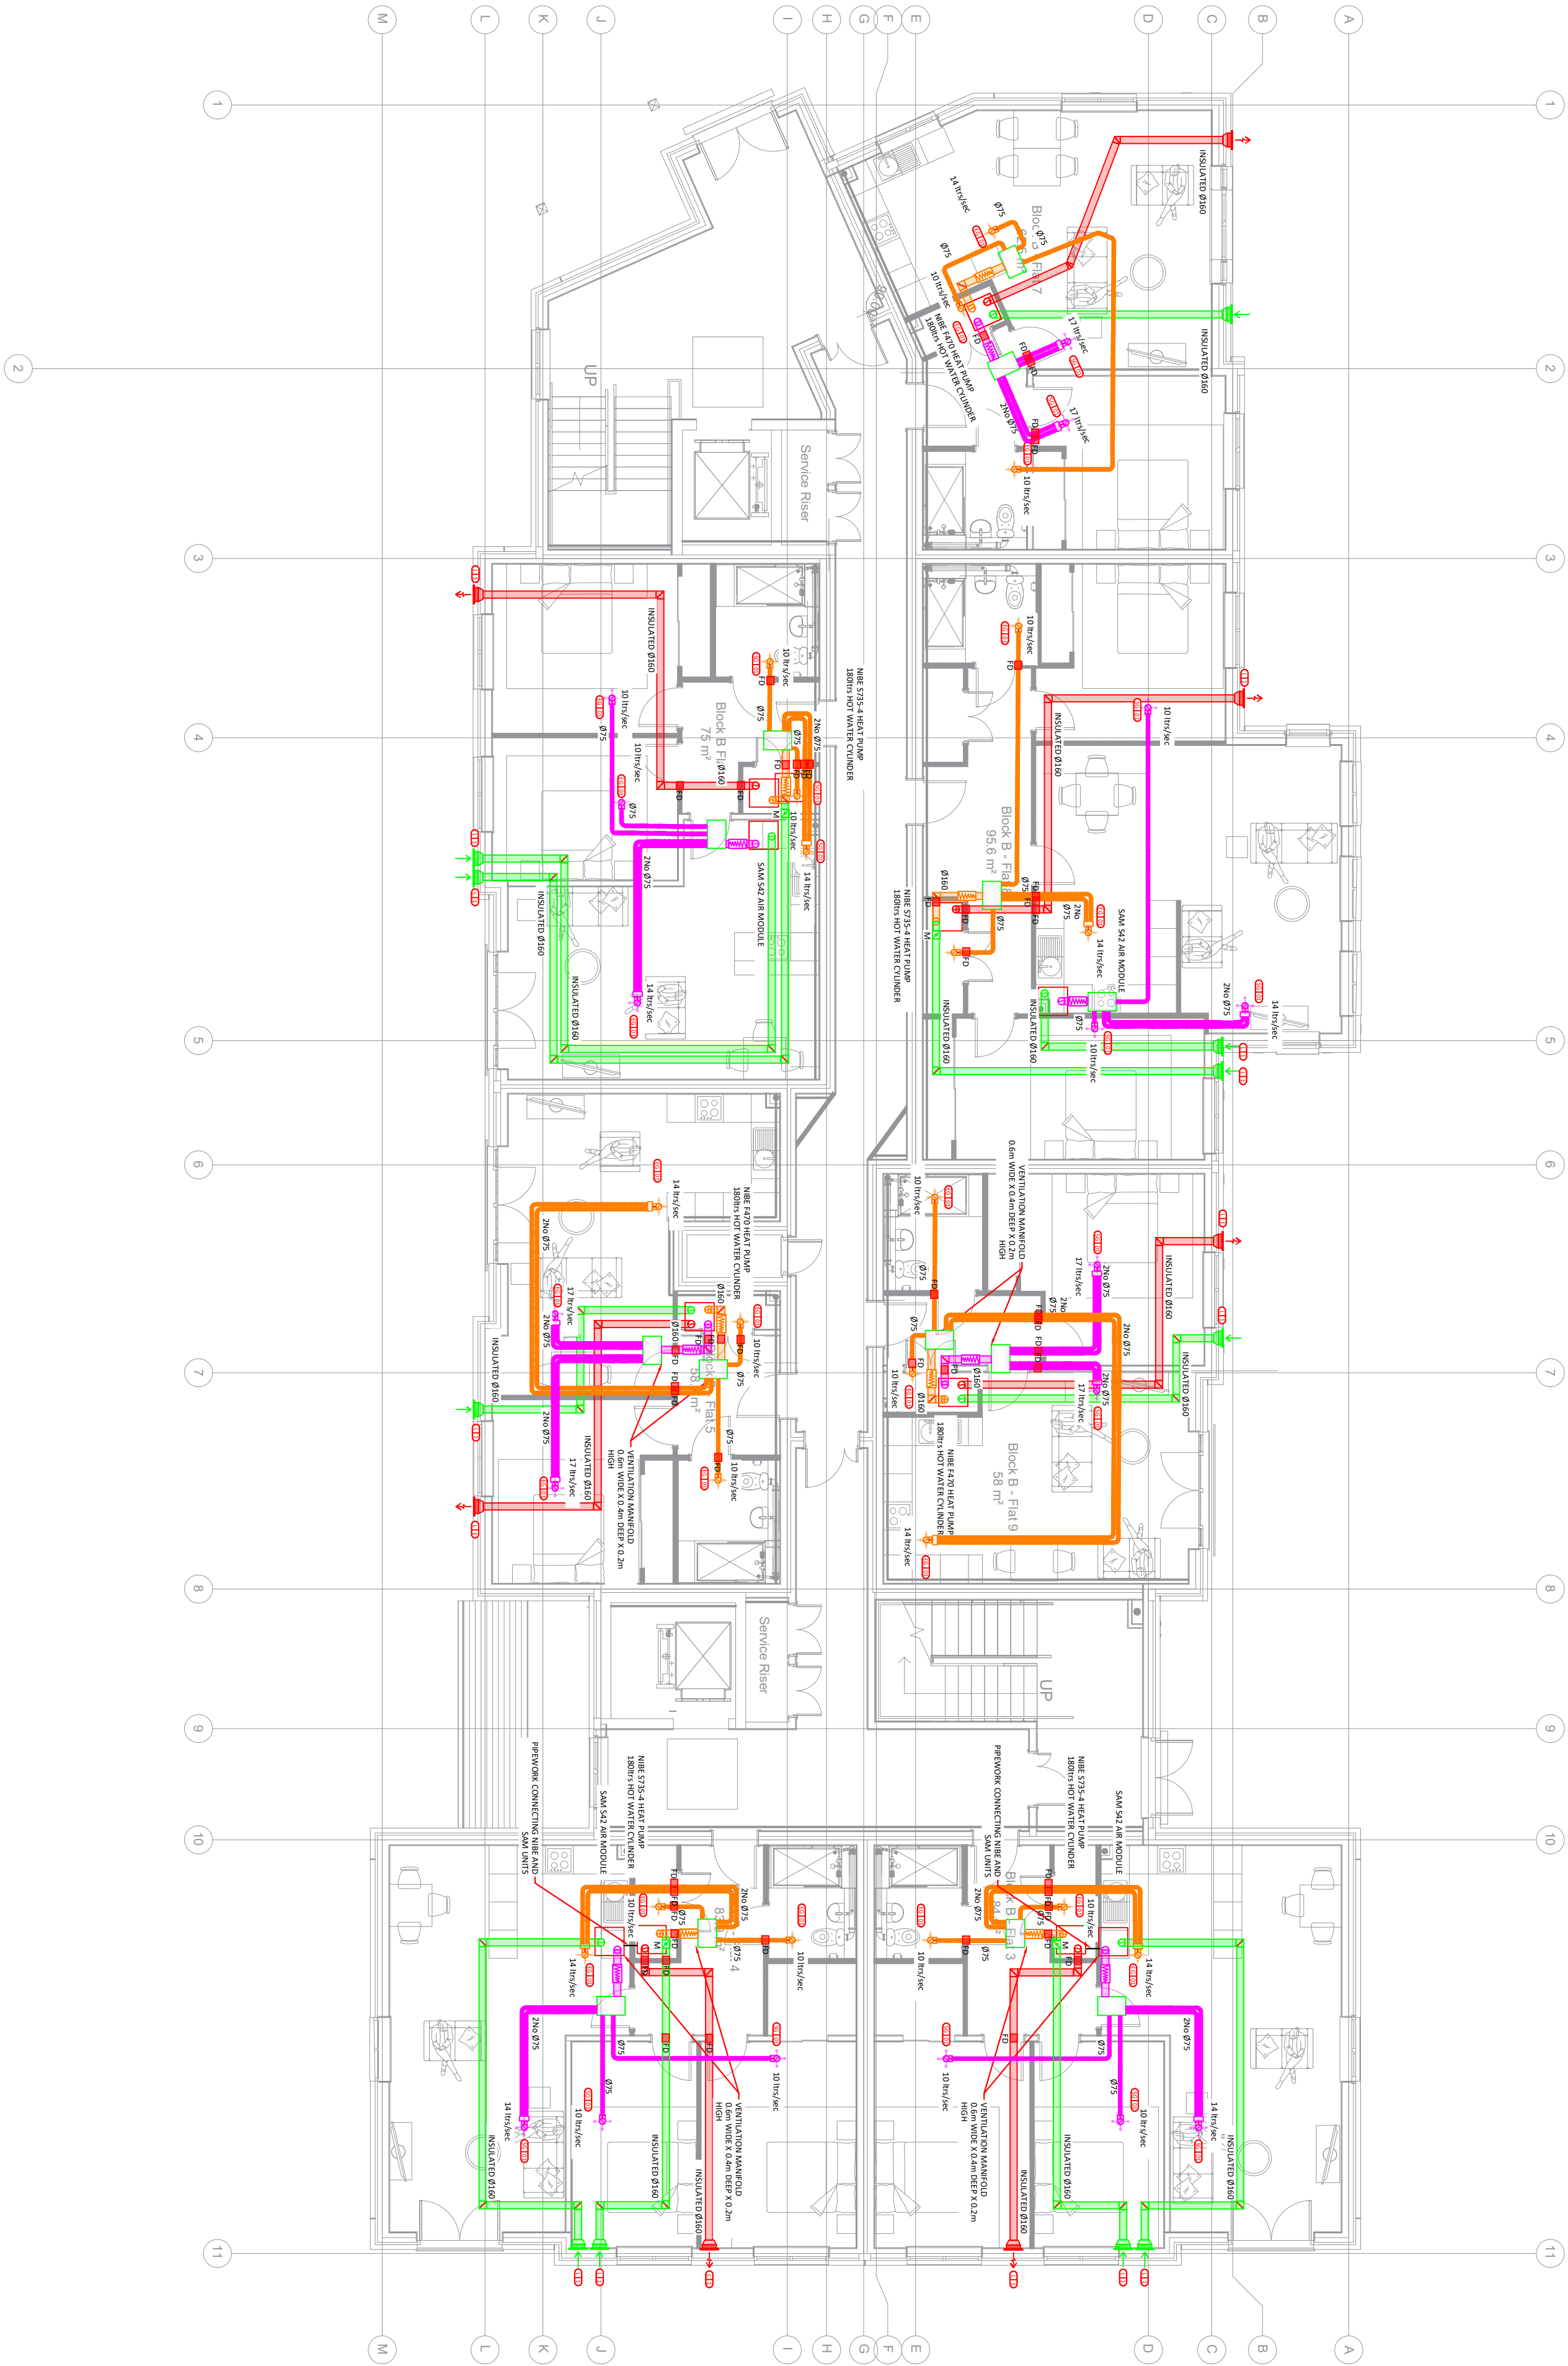

REVISION	DATE	COMMENTS
-	-	-
PROJECT		
Sussex Down Block B		
CLIENT		
		
 SPT Consulting SUSTAINABLE ENGINEERING		
DRAWING TITLE		
Ventilation Layout Ground Floor		
DRAWN BY:	APPROVED BY:	DATE
CRA	SPT	22.09.25
DRAWING NUMBER	SCALE - A1	1:100
043RSD U30 001	REVISION	P01