


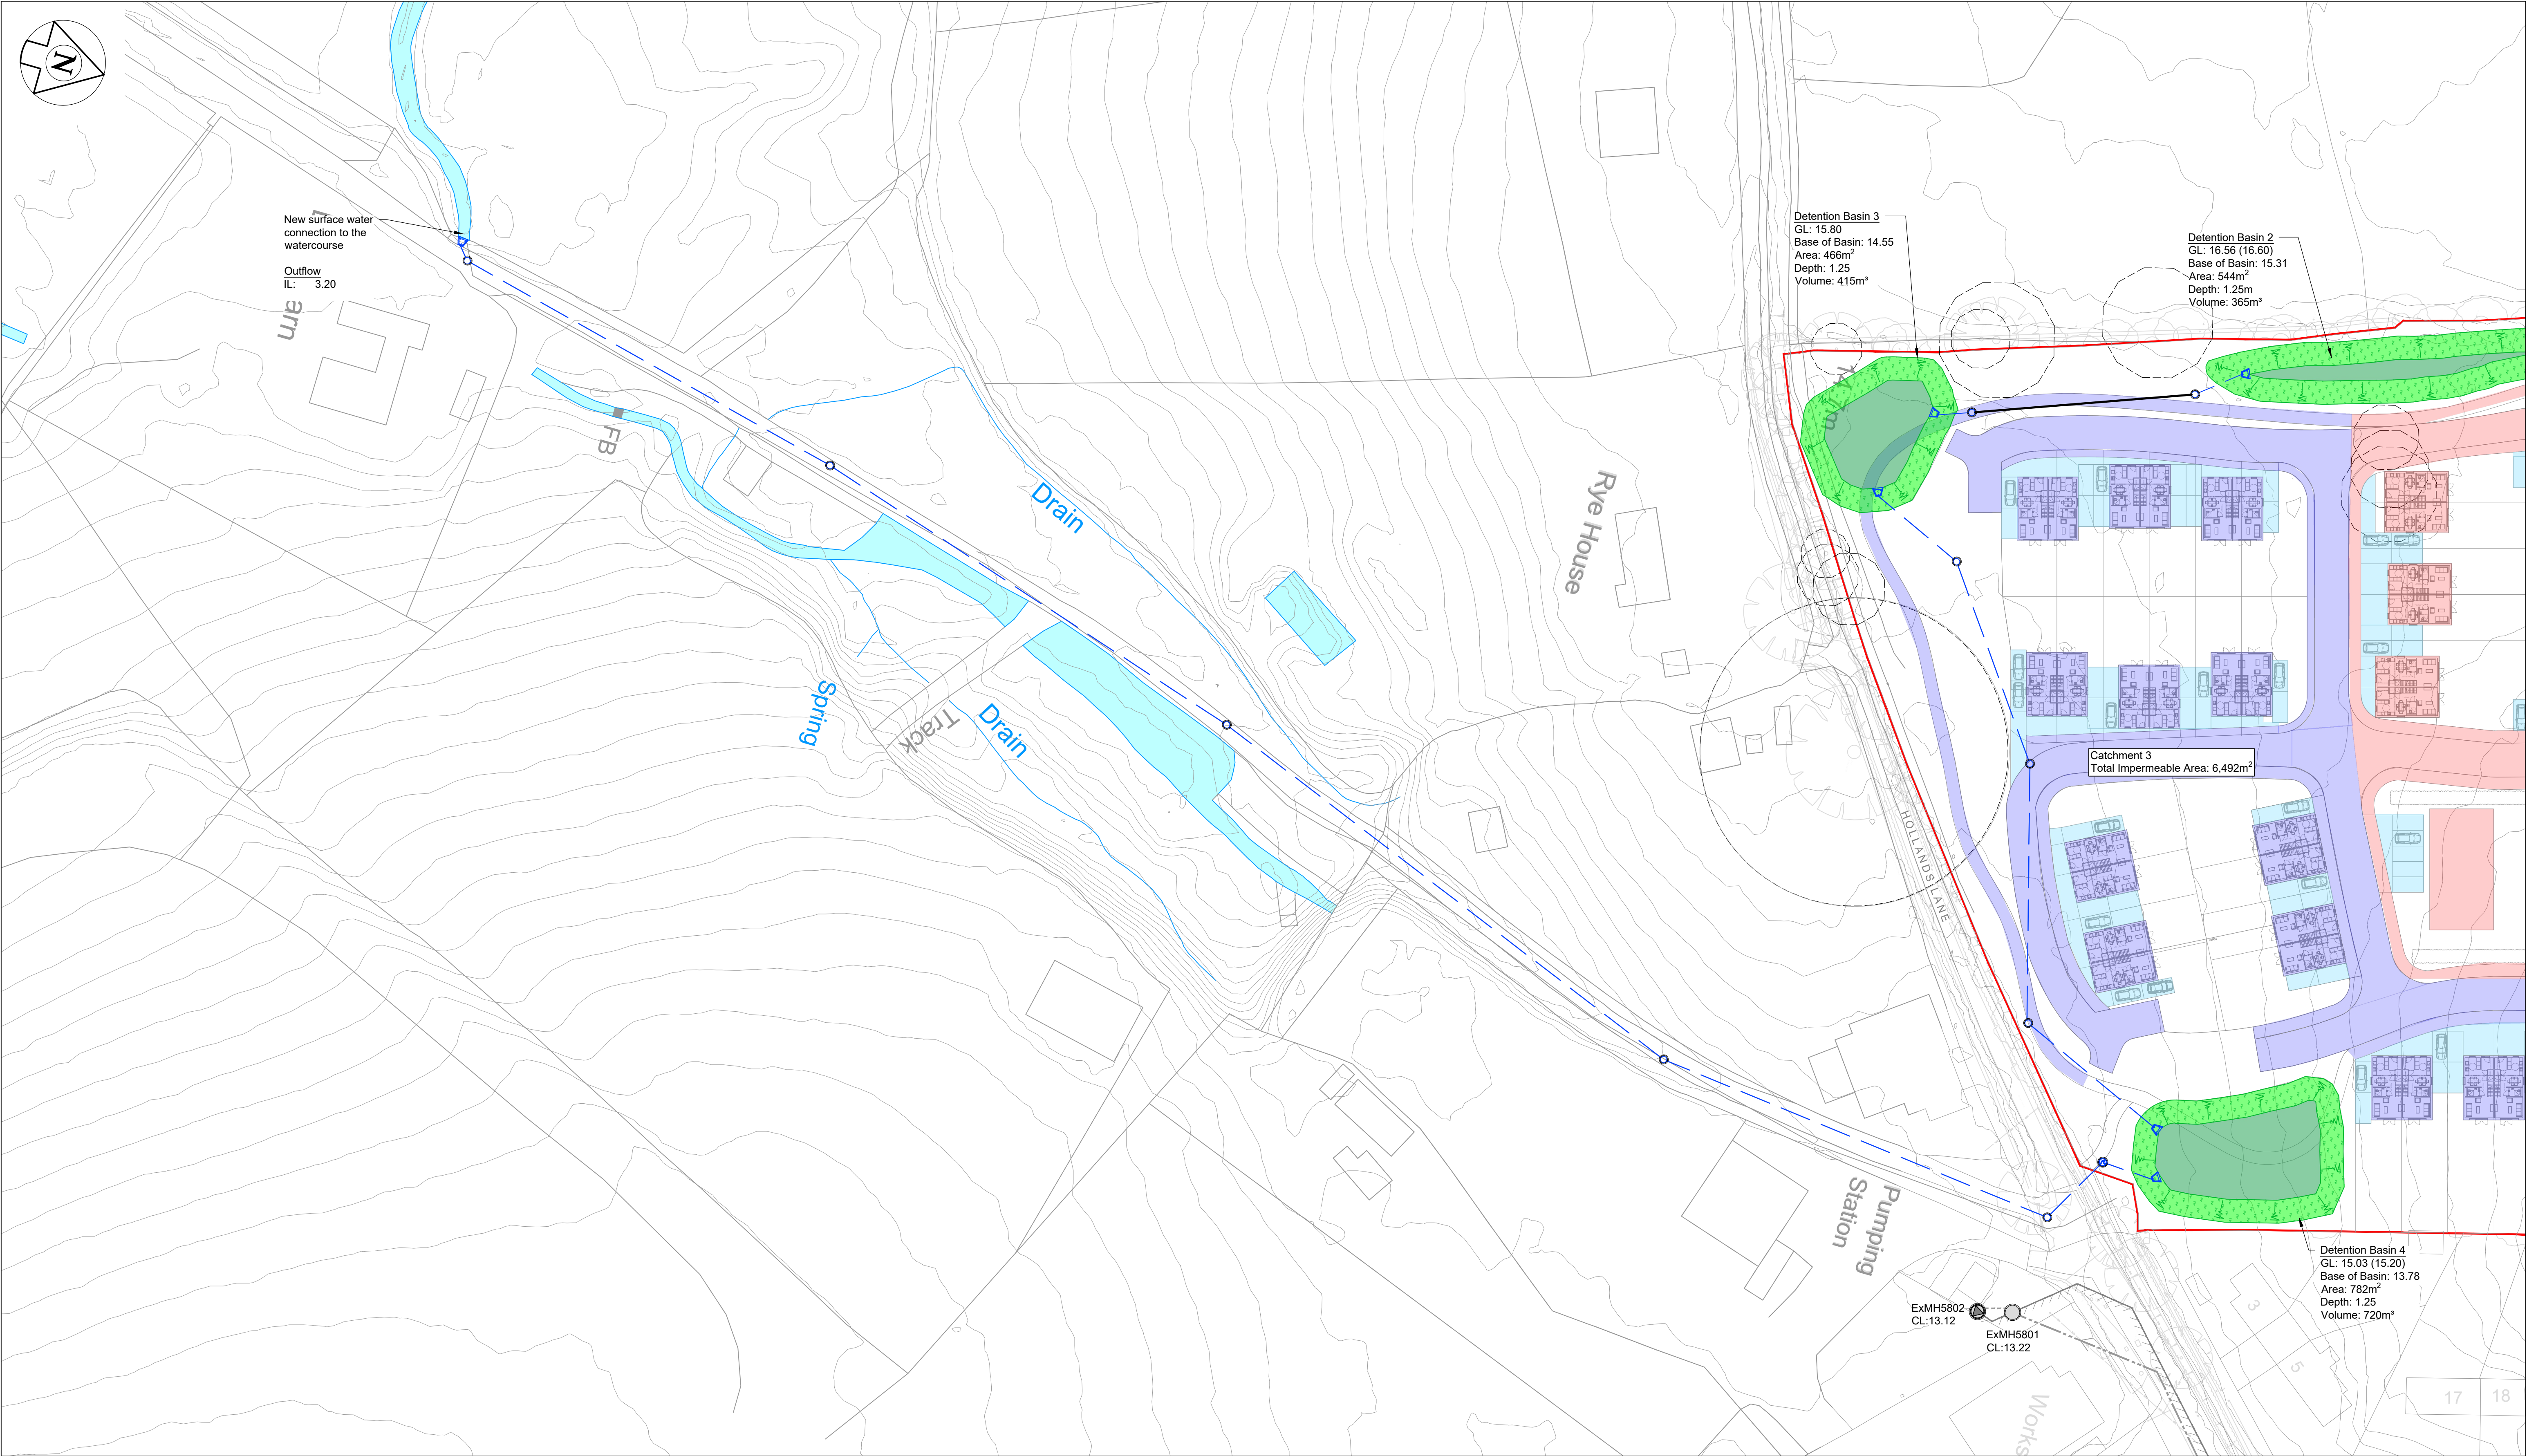

NOTES :

1. This drawing is to be read in conjunction with all relevant Architect's, Engineer's and specialists' drawings and specifications.
2. Do not scale from this drawing in either paper or digital form. Use written dimensions only. To check that this drawing has been printed to the intended scale this bar should be 50mm long @ A1 or 25mm long @ A3.
3. All new new surface water pipework routes to be confirmed with an arboriculturalist.
4. Health & Safety :
All specific drawing notes are to be read in conjunction with the project "Information Pack" and "Site Rules".

DRAINAGE KEY			DRAINAGE KEY	
S1		Surface Water Manhole Chamber		Permeable Paving
				Catchment 1
				Catchment 2
				Catchment 3
				Detention Basin
				Headwall

DRAINAGE LEGEND			
Site Boundary			
Existing Rising Main			
Existing Foul Sewer			
New SW Drain			
Root Protection Zone			

P01	25.04.24	TP	HD	Drain rerouted to avoid RPA
P01	09.08.23	TP	HD	Revised following infiltration testing
Rev	Date	Drawn	Eng	Amendment

SANDGATE NURSERIES
HENFIELD

BELOW GROUND
DRAINAGE LAYOUT
SHEET 2

Status
FOR INFORMATION
NOT FOR CONSTRUCTION

Drawn	TP	Eng	HD
Scales	1:500 at A1	1:1000 at A3	
Drawing No	Rev		
30512/6001	P02		

PRICE &
MYERS

Consulting Engineers
37 Alfred Place
London
WC1E 7DP
020 7631 5128
mail@pricemyers.com
www.pricemyers.com